


LEGEND:-

	MOULDED CASE CIRCUIT BREAKER (MCCB)
	MINIATURE CIRCUIT BREAKER (MCB)
	AIR CIRCUIT BREAKER (ACB)
	VCB BREAKER
	ELECTRICAL INTERLOCKING
	CURRENT TRANSFORMER
	EARTHING
	TRANSFORMER
	DG. SET
	MULTI FUNCTIONAL METER
	INDICATING LAMP
	AUTOMATIC POWER FACTOR CORRECTION RELAY
	VOLTMETER
	VOLTMETER SELECTOR SWITCH
	REVERSE PROTECTION RELAY
	UNDER VOLTAGE RELAY
	OVER VOLTAGE RELAY
	DIFF. PROTECTION RELAY
	MASTER TRIP RELAY
	TRIP CIRCUIT SUPERVISION RELAY

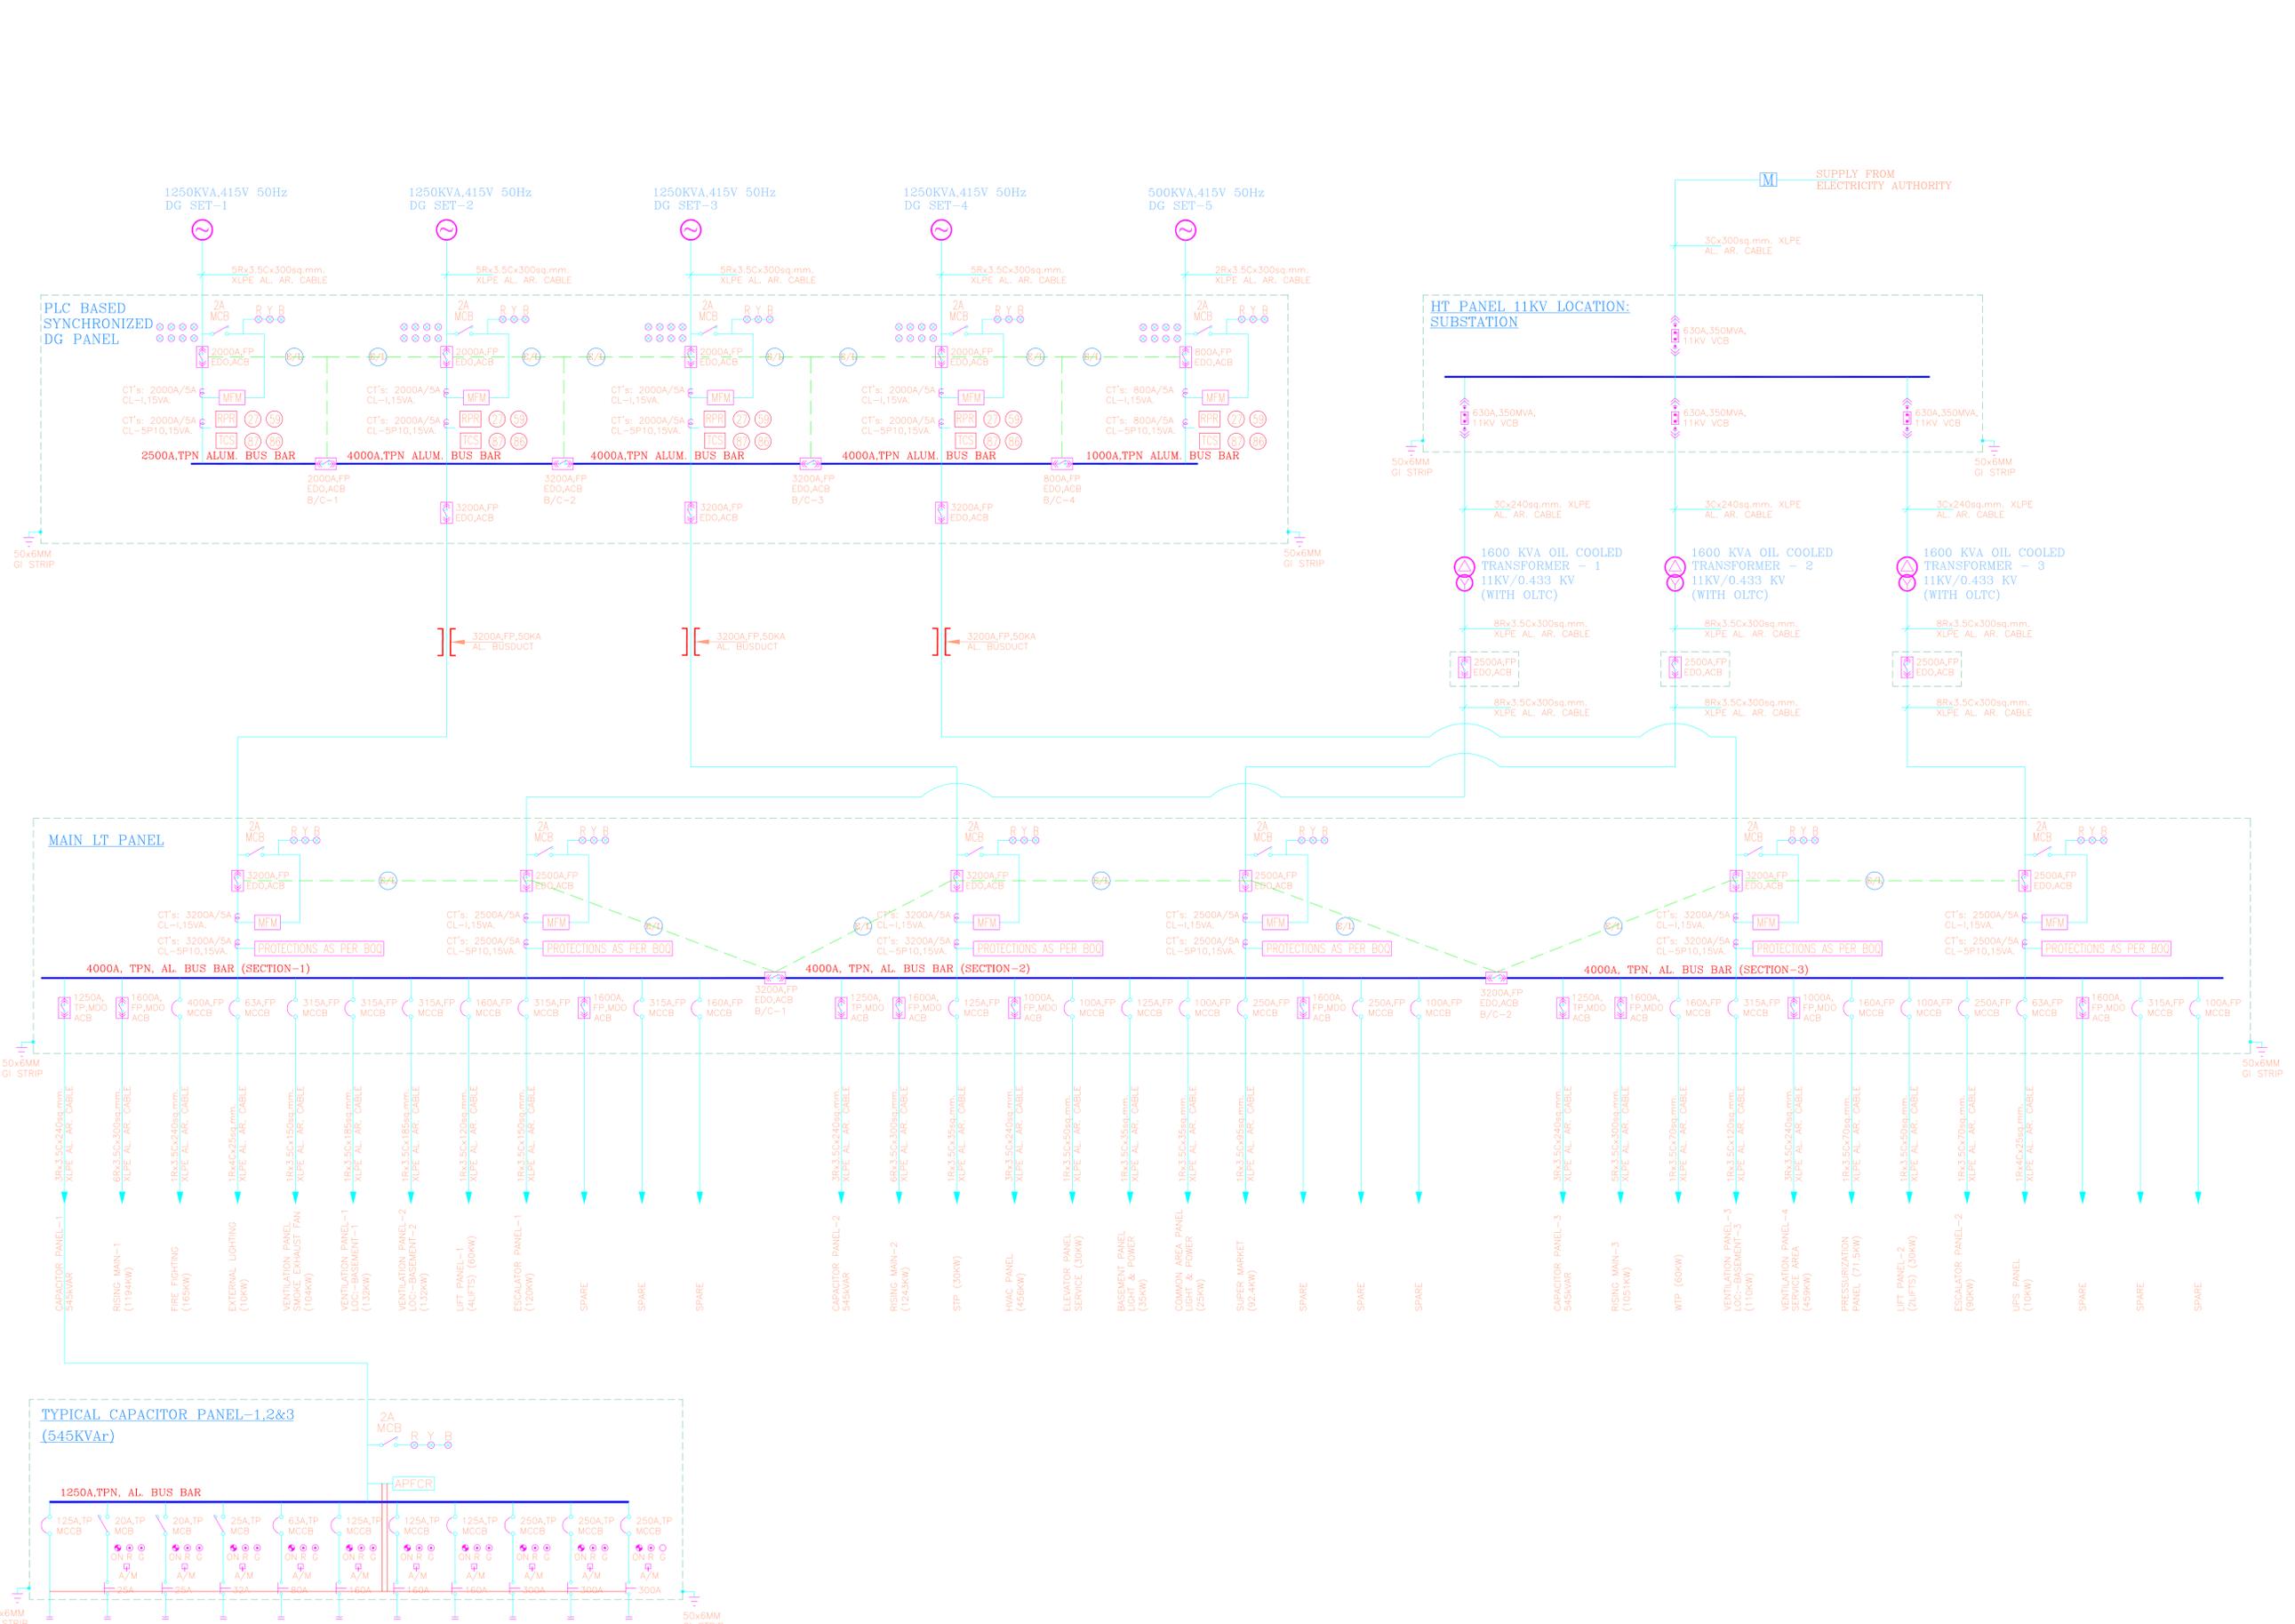

DATE	REV	DESCRIPTION	BY

V CONSULTING
 B-50, Basement, Soami Nagar
 New Delhi-110017
 Tel No: 011-49848197&011-49849205
 Email: info@vconsulting.co.in

ARCHITECTS:-
architecture DNA
 office: A-385, Defence Colony, New Delhi.
 8, Hemkunt Colony, Greater Kailash Part -I,
 New Delhi.
 Phone: +91-11-24333312, +91-11-41630330
 e-mail : architectnaveenvij@yahoo.co.in,
 dps200@gmail.com

PROJECT:-
E-SQUARE
 AT PLOT NO. C-2, SECTOR-96NOIDA
 FOR M/S. HOT-SHOT DEVELOPERS
 PVT. LTD. B-28.29 SECTOR-58 , NOIDA .

TITLE:-
MAIN SINGLE LINE DIAGRAM

SUB TITLE:-
ELECTRICAL LAYOUT

JOB NO.	VKPL-1916
DATE	11.08.2017
SCALE	N.T.S.
DRAWN	JAGJEET
CHKD. BY	ROHIT

DRG. NO. EL-MSLD-01