

PLOT HOUSE OF DR. BANERJEE

PROPOSED GROUP HOUSING ON NAZUL PLOT
NO.26-C(PART) CIVIL STATION, PRESENTLY
NUMBERED AS 26-C1, 26-C3 & 26-C4,
NASISPUR BAKHTIARA (MAUZA) CHIKATPUR,
PARGANA & TAHSIL SADAR, DISTRICT
ALLAHABAD.

PLOT OF SHRI A.N SHERVANI AND
OTHERS NUMBERS AS 26 C/2
BUNGLOW NO 26C

NAZUL PLOT NO. 26 C/2 BUNGLOW
NO. 26B OF SHRI TAHIR HASSAN

PLOT NO. 24 QUEENS ROAD

This architectural site plan illustrates the layout of a building complex. The plan includes several wings and wings A and B, each with its own entrance. A central entrance is located at the bottom of the plan. The complex features multiple parking areas, including a large multi-story garage on the left and several surface parking lots. A central building contains a multi-story garage with an entrance on the left. A large, curved driveway or ramp is located at the bottom left. A legend in the bottom right corner provides symbols for various features: a house, a tree, a fence, a wall, a gate, a road, a driveway, a path, a bridge, a cul-de-sac, a circular driveway, a circular path, a circular road, a circular gate, a circular fence, a circular wall, a circular house, a circular tree, and a circular gate. A north arrow is located in the bottom center.

BASEMENT PLAN

NOTE: THIS PROPOSAL CONFIRMS
WITH THE STANDARDS OF
"UPVIDHI 2008" and
"MAHAYOJANA 2021"


Drawing Title
SUBMISSION DRAWING
PLUMBING PLAN

OWNERS:
MR. A.Q. KHAN
MR. SALEEM IQBAL SHERVANI
MIS. SHERVANI INDUSTRIAL SYNDICATE
LIMITED


Drg. No. 01/04
SITE PLAN
Scale 1: 200
Date 06 FEB' 2020

ARCHITECT SIGN.
Architect **MANISH GUJRAL**
(B. Arch, F.I.V.)
TARANA NASEER
(B. Arch, M. Plan)
Architects and Interior
Designers
52/25 B MIRI ROAD, ALLAHABAD


PROPOSED GROUP HOUSING ON NAZUL PLOT
NO.26-C(PART) CIVIL STATION, PRESENTLY
NUMBERED AS 26-C1, 26-C3 & 26-C4,
NASIPUR BAKHTIARA (MAUZA) CHIKATPUR,
PARGANA & TAHSIL SADAR, DISTRICT
ALLAHABAD.

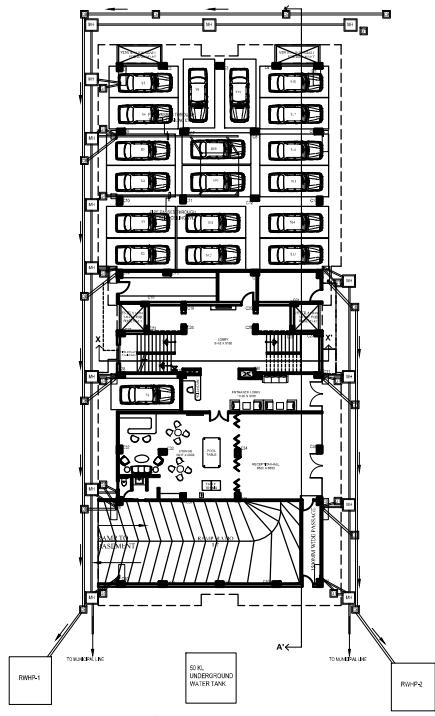

STILT PLAN

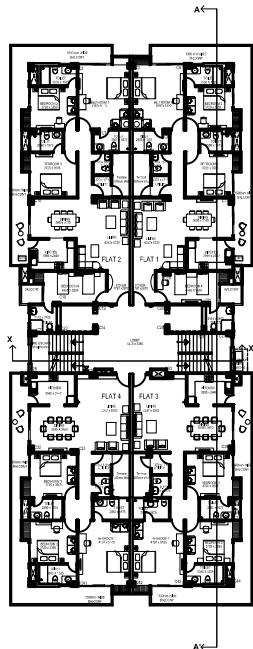

FIRST FLOOR PLAN

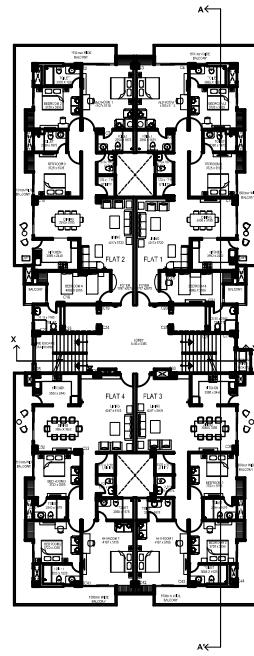

TYPICAL FLOOR PLAN (2nd- 8th)


NOTE: THIS PROPOSAL CONFIRMS
WITH THE STANDARDS OF
"UPVIDHI 2008" and
"MAHAYOJANA 2021"

Drawing Title
SUBMISSION DRAWING
PLUMBING PLAN


Drg. No. 01/04
SITE PLAN
Scale 1:200
Date 06 FEB 2020

ARCHITECT SIGN.
Architect **MANISH GUJRAL**
(B. Arch, F.I.A.V.)
TARANA NASEER
(B. Arch, M. Plan)
Architects and Interior
Designers
52/ 25 B MUIR ROAD, ALLAHABAD


PROPOSED GROUP HOUSING ON NAZUL PLOT NO.26-C PARTI CIVIL STATION PRESENTLY NUMBERED AS 20-C1, 26-C3 & 26-C4, NAZUL PLOT, MATHURA (MAUZA) CHHATPUR, PARGANA & TAHSIL SADAR, DISTRICT ALLAHABAD.

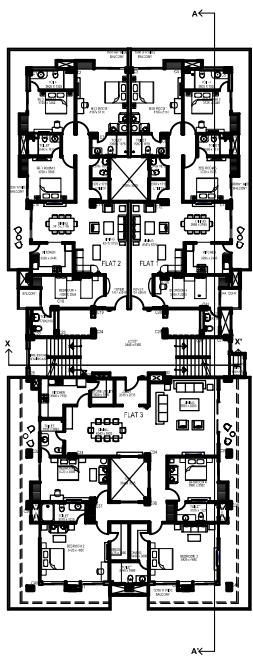

NINTH FLOOR PLAN

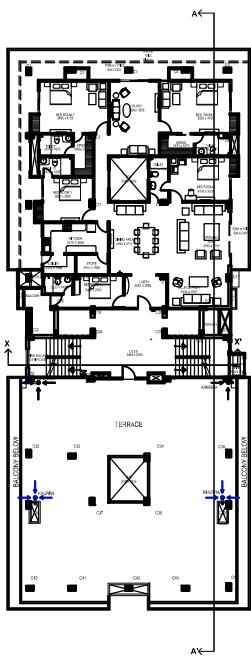

TENTH FLOOR PLAN

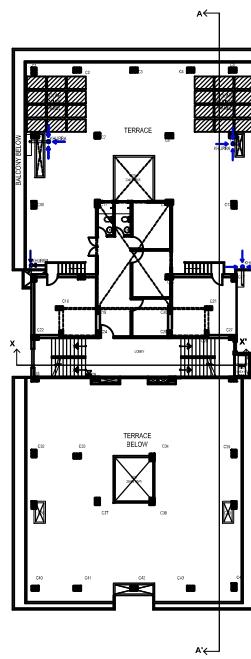

TERRACE FLOOR PLAN

NOTE: THIS PROPOSAL CONFIRMS WITH THE STANDARDS OF "UPVIDHI 2006" and "MAHYOJANA 2021".

Drawing Title
SUBMISSION DRAWING
PLUMBING PLAN

OWNERS:
MR. A.Q. KHAN
MR. SALEEMOBAL SHERVANI
M/S. SHERVANI INDUSTRIAL SYNDICATE
LIMITED

Draw. No. 01/04
SITE PLAN
Scale 1: 200
Date 06 FEB/ 2020
North

ARCHITECT SIGN.

Architect
MANISH GUJRAL
(B.Arch, F.A.V)
TANU GUJRAL
(B.Arch, M.Plan)
Architects and Interior
Designers
52/ 25 B MUIR ROAD, ALLAHABAD