


NOTE:-
 1. THIS DRAWING IS PROPERTY OF M/S AGGARWAL DESIGNERS PVT. LTD. AND NOT ALLOWED TO COPY OR USE FOR ANY OTHER PURPOSE THAN FOR WHICH IT IS ISSUED, WITHOUT PERMISSION.
 2. ALL DIMENSIONS ARE IN MILLIMETERS UNLESS SPECIFIED.
 3. DISCREPANCY IF ANY SHALL BE BROUGHT IN THE NOTICE OF ARCHITECT/SITE IN CHARGE AND SHALL BE CLARIFIED IN WRITING, BEFORE EXECUTION.

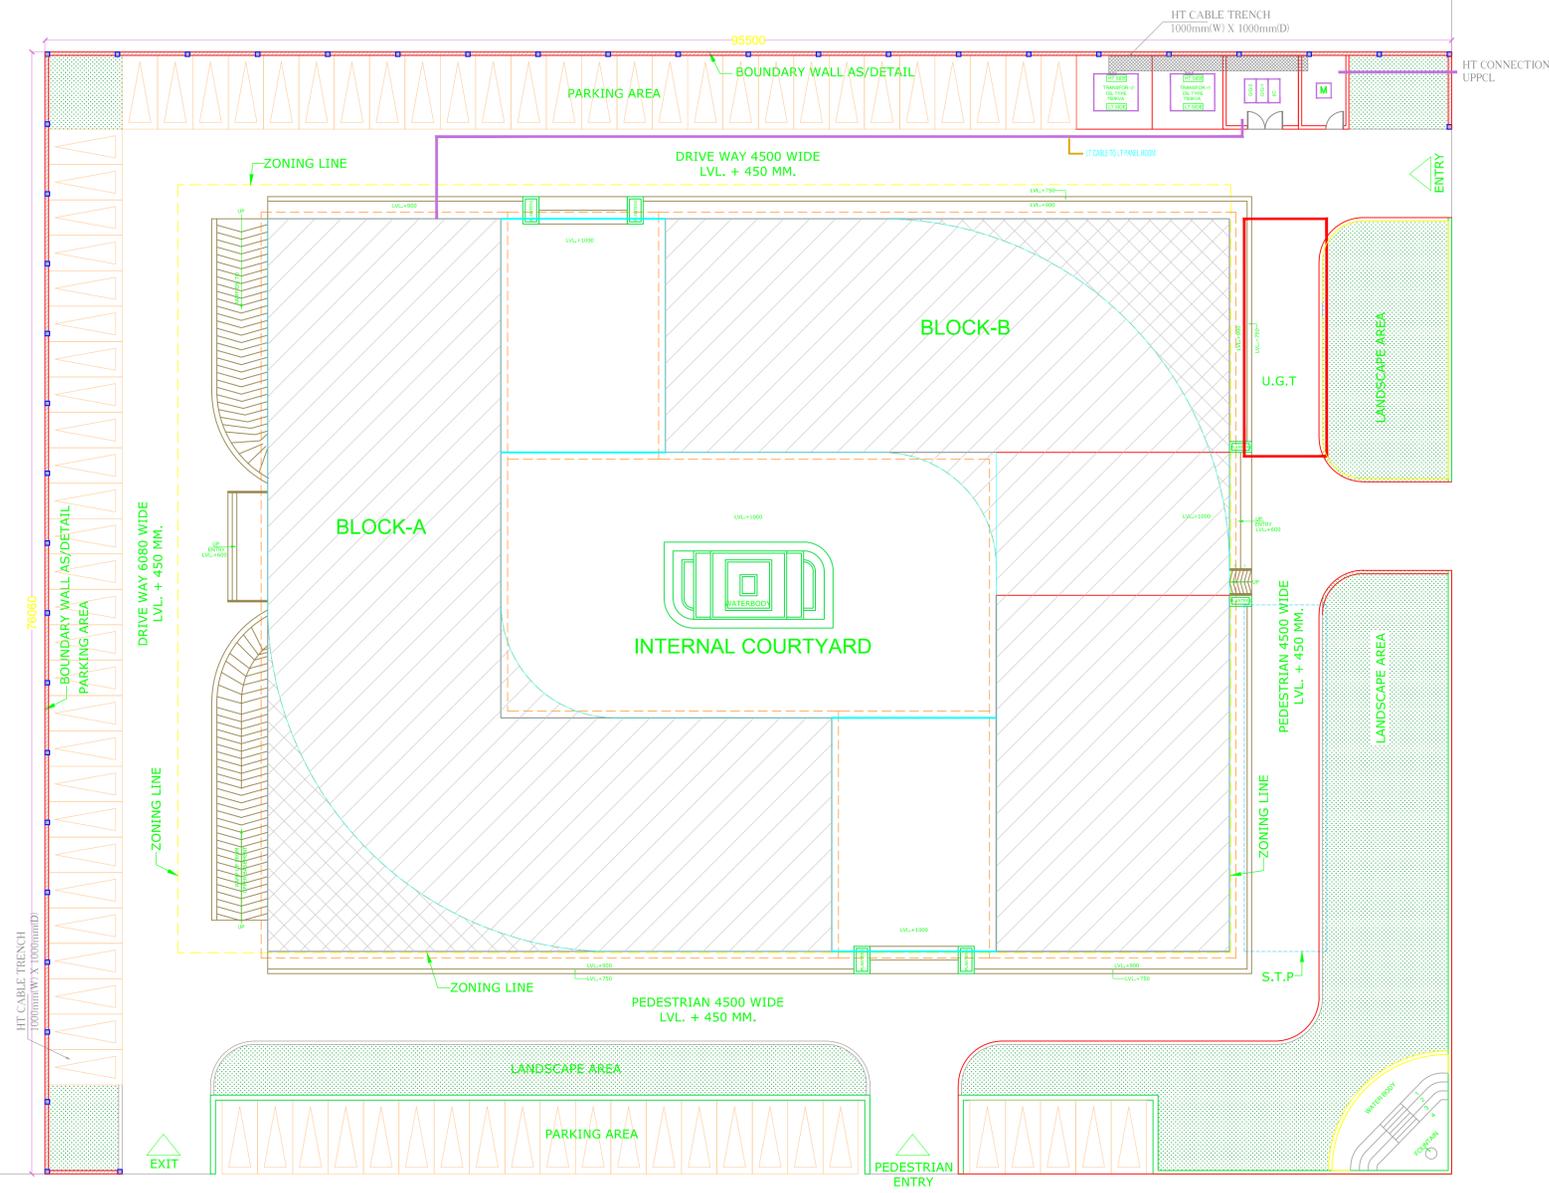

30 M WIDE ROAD

45 M WIDE ROAD

COMMERCIAL COMPLEX

PROJECT:-
 PROPOSED COMMERCIAL COMPLEX AT PLOT NO. 1/15,
 SECT.- 1 GOMTI NAGAR EXTENSION, LUCKNOW

OWNER'S NAME
 National Buildings Construction Corporation Limited
 (Govt. of India Enterprise)
 REAL ESTATE DIVISION
 NBCC BHAWAN, LODHI ROAD,
 NEW DELHI-110003

CONSULTANT
 M/s AGGARWAL DESIGNERS PVT. LTD.
 3/4, 3RD FLOOR, AGGARWAL CITY PLAZA,
 MANGLAM PLACE, SECTOR-3, ROHINI, DELHI-110085
 e-mail : aggarwaldesignerpvtltd503@gmail.com
 apdsh1@gmail.com
 Phone no. 09212114614, (011) 27940603.

DATE	NO.	DESCRIPTION	DRN.	CHKD.	APPD.
REVISION					

SCALE: N.T.S.

DATE: _____

DEALT: ANJALI

DESIGNED: ANJALI

CHECKED: _____

ABHISHEK AGGARWAL

APPD BY: _____

ABHISHEK AGGARWAL

DRG. NO: ADPL/NBCC/LKW/EL-01

REV. 0

TITLE: ELECTRICAL SUPPLY SITE PLAN