


NOTE:-
 1. THIS DRAWING IS PROPERTY OF M/s AGGARWAL DESIGNERS PVT. LTD. AND NOT ALLOWED TO COPY OR USE FOR ANY OTHER PURPOSE THAN FOR WHICH IT IS ISSUED, WITHOUT PERMISSION.
 2. ALL DIMENSIONS ARE IN MILLIMETERS UNLESS SPECIFIED.
 3. DISCREPANCY IF ANY SHALL BE BROUGHT IN THE NOTICE OF ARCHITECT/SITE IN CHARGE AND SHALL BE CLARIFIED IN WRITING, BEFORE EXECUTION.

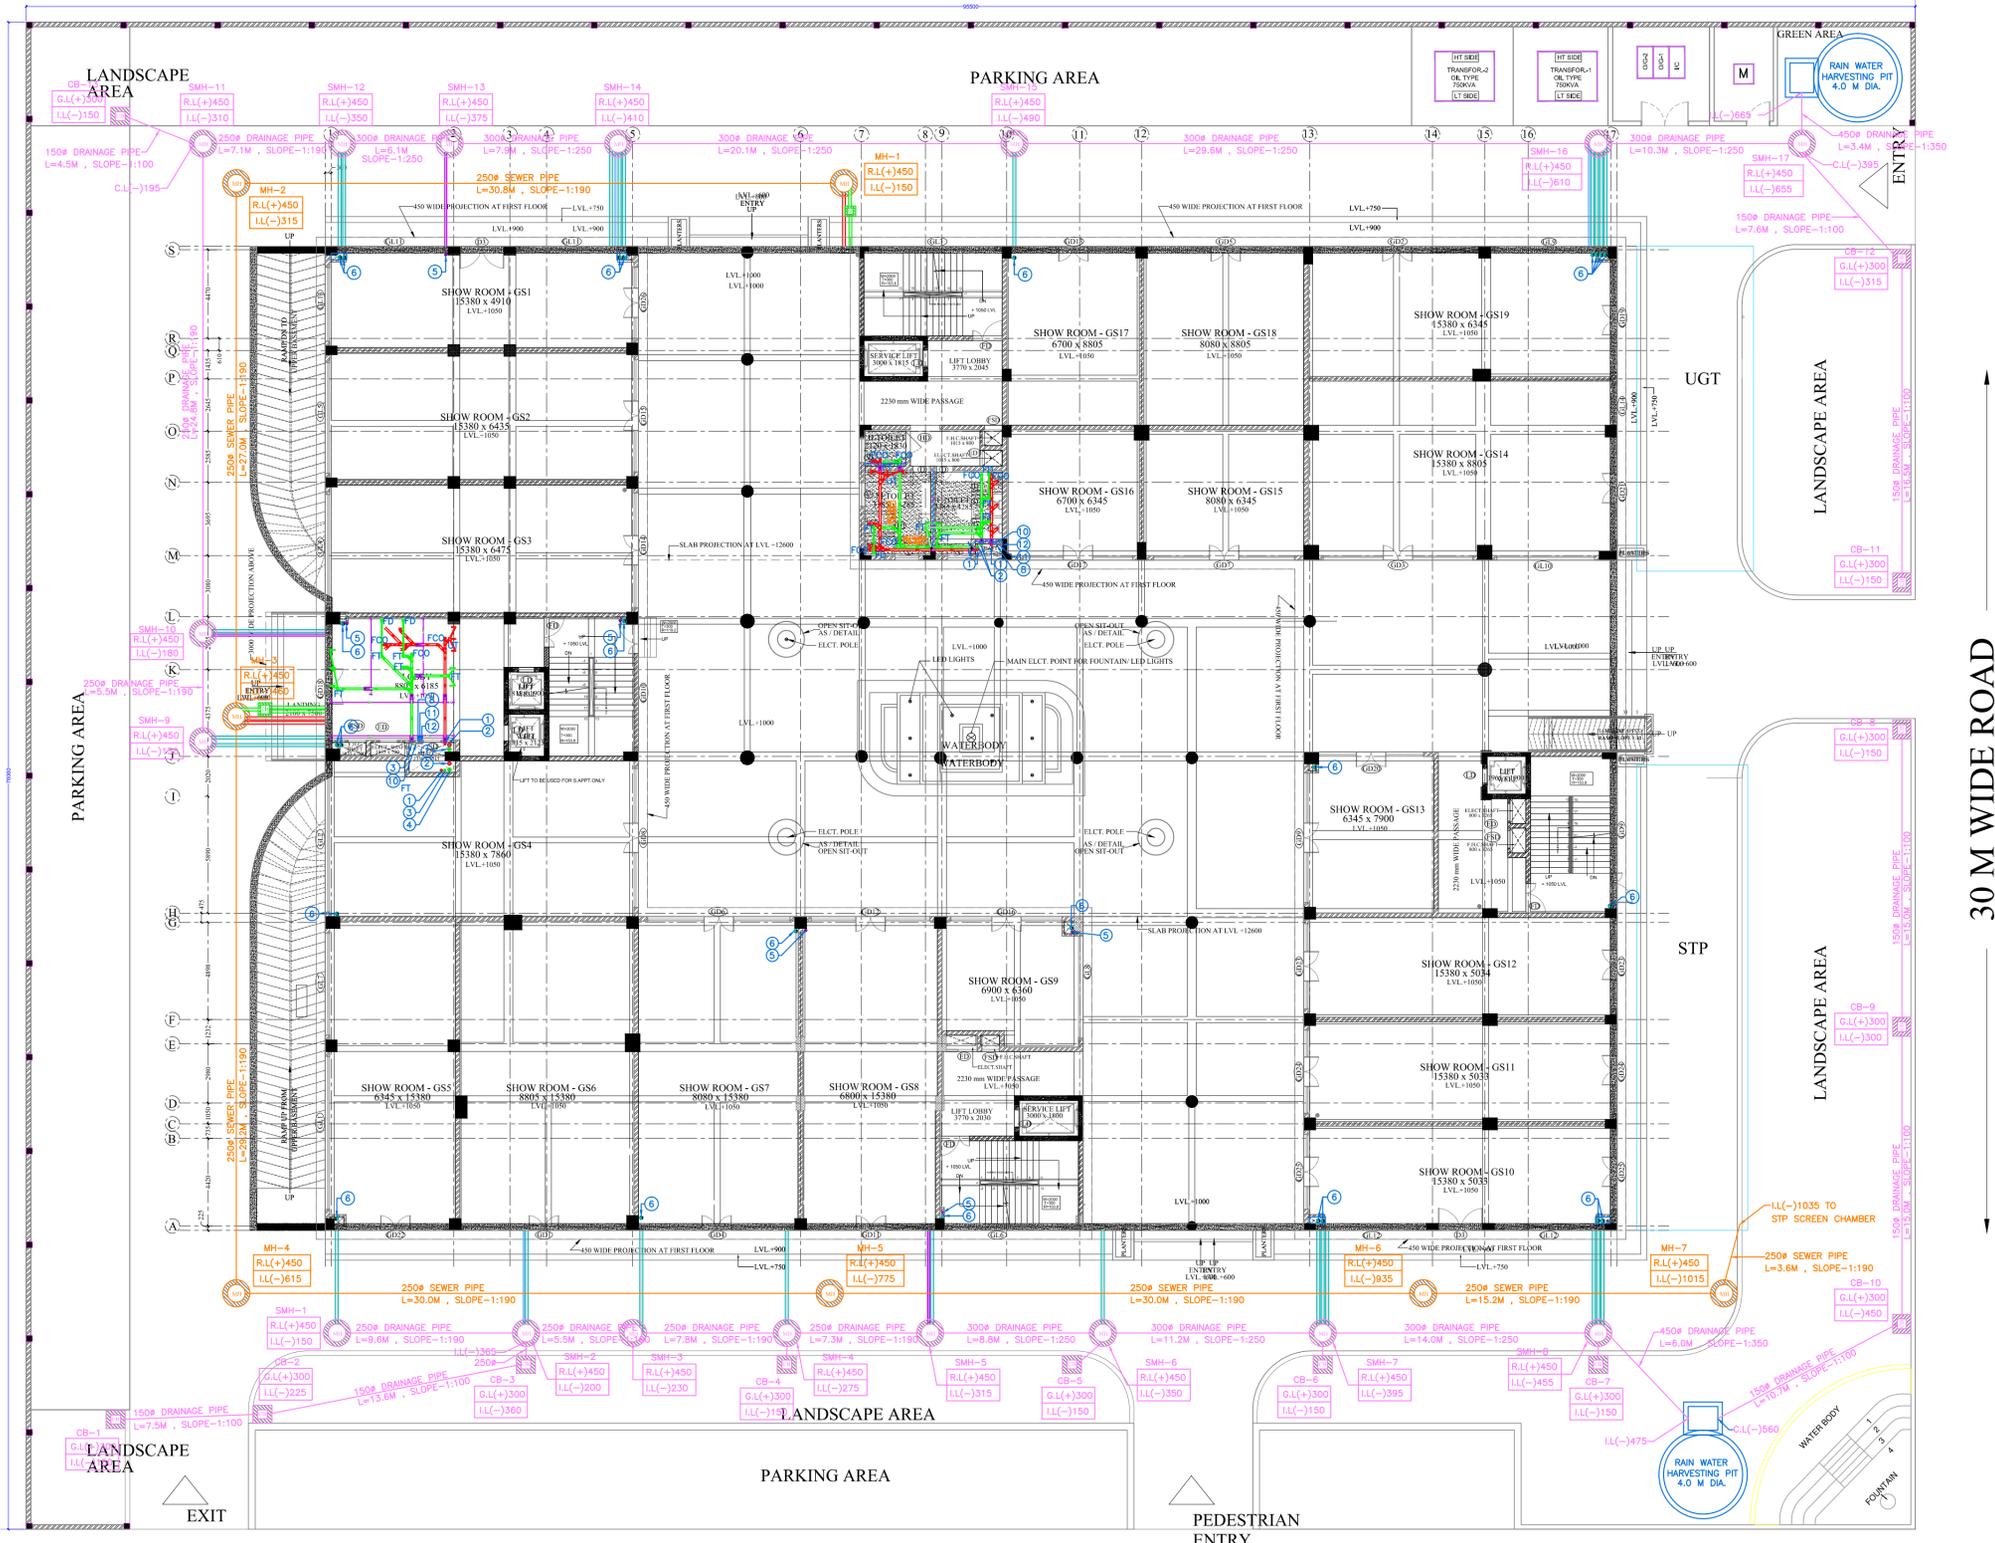

GROUND FLOOR PLAN

DATE	NO.	DESCRIPTION	DRN.	CHKD.	APPD.	
REVISION						
PROJECT: PROPOSED COMMERCIAL COMPLEX PLOT NO. 1/15, SECT.- 1, GOMTI NAGAR EXTENSION, LUCKNOW						
CLIENT: National Buildings Construction Corporation Limited (Govt. of India Enterprise)						
REAL ESTATE DIVISION NBCC BHAWAN, LOCHI ROAD, NEW DELHI-110003						
PHE CONSULTANT: TECH CONSULTANCY SERVICES 370 Aggarwal City Plaza, Near M2K Mall, Plot No.-17, Magalam Place District Center Sector - 3, Rohini, Delhi - 110085						
CONSULTANT: M/s AGGARWAL DESIGNERS PVT. LTD. 364, 3RD FLOOR, AGGARWAL CITY PLAZA, MANGLAM PLACE, SECTOR-3, ROHINI, DELHI-110085 e-mail: aggarwaldesignerspltd03@gmail.com, adp191@gmail.com						
SCALE	NORTH:-					
DATE	N.T.S.					
DEALT	20-02-2017					
DESIGNED	SAM					
CHECKED	ARTI					
APPD BY	SURESH					
ABHISHEK AGGARWAL	TITLE: SEWERAGE & DRAINAGE LAYOUT PLAN GROUND FLOOR LVL					
DRG. NO:	ADPL/NBCC/LKW/PL-01				REV.	0