

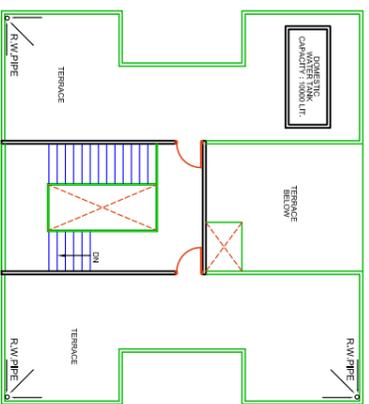
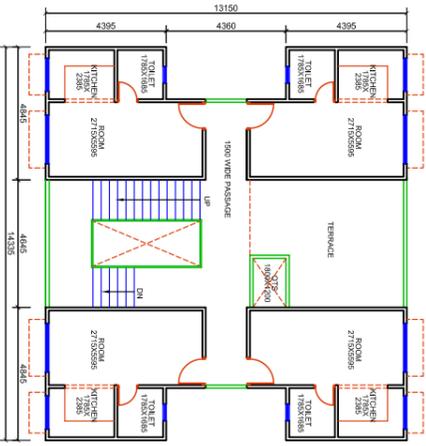
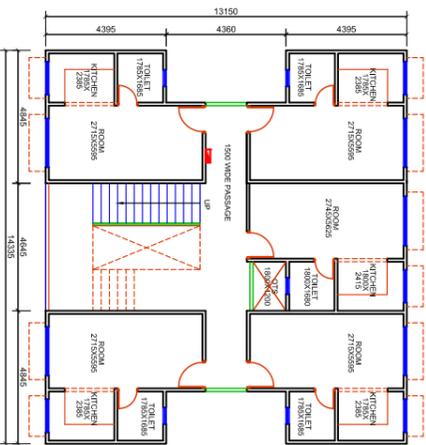
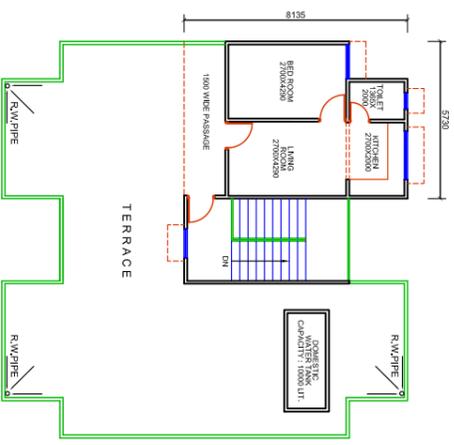


E.W.S. BLOCK

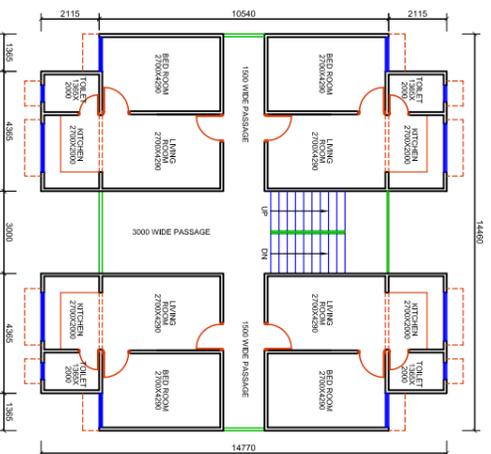


L.I.G. BLOCK

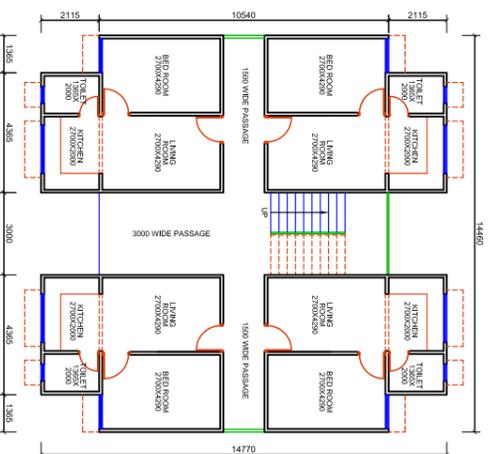

TERRACE FLOOR PLAN
SCALE: 1:100

WASTE DISPOSAL, WATER SUPPLY & ELECTRICAL SUPPLY PLAN

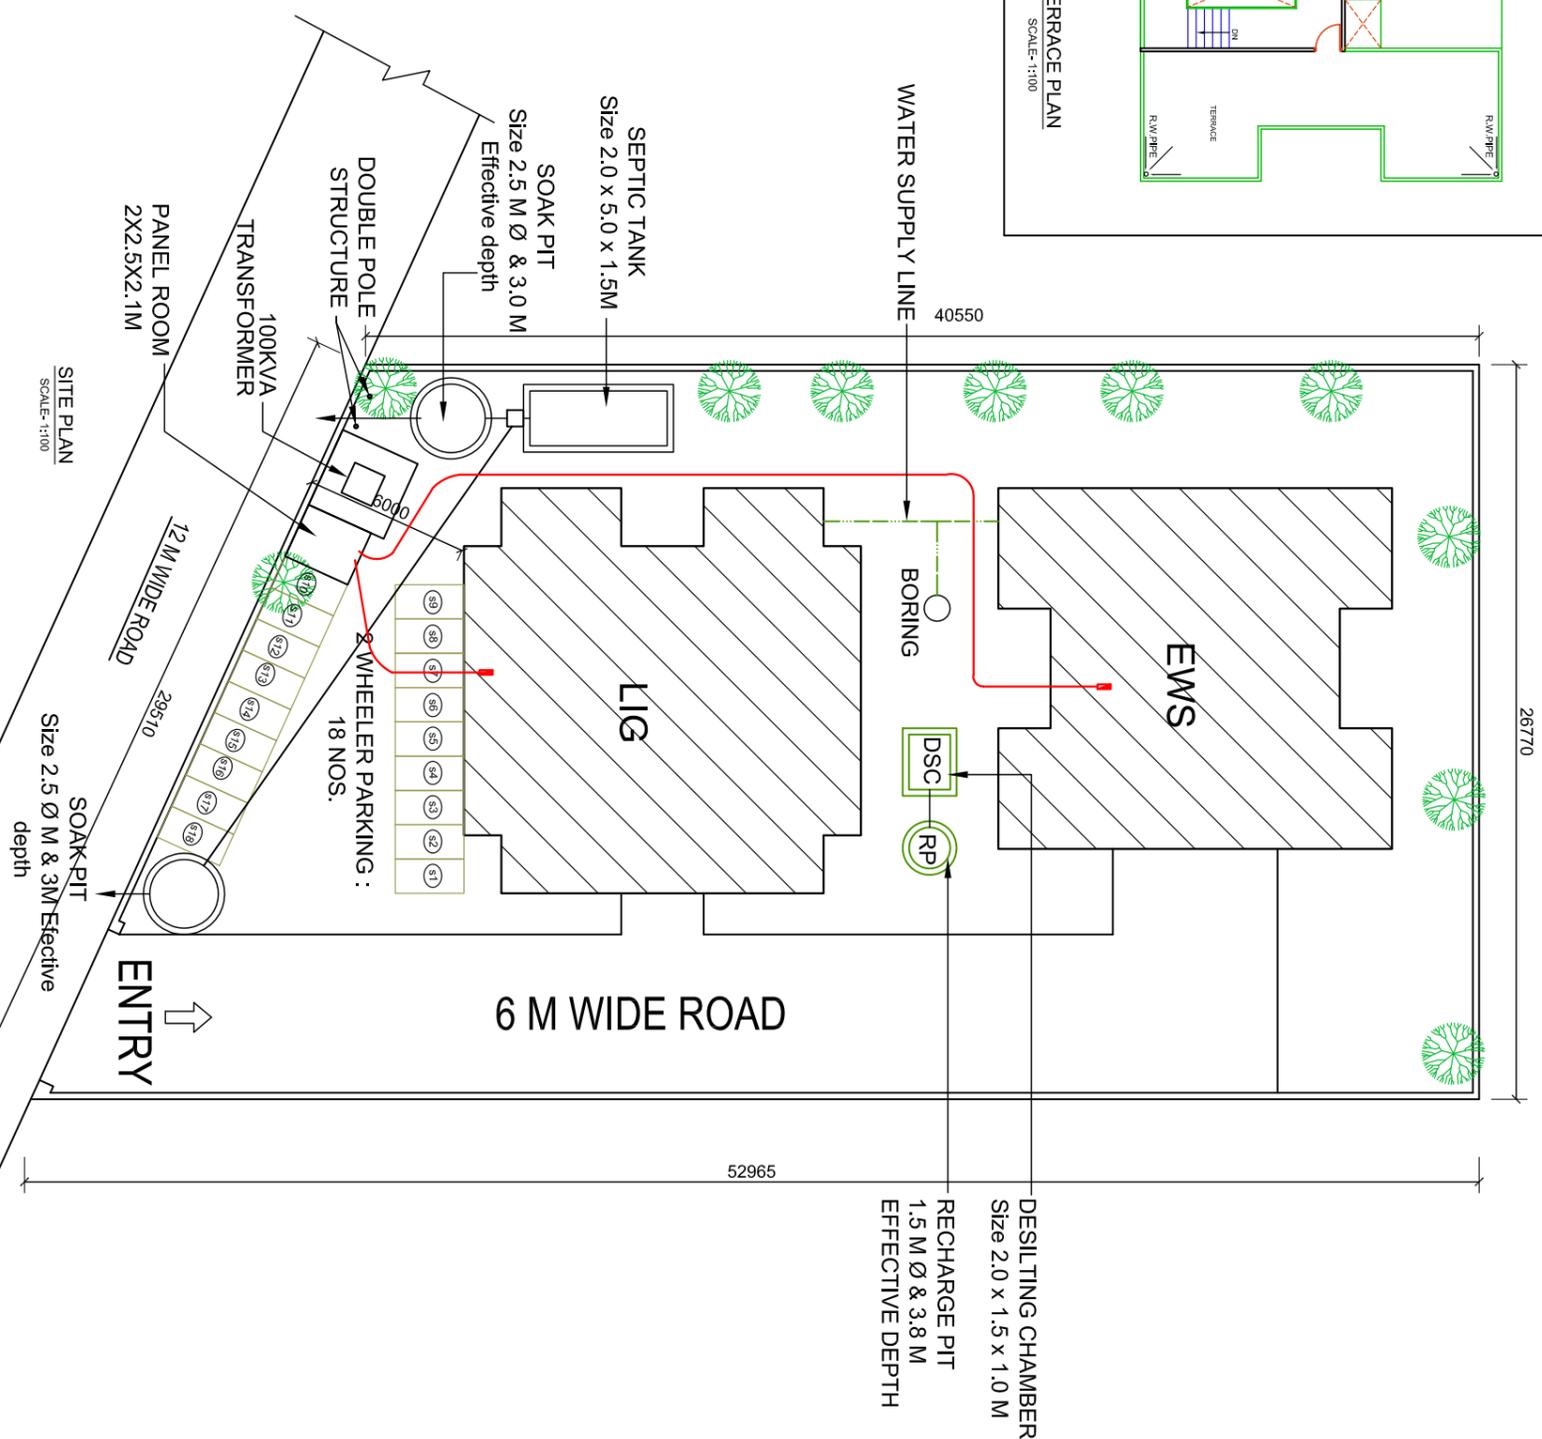

Job title :

PROPOSED LIG & EWS FLATS OF AISHWARYA HEIGHTS APARTMENT FOR SHRI RAMESH CHANDRA SHUKLA S/O SHRI BEHARI LAL ON KHASRA NO. 1282, VILLAGE - JAITIKHEDA, PARAGANA - BIJNAUR, LUCKNOW

Drq title :

WATER DISPOSAL, WATER SUPPLY & ELECTRICAL SUPPLY PLAN

North :



Scale :

N.T.S.