



PLUMBING LEGEND:-	
	IRRIGATION WATER SUPPLY LINE
	GARDEN HYDRANT
	AIR VALVE
	DRAIN VALVE

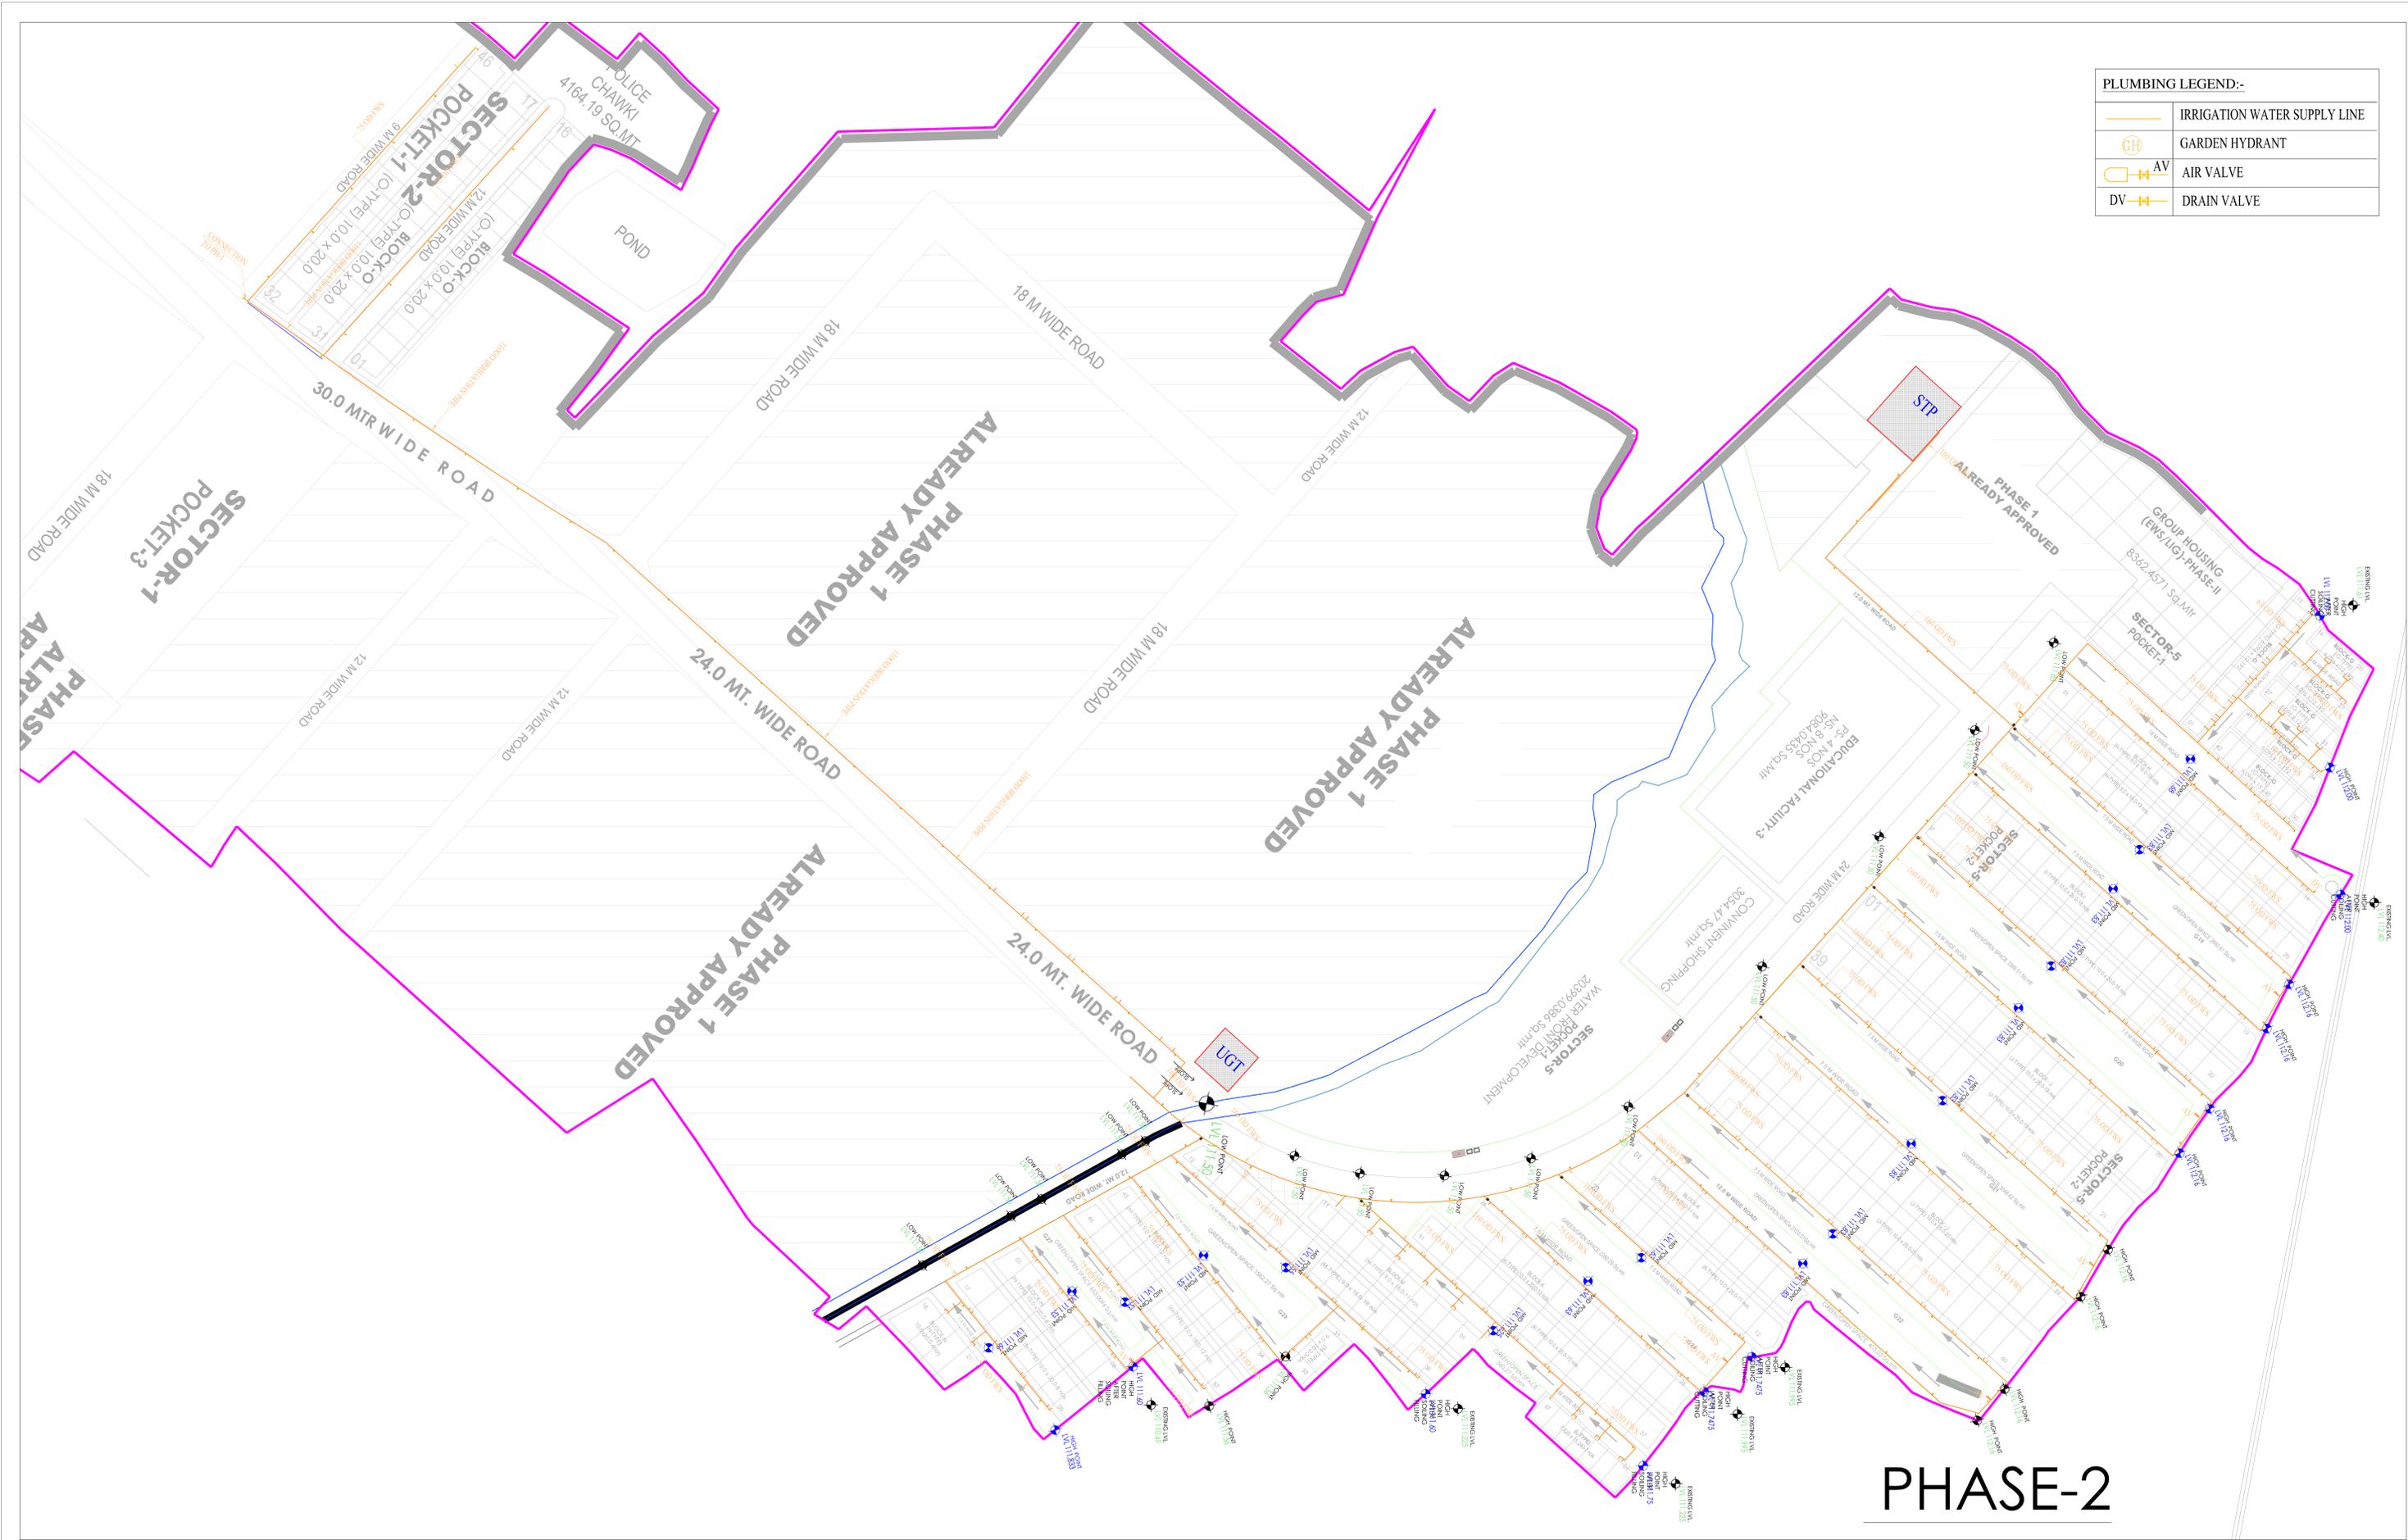

**PHASE-2**

**PARK CITY**  
 AN INTEGRATED TOWNSHIP  
 AT SULTANPUR ROAD, LUCKNOW.

BUILDING MEP CONSULTANT  
 VIZICON  
 FLAT NO.-14/34 YAMAN  
 SAHARA STAES LUCKNOW  
 triveniconsultants.lko@gmail.com

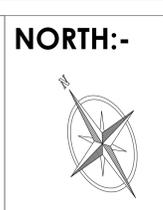

**DEALT BY:-**

**SCALE:-**

**DATE:-**  
 01 NOV 2021

**SCALE:-**  
 NTS

**DRAWING TITLE:-**  
 FLUSHING WATER  
 SUPPLY SCHEME

**DRAWING NO:-**  
 PL/PP/SP/FWS/02

**PHASE-2**

**SHEET NO:-**  
**01**

**ARCHITECT PLANNER**  
 AR . TRIPTIE AWASTHI

**CLIENT:-**  
**PINTAIL**  
 Regd Office:-  
 705-708; 7th Floor,  
 Eideco Corporate Tower  
 Vibhuti Khand Gomti Nagar,  
 Lucknow-226010

Regd. Off:-  
 B-274 SECTOR -B  
 AVAS VIKAS COLONY  
 Rajajipuram, LUCKNOW