

ELECTRICAL LEGEND :	
	EXTRA LOW VOLTAGE CCTV/TELEPHONE FEEDER PILLAR
	OUTDOOR BOX TYPE CAMERA VANDAL RESISTANCE IK-10, IP66 FULL HIGH DEFINITION BULLET IR CAMERA 2 MEGAPIXEL 1/2 IMAGE SENSOR 0.05 LUX COLOUR VARI FOCAL LENCE 2.8MM TO 13MM
	ELECTRICAL FEEDER PILLAR
	60W LED LIGHT FIXTURE ON 6.5 MTR. POLE WITH SINGLE ARM
	120W LED LIGHT FIXTURE ON 9 MTR. POLE WITH SINGLE ARM
	EARTHING PIT

ELECTRICAL LEGEND :	
	L3 60W LED LIGHT FIXTURE ON 6.5 MTR. POLE WITH SINGLE ARM
	L5 120W LED LIGHT FIXTURE ON 9 MTR. POLE WITH SINGLE ARM
	3Cx4 SqMM Cu AR. CABLE
	FEEDER PILLAR FOR EXT. LIGHTING
	NP-3 HUME PIPE FOR ELECTRICAL CABLE
	LOOPING

ELECTRICAL LEGEND :	
	EXTRA LOW VOLTAGE CCTV/TELEPHONE FEEDER PILLAR
	OUTDOOR BOX TYPE CAMERA VANDAL RESISTANCE IK-10, IP66 FULL HIGH DEFINITION BULLET IR CAMERA 2 MEGAPIXEL 1/2 IMAGE SENSOR 0.05 LUX COLOUR VARI FOCAL LENCE 2.8MM TO 13MM
	ELECTRICAL FEEDER PILLAR
	60W LED LIGHT FIXTURE ON 6.5.0 MTR. POLE WITH SINGLE ARM
	PSS TO FEEDER PILLAR LT CABLE
	ELECT. FEEDER PILLAR PLOT
	20x22 AWG STRANDED (7x30) TWINED COOPER SHIELDED CABLE
	HT CABLE
	NP-3 HUME PIPE FOR LT CABLE
	EARTHING PIT

LEGEND FOR GARDEN HYDRANT WATER SUPPLY	
	GARDEN HYDRANT SUPPLY LINE
	VALVE CHAMBER
	GARDEN HYDRANT POINT
	25 OD MDPE GH WATER SUPPLY LINE
	32 OD MDPE GH WATER SUPPLY LINE
	50 OD MDPE GH WATER SUPPLY LINE
	63 OD MDPE GH WATER SUPPLY LINE
	90 OD MDPE GH WATER SUPPLY LINE

LEGEND FOR SEWAGE SYSTEM	
	1500 RCC SEWAGE LINE
	2000 RCC SEWAGE LINE
	2500 RCC SEWAGE LINE
	SEWER MANHOLE
	INSPECTION CHAMBER(750x750x950mm DEEP)

LEGEND FOR STORM WATER SYSTEM	
	1500 RCC STORM WATER PIPE
	2000 RCC STORM WATER PIPE
	2500 RCC STORM WATER PIPE
	3000 RCC STORM WATER PIPE
	3500 RCC STORM WATER PIPE
	5000 RCC STORM WATER PIPE
	STORM WATER MANHOLE
	RAIN WATER HARVESTING PIT
	CATCH BASIN 450x450(mm)
	1500 RCC NP3 STORM WATER PIPE (SL OPE - 1:100)
	2500 RCC NP3 STORM WATER PIPE (SL OPE - 1:100)
	3000 RCC NP3 STORM WATER PIPE (SL OPE - 1:100)
	3500 RCC NP3 STORM WATER PIPE (SL OPE - 1:100)
	5000 RCC NP3 STORM WATER PIPE (SL OPE - 1:100)

LEGEND FOR DOMESTIC WATER SUPPLY	
	DOMESTIC WATER SUPPLY
	VALVE CHAMBER
	63 OD MDPE WATER SUPPLY LINE
	90 OD MDPE WATER SUPPLY LINE
	110 OD MDPE WATER SUPPLY LINE

LEGEND FOR DOMESTIC WATER SUPPLY	
	DOMESTIC WATER SUPPLY
	VALVE CHAMBER
	63 OD MDPE WATER SUPPLY LINE
	90 OD MDPE WATER SUPPLY LINE
	110 OD MDPE WATER SUPPLY LINE


CLIENT:-
 J. K. COTTON LTD.
 FORMLY KNOWN
 AS J.K. COTTON Spinning And Weaving
 MildDwarkadheesh Temple Road, Kamla
 Tower, Kanpur

ELECT & PLUMBING CONSULTANT:-
KKSC
 KISHOR KUMAR SERVICES CONSULTANTS
 007-PINNACLE TOWER, GH-7
 AHINSA KHAND-2, INDRAPURAM
 GHAZIABAD, UP-201014
 PHONE: +91 120 4132550
 MOBILE: +91 9910487835
 kksco101@gmail.com

Project:-
 PART PLOTTED DEVELOPMENT- COMMERCIAL
 JAJMAU, KANPUR

DRAWING TITLE
 COMMERCIAL
 DEVELOPMENT WORK LAYOUT PLAN

DRAWN BY. D.S.	DATED BY. 30.09.2022
CHECKED BY. OSA	SCALE 1:400 (A1)
APPROVED BY. K.K	DRG.No. KKSC/JK.C.CO/PL-SS-01

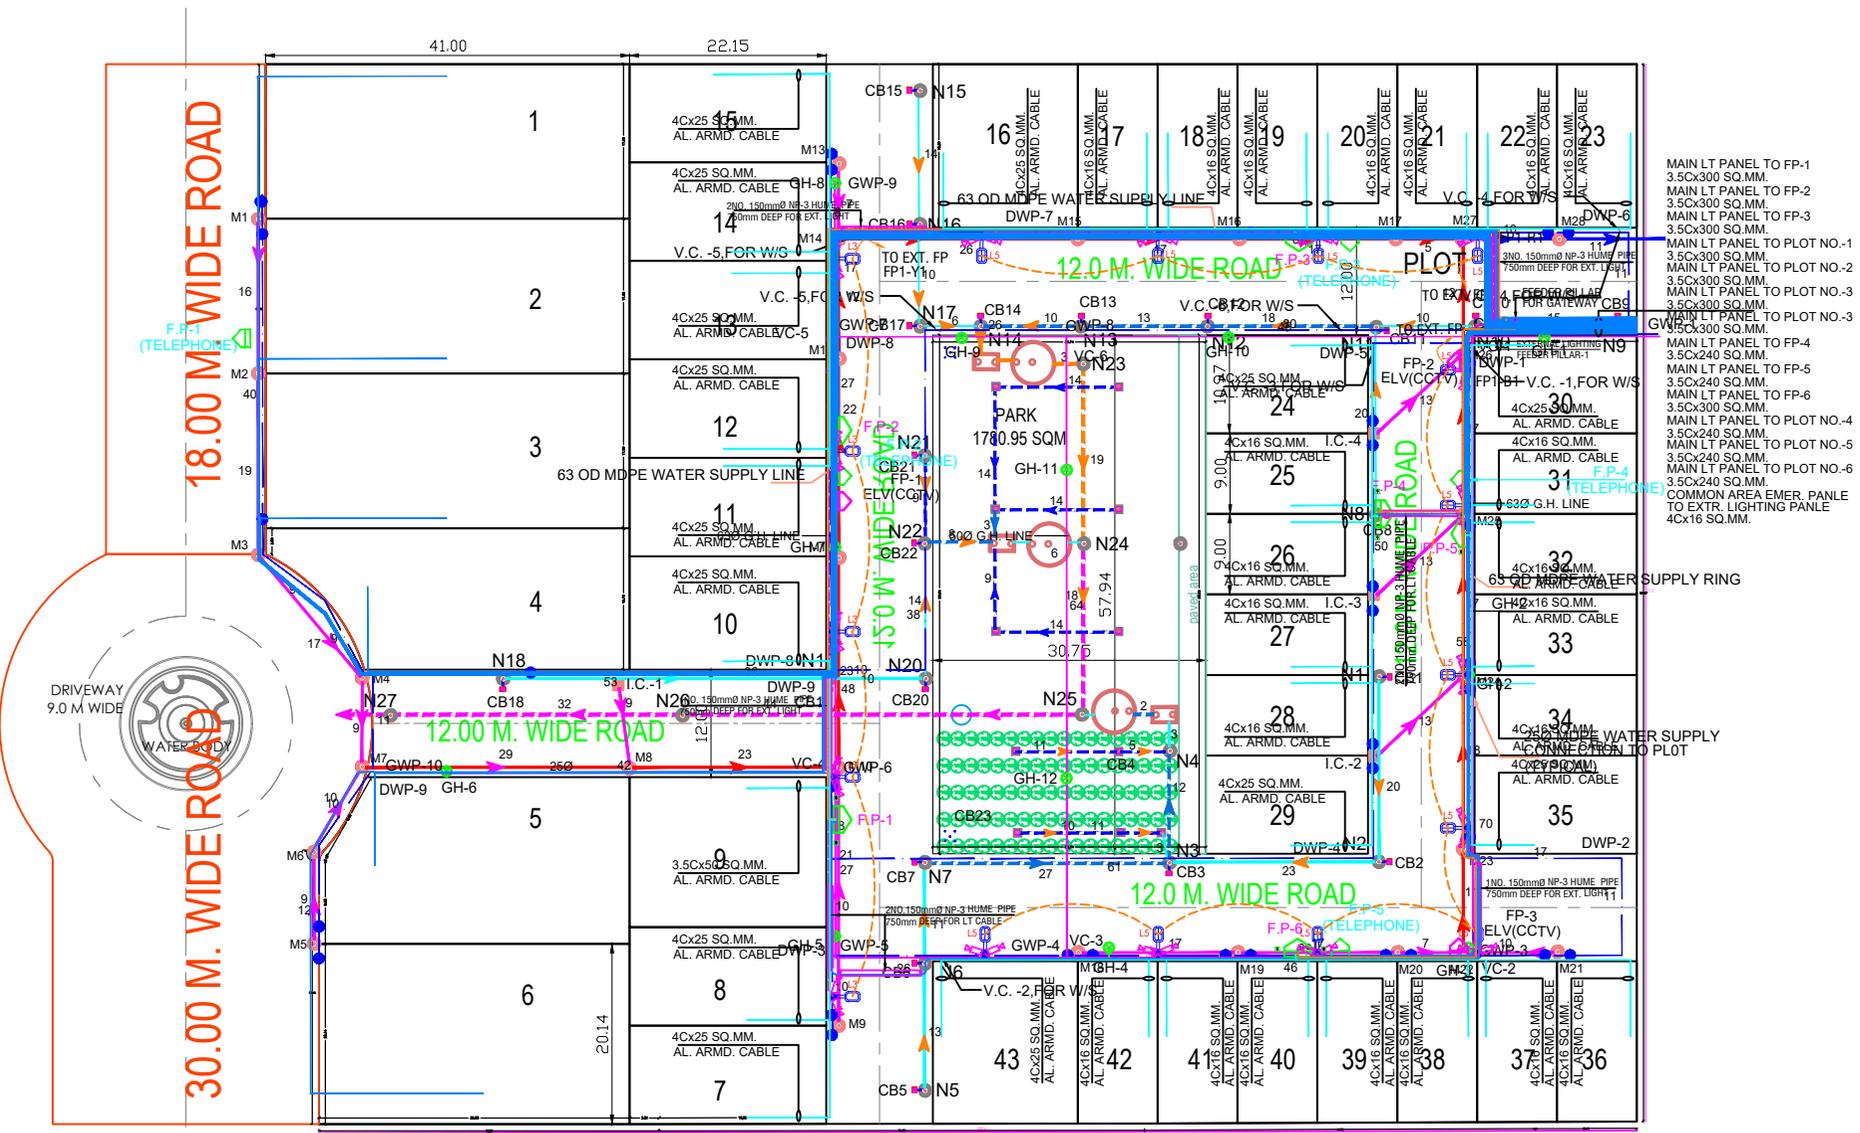

MAIN LT PANEL TO FP-1
 3.5Cx300 SQ.MM
 MAIN LT PANEL TO FP-2
 3.5Cx300 SQ.MM
 MAIN LT PANEL TO PLOT NO.-1
 3.5Cx300 SQ.MM
 MAIN LT PANEL TO PLOT NO.-2
 3.5Cx300 SQ.MM
 MAIN LT PANEL TO PLOT NO.-3
 3.5Cx300 SQ.MM
 MAIN LT PANEL TO PLOT NO.-4
 3.5Cx240 SQ.MM
 MAIN LT PANEL TO PLOT NO.-5
 3.5Cx240 SQ.MM
 MAIN LT PANEL TO PLOT NO.-6
 3.5Cx240 SQ.MM
 COMMON AREA EMER. PANLE
 TO EXTR. LIGHTING PANLE
 4Cx16 SQ.MM.