
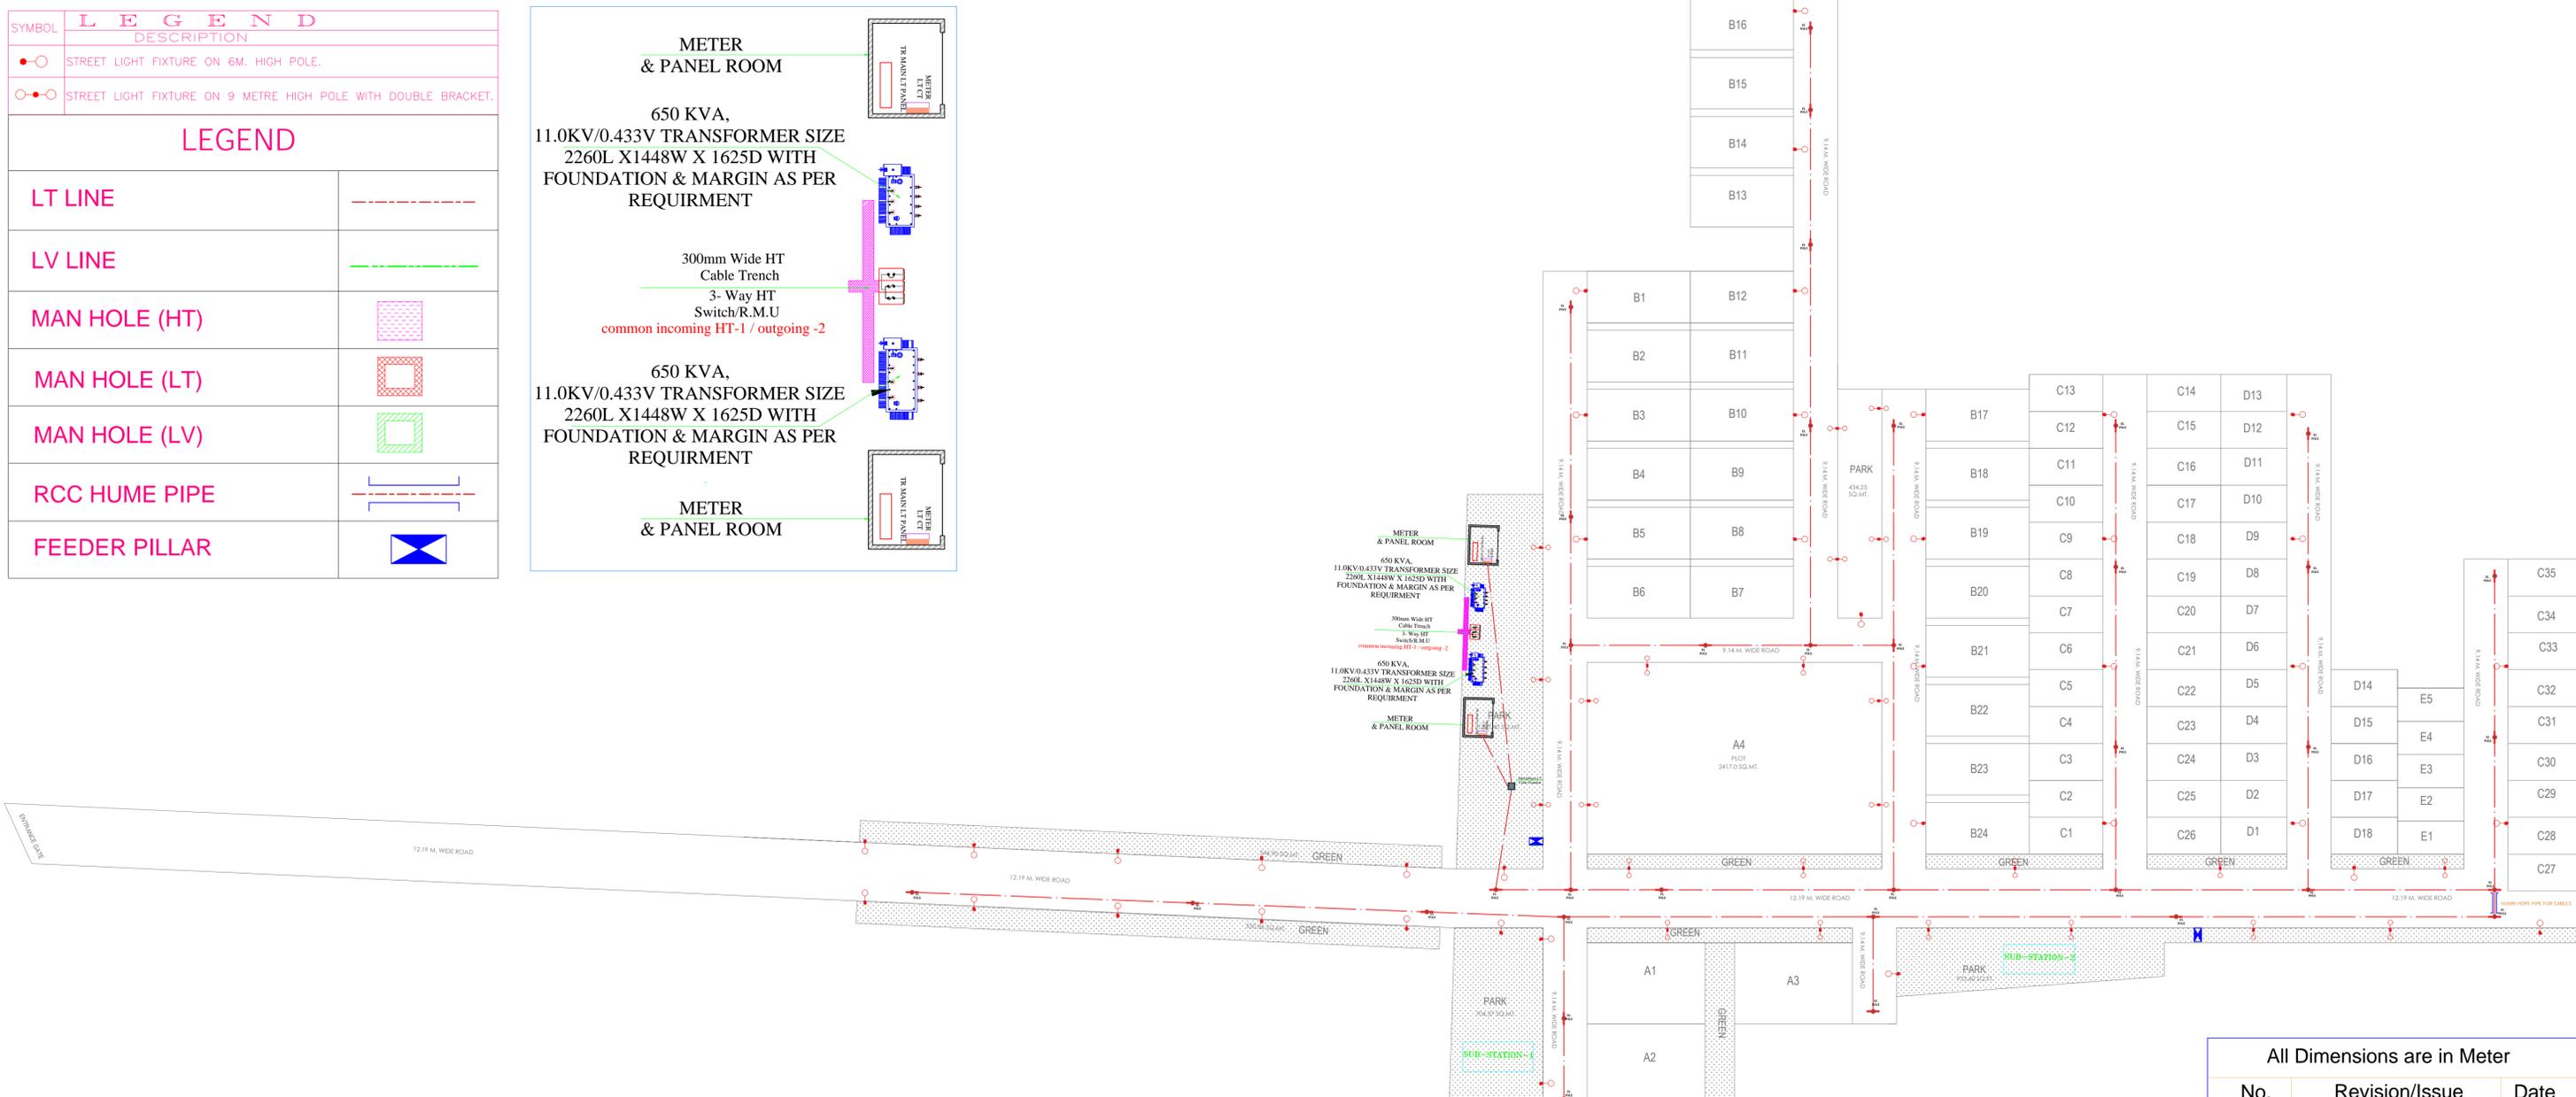


SYMBOL	DESCRIPTION
	STREET LIGHT FIXTURE ON 6M. HIGH POLE.
	STREET LIGHT FIXTURE ON 9 METRE HIGH POLE WITH DOUBLE BRACKET.

LEGEND	
LT LINE	
LV LINE	
MAN HOLE (HT)	
MAN HOLE (LT)	
MAN HOLE (LV)	
RCC HUME PIPE	
FEEDER PILLAR	

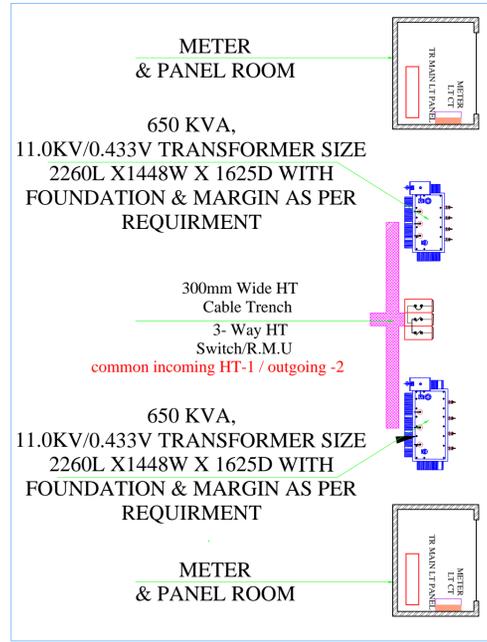

All Dimensions are in Meter		
No.	Revision/Issue	Date
Project	Plotted Housing	North
Drawn By	VIKAS	
Checked By	SACHIN	
Date	FEB. 2025	
Scale	As Mentioned	

Owner's Name and Address

PROJECT TITLE :PROPOSED LAYOUT PLAN FOR FLORET TOWN
GATA NO- 41/2, 43, 70, 282/1, 282/2, 282/3,282/4, 282/5, 282/6, 283, 284,
285, 287, 290, F.B. INFRA DEVELOPERS L.L.P. PARTNER Mr. SANTOSH
KUMAR SINGH S/O KAMAL BAHADUR SINGH
SITUATEDAT-VILL.-MATI,PARGAN-DEWA,TEHSIL.-NAWABGANJ,
DIST.-BARABANKI (U.P)

Owner Sign.

Architect

ELECTRICAL LAYOUT PLAN