

LEGEND FOR SEWERAGE LINE:-

	SEWER LINE
	SEWER MANHOLE SIZE: 900X900MM
	SEWER MANHOLE SIZE: 900/1500 DIA.
	GALLY TRAP SIZE: 300X300MM

SIZE OF MANHOLE WITH REFERENCE TO DEPTH

DEPTH	SIZE OF MH
0.90m TO 1.65m	800mm DIA.
1.7m TO 2.20m	1200mm DIA.
Beyond 2.30m	1500mm DIA.

GOOD FOR CONSTRUCTION

No.	Date	Description

CLIENT NAME: GOLF GREEN INFRA. PVT.LTD

PROJECT: MAHAGUN MIRABELLA
SECTOR-73/INDIA

STRUCTURAL CONSULTANT: MAHIMTURA CONSULTANTS PVT.LTD

LANDSCAPE CONSULTANT: TAB STUDIO

STATUS: _____


TITLE: SITE PLAN

SUB TITLE: ELECTRICAL LAYOUT

Building Services/MEP Consultants
SNC
MEP Consulting Engineers
Sunil Nayyar Consultants Pvt. Ltd.
Head Office : 206- 206A & 305A-305B, 2nd & 3rd Floor,
Time Centre, DLF Golf Course Road,
Sector-54, Gurgaon-122002, Haryana (India)
Tale : +91-124-4803000 (30 Lines)
Fax : +91-124-4803817
E-mail : sncgurgaon@snc.co.in
URL : www.snc.co.in
D Datta M Gargan

Project	MAHAGUN MIRABELLA	DRG. NO.	
Scale	1:250 @ A1		
Date	07.07.2016		
DRN. BY	SANDEEP		
CHKD. BY	A.N		
Issue			

Architect
Hafeez Contractor
29 Blank Street, Bombay 23, Tel: +91 22 23661999
www.hafeezcontractor.com
www.architecthafeezcontractor.com
email: hafeez@hafeezcontractor.com

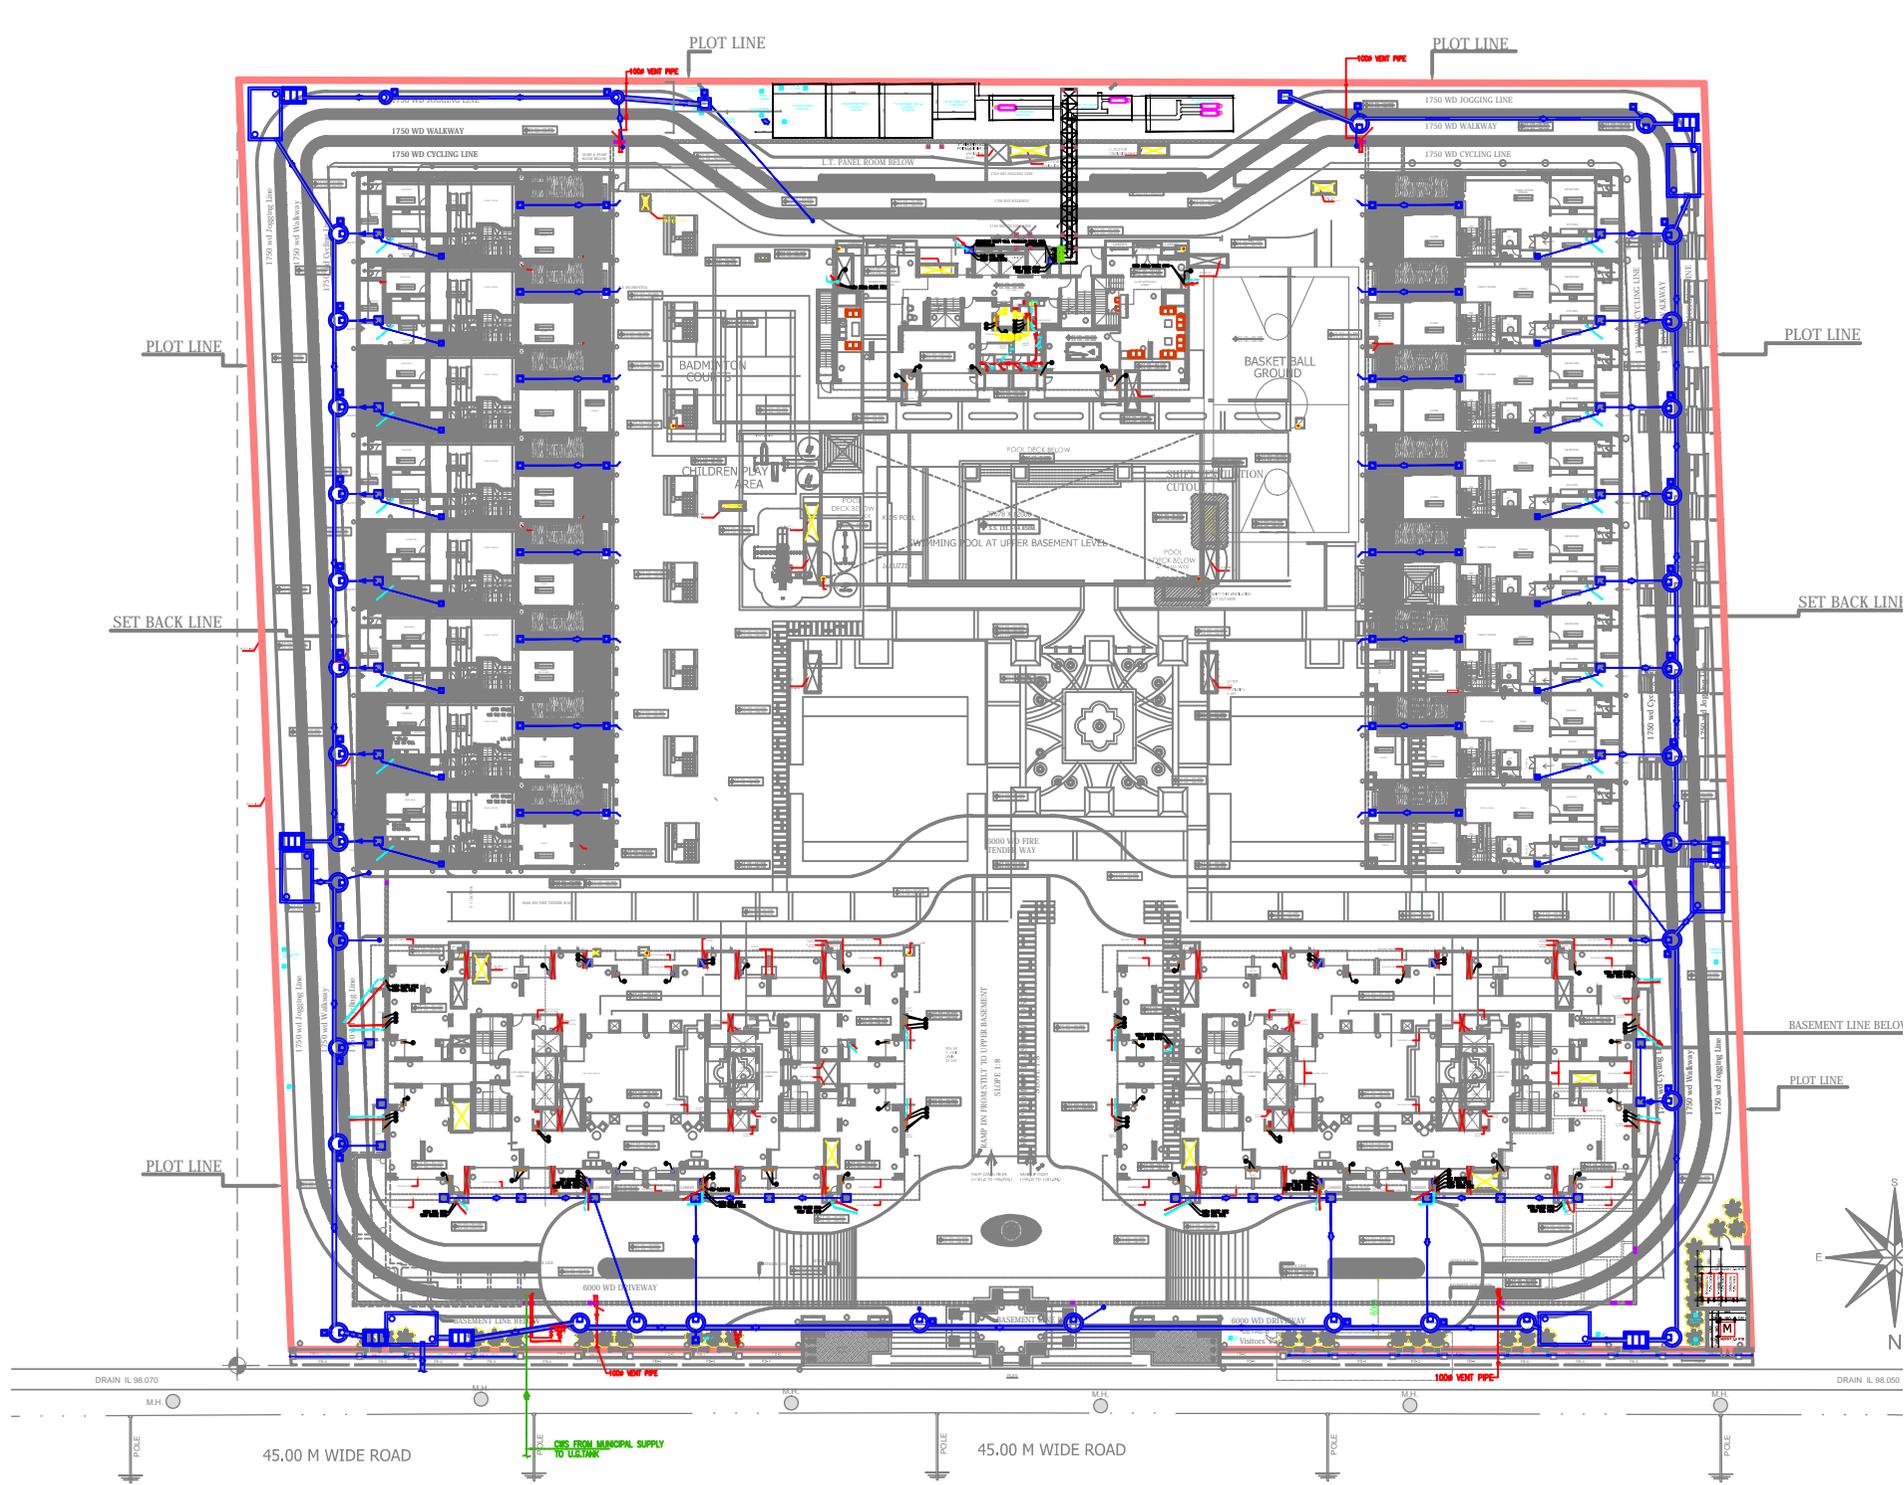

45.00 M WIDE ROAD

45.00 M WIDE ROAD

CHS FROM MUNICIPAL SUPPLY TO ULTRAK

DRAIN IL 98.070

DRAIN IL 98.050