


This drawing is a "COPYRIGHT" contents of this drawing or part thereof may not be used or reproduced without the permission of the Architect



- NOTES**
1. ALL DIMENSIONS ARE IN MM UNO
  2. ONLY WRITTEN DIMENSIONS ARE TO BE READ
  3. ALL WALLS ARE 200MM & 100MM THK. AAC BLOCK WORK UNLESS OTHERWISE MENTIONED.
  4. THIS DRAWING IS TO BE READ IN CONJUNCTION WITH RELEVANT STRUCTURAL/SERVICE DRAWINGS. ANY DISCREPANCY MUST BE BROUGHT TO THE NOTICE OF ARCHITECT.

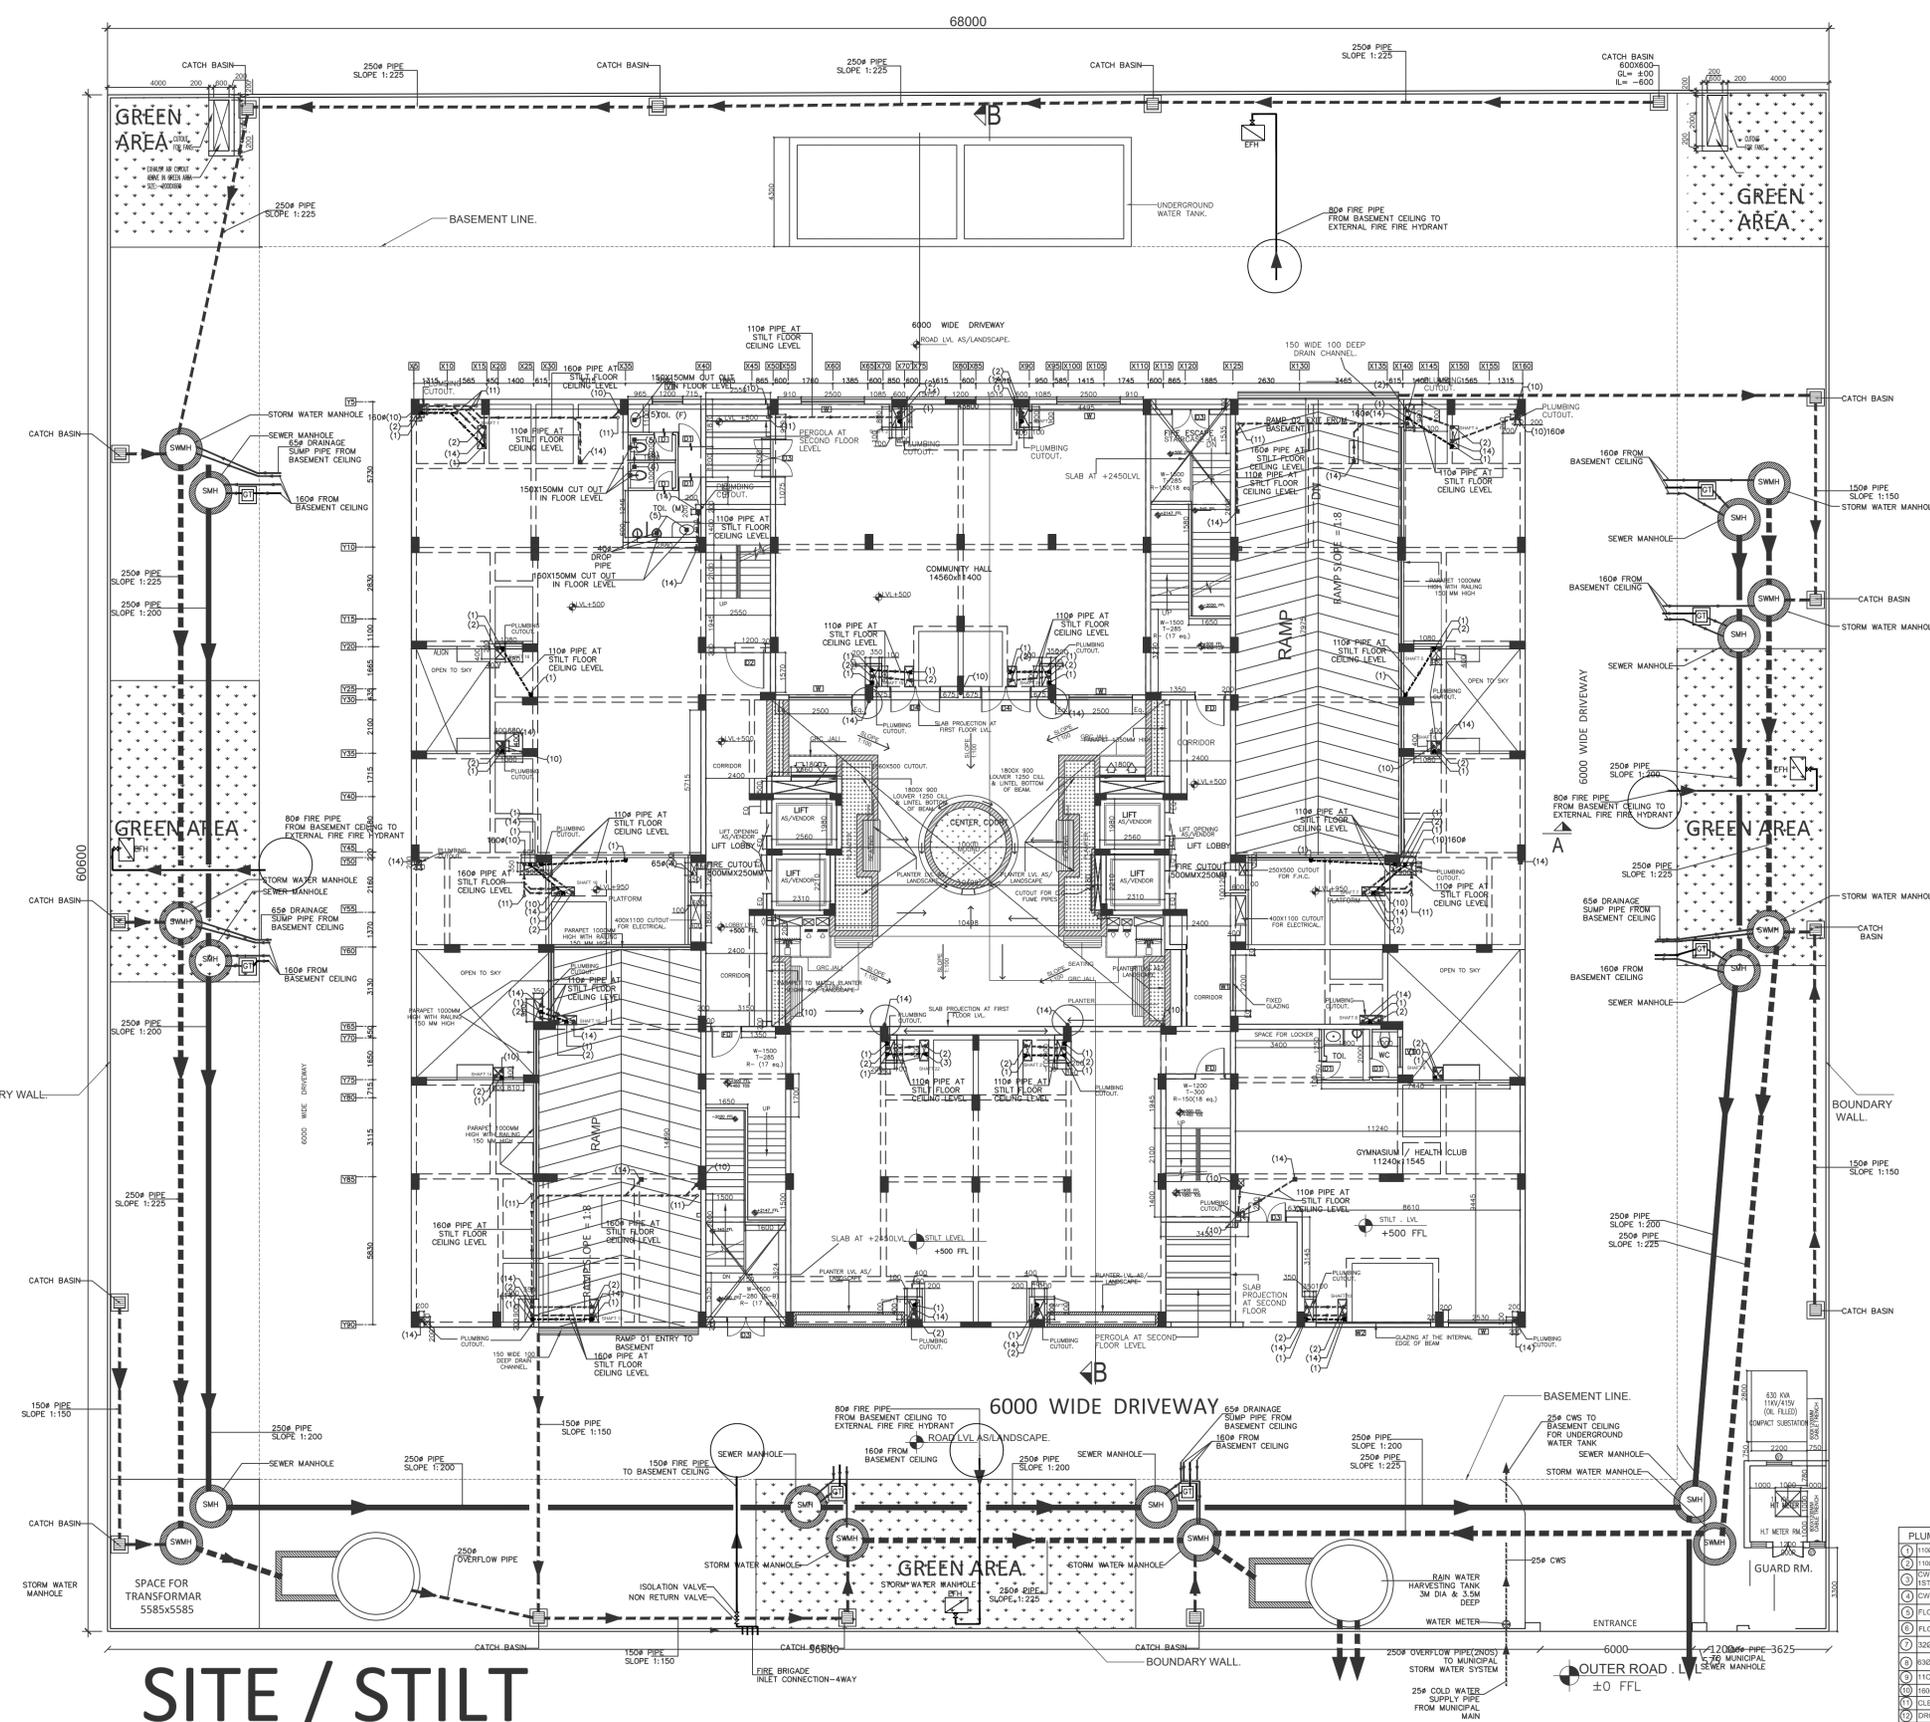

# SITE / STILT

**PLUMBING LEGEND:-**

(1)	1100 WASTE & VENT PIPE
(2)	1100 SOIL & VENT PIPE
(3)	2500 DROPPING PIPE FOR 10TH TO 11TH FLOOR
(4)	450 RISER TO OHT
(5)	FLOOR TRAP
(6)	FLOOR DRAIN 100X83MM
(7)	520 FLEXIBLE PIPE
(8)	43000 WASTE WATER PIPE
(9)	1100 OD PIPE
(10)	1000MM WATER PIPE
(11)	CLEANOUT PLUG
(12)	DROPP CONNECTION
(13)	750 OD ANTISIPHONAGE PIPE
(14)	1000X1000X1000 JACOBY W.H.P.
(15)	4500 DROPPING PIPE FOR 12TH & 13TH FLOOR
(16)	400 WATER SUPPLY FROM FLOOR SYSTEM TO 12TH & 13TH FLOOR FOR TOILET & KITCHEN

REVISION	DESCRIPTION	DATE

ARCHITECT / STRUCTURE CONSULTANT.

**PAESAGGIO**

paesaggio Consulting Services Pvt Ltd  
011- 41582244 N3 Green Park Main  
New Delhi -16

CLIENT.

**SHREY JAIN AND SHREE HARI REALTECH PVT. LTD.**

PROJECT

LUVNEST  
PLOT NO.- 11/G.H.-3, SECTORE-11  
VRINDAVAN YOJNA NO. 3  
LUCKNOW.

DRAWING TITLE

**SITE PLAN-EXTERNAL SANITARY & FIRE FIGHTING SERVICES**

DEALT BY	CHECKED BY	APPROVED BY
PC	PC	VG

SCALE	DATE	REVISION
NTS	18.08.2017	R0

DRAWING NUMBER