

PROPOSED EWS LIG FOR PINTAIL REALTY DEVELOPERS PVT LTD at PINTAIL REALTY DEVELOPERS PVT LTD, PARK CITY, INTEGRATED TOWNSHIP, BAKKAS, MOHANLAL GANJ, LUCKNOW

ELECTRICITY SUPPLY SITE PLAN


DATE	SCALE	REVISION	SHEET NO.
05/09/22		R0	01
DRAWING NO.	SHEET SIZE		
	A1		

NOTE

- 1) ALL DIMENSIONS ARE IN MILLIMETERS
- 2) NO DIMENSION TO BE SCALED FROM THE DRAWINGS WRITTEN DIMENSIONS TO BE FOLLOWED
- 3) IN CASE OF DISCREPANCY LARGE SCALE DETAILED DRAWINGS SHALL SUPERSEDE SMALLER SCALE DRAWINGS AND DISCREPANCIES IN THE DRAWINGS ARE TO BE BROUGHT OUT TO THE NOTICE OF THE ARCHITECT IT IS GOT TO BE RECTIFIED BEFORE TENDERING.
- 4) ALL SERVICES OWNS TO BE REFERRED ONLY FOR THE TECHNICAL CONTENT OF THE PROJECT WORKING DRAWINGS TO BE FOLLOWED FOR ALL WORK AT SITE.
- 5) ALL STRUCTURAL SIZES AND STRUCTURAL DETAILS TO BE REFERRED FROM DRAWINGS OF STRUCTURAL CONSULTANTS.

LEGEND:- (Plumbing)

S.NO.	SYMBOL	DESCRIPTION	SIZE IN MM.
1.		MANHOLE FOR RAIN WATER HARVESTING	600X600
2.		MANHOLE FOR FOR SOLID WASTE PIPE	900X800

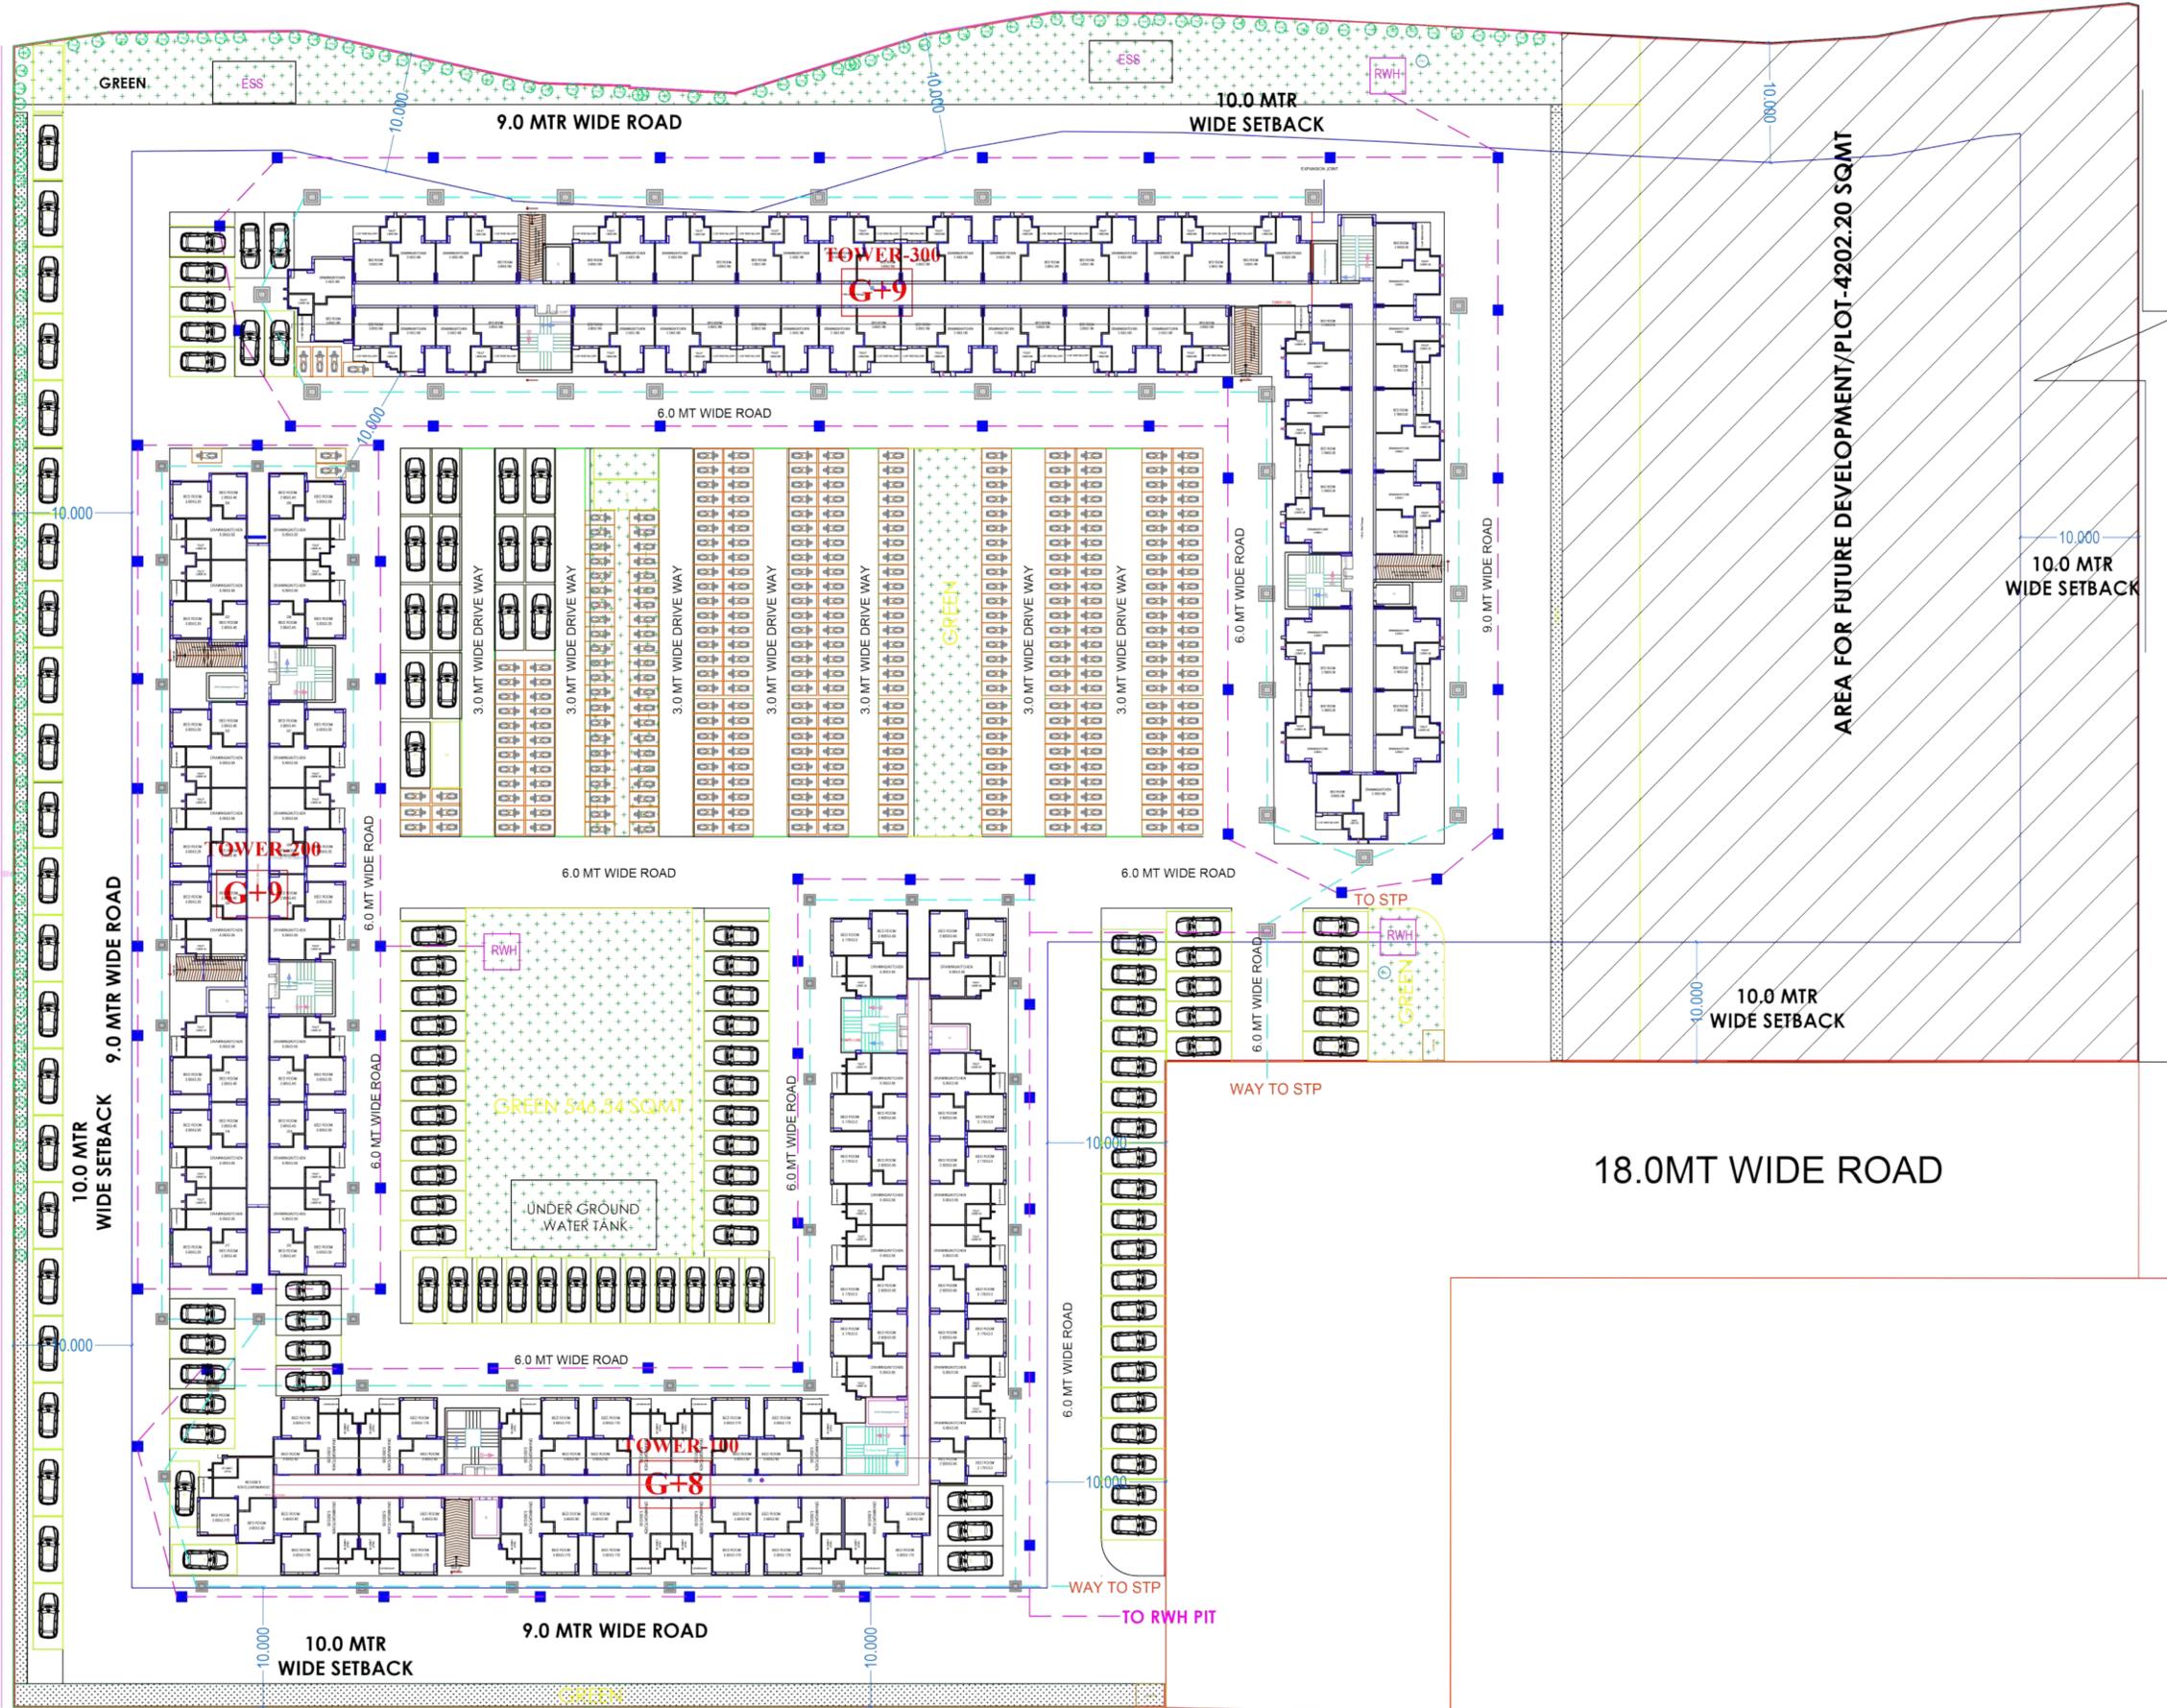

AREA FOR FUTURE DEVELOPMENT/PLOT-4202.20 SQMT

18.0MT WIDE ROAD

SITE PLAN

architect's avenue
D-2/122,Sambhav Tower,Vibhuti
Khand Gombi Nagar,Lucknow,U.P.

ARCHITECT



OWNER