


LEGEND:-	
SYMBOL	DESCRIPTION
	SWITCH BOARD
	6AMP SWITCH & SOCKET
	6/16AMP SWITCH & SOCKET
	6/16AMP SWITCH & SOCKET FOR HAND DRYER
	10W BULK HEAD LIGHT
	10W LED CEILING LIGHT
	MIRROR LIGHT
	MANUAL CALL POINT
	HOOTER WITH STROBE
	DISTRIBUTION BOARD
	LOOPING FOR NORMAL LIGHT
	EARTHING G.I STRIP
	EARTHING DOWN TAKE
	FIRE ALARM CONTROL PANEL

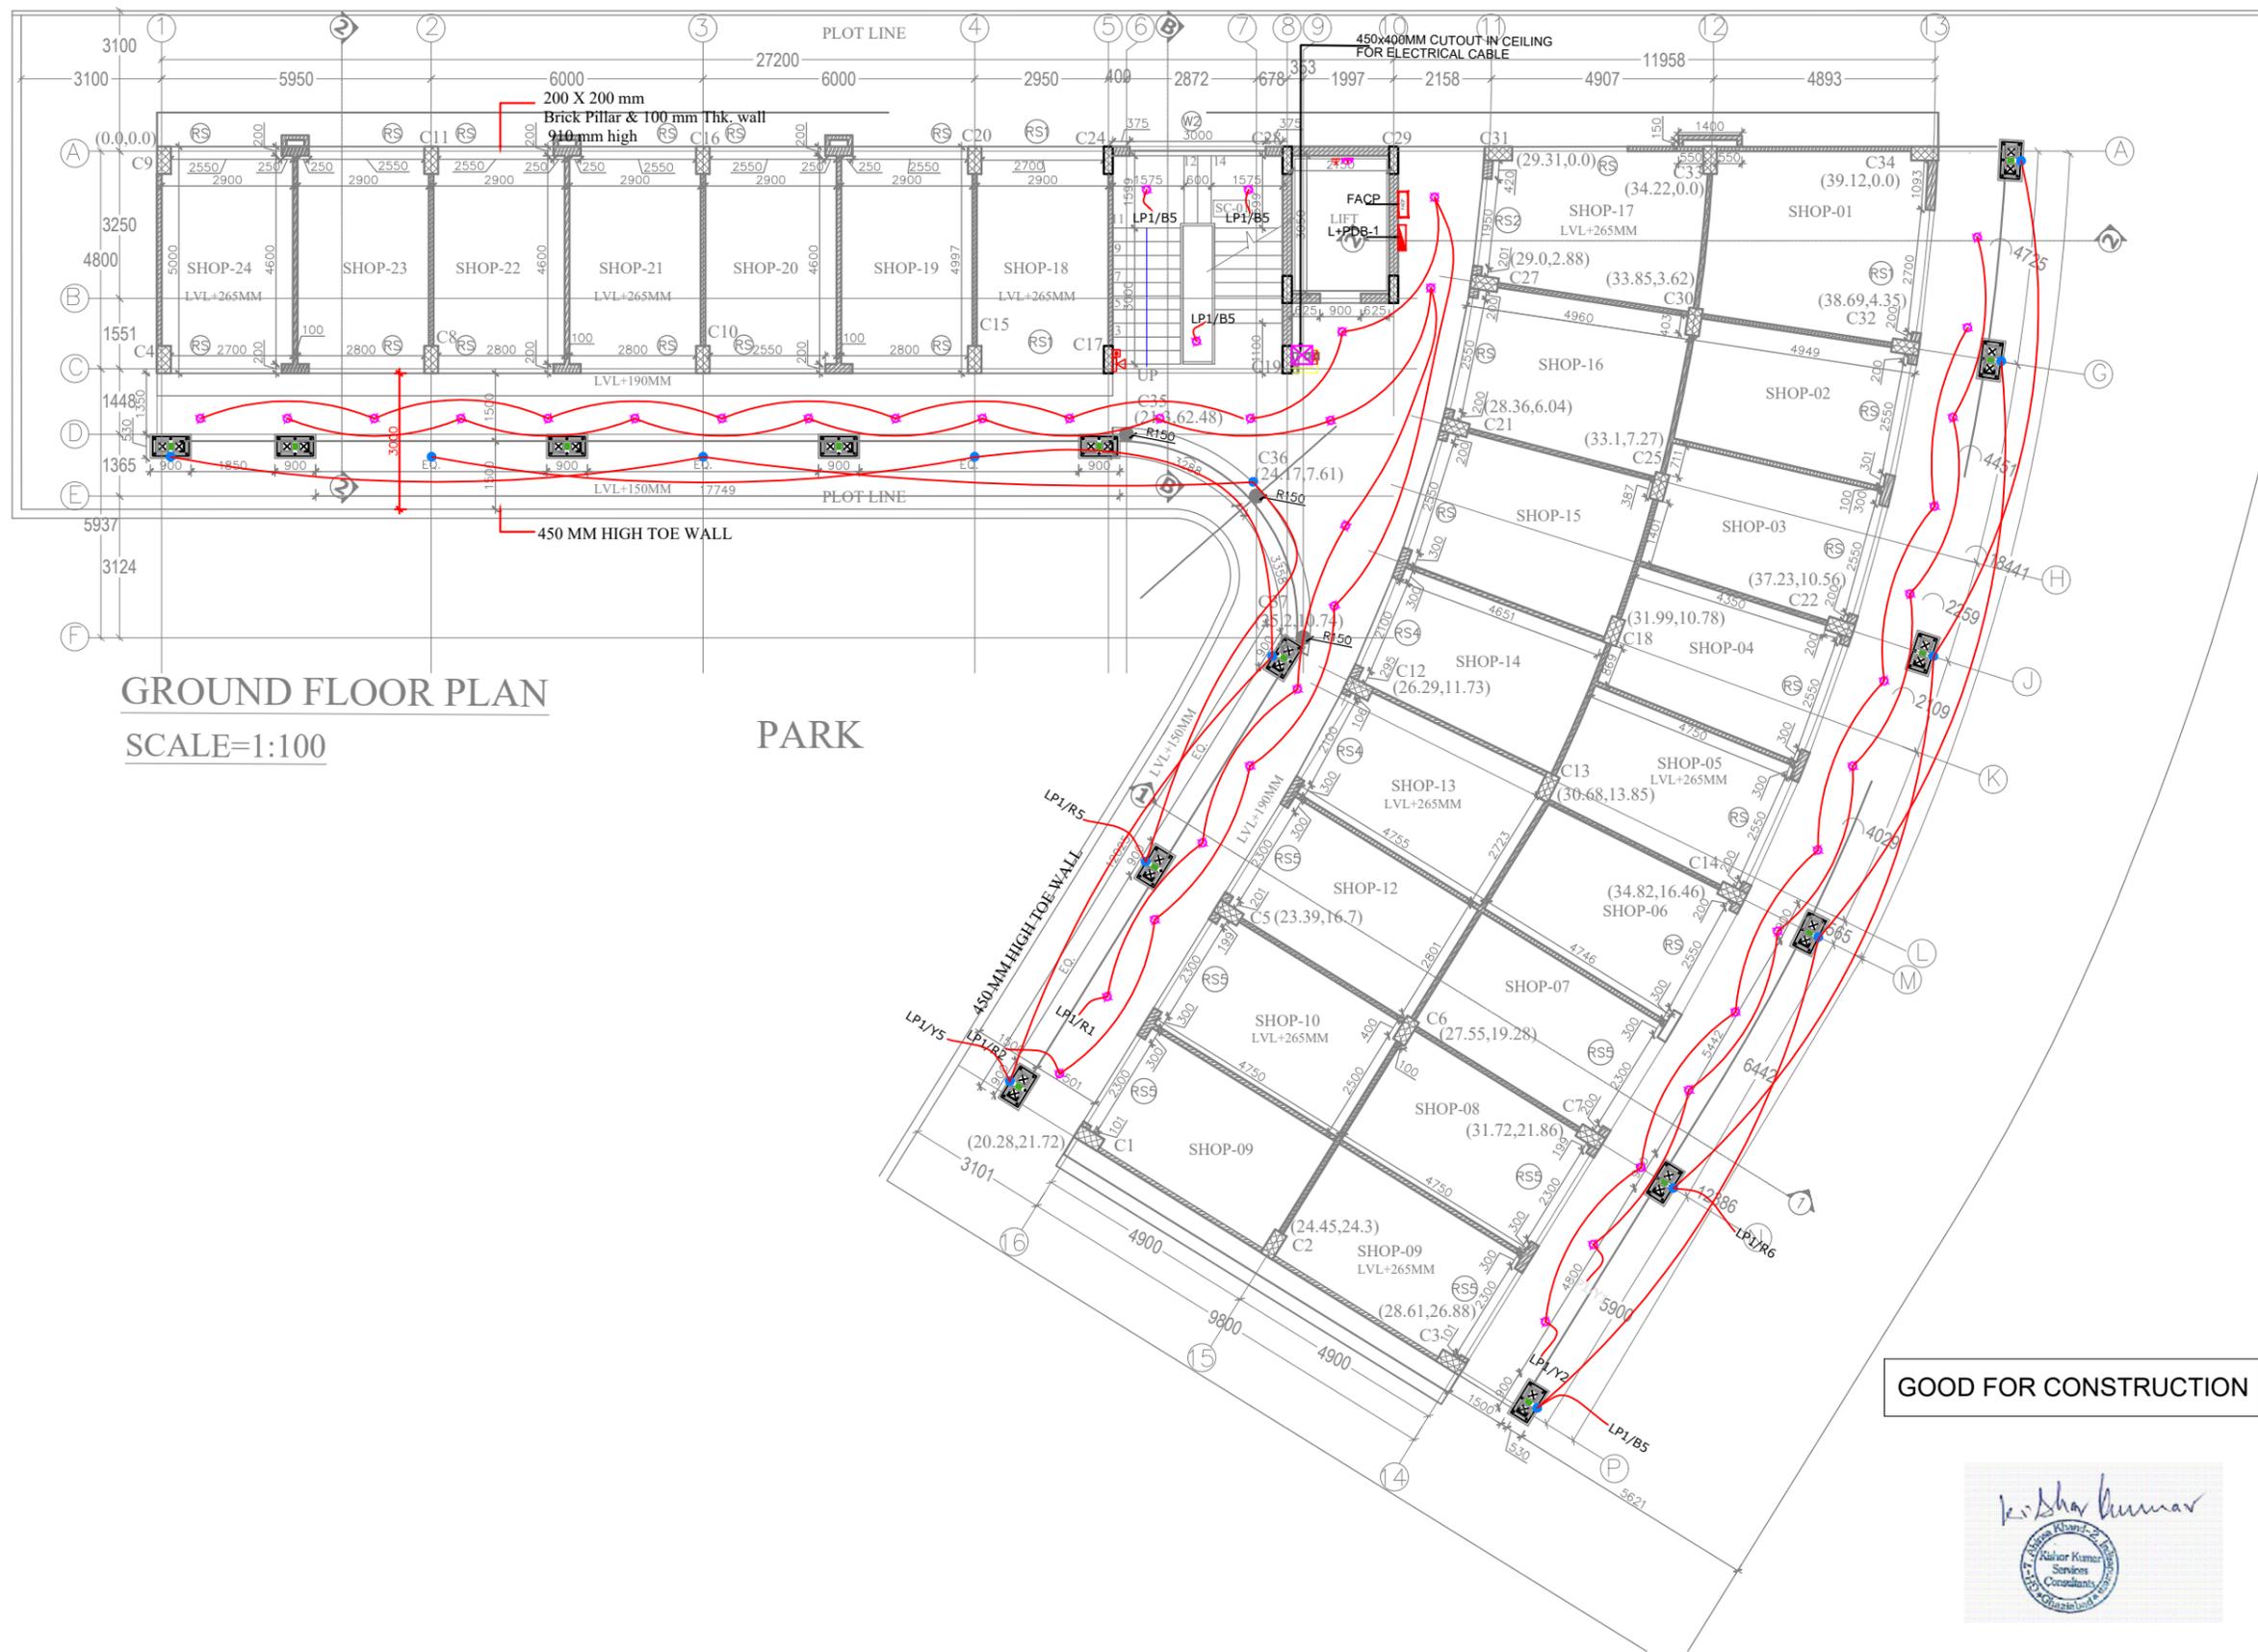

GROUND FLOOR PLAN
SCALE=1:100

PARK

GOOD FOR CONSTRUCTION

Kishor Kumar
Kishor Kumar Services Consultants

ARCHITECT:- Ar. SAMIR CHAKRAVORTY
DRAWN BY:- Ar. NIVEDITA TIWARI

OWNER and DEVELOPER :-
J.K. COTTON LTD.
FORMLY KNOWN AS J.K. Cotton Spinning And Weaving Mill,
Dwarkadheesh Temple Road,
Kamla Tower, Kanpur

ELECT & PLUMBING CONSULTANT:-
KKSC
KISHOR KUMAR SERVICES CONSULTANTS
007-PINNACLE TOWER, GH-7, AHINSA KHAND-2, INDRAPURAM, GHAZIABAD, UP-201014
PHONE: +91 120 4132558 MOBILE: +91 9910487835 kksco101@gmail.com


Project:-
PROPOSED BUILDING PLAN FOR CONVENIENT SHOPS AT EMERALD GULISTAN, J.K.RAYON, JAJMAU, KANPUR.

DRAWING TITLE
GROUND FLOOR ELECTRICAL LIGHTING & FIRE ALARM LAYOUT

DRAWN BY PARDDEP	DATED 16-02-2022
CHECKED BY R.D	SCALE A-1/75

APPROVED BY. K.K	DRG.No. KKSC/JK.C./CS/EL-01
----------------------------	---------------------------------------

LEGEND:-	
SYMBOL	DESCRIPTION
	TELEPHONE TAG BLOCK
	POWER MCB BOX
	ELECTRICAL CONDUIT
	ELECTRICAL CABLE TRAY
	LV CABLE TRAY
	FIRE ALARM CONTROL PANEL
	MANUAL CALL POINT
	HOOTER WITH STROBE
	DISTRIBUTION BOARD

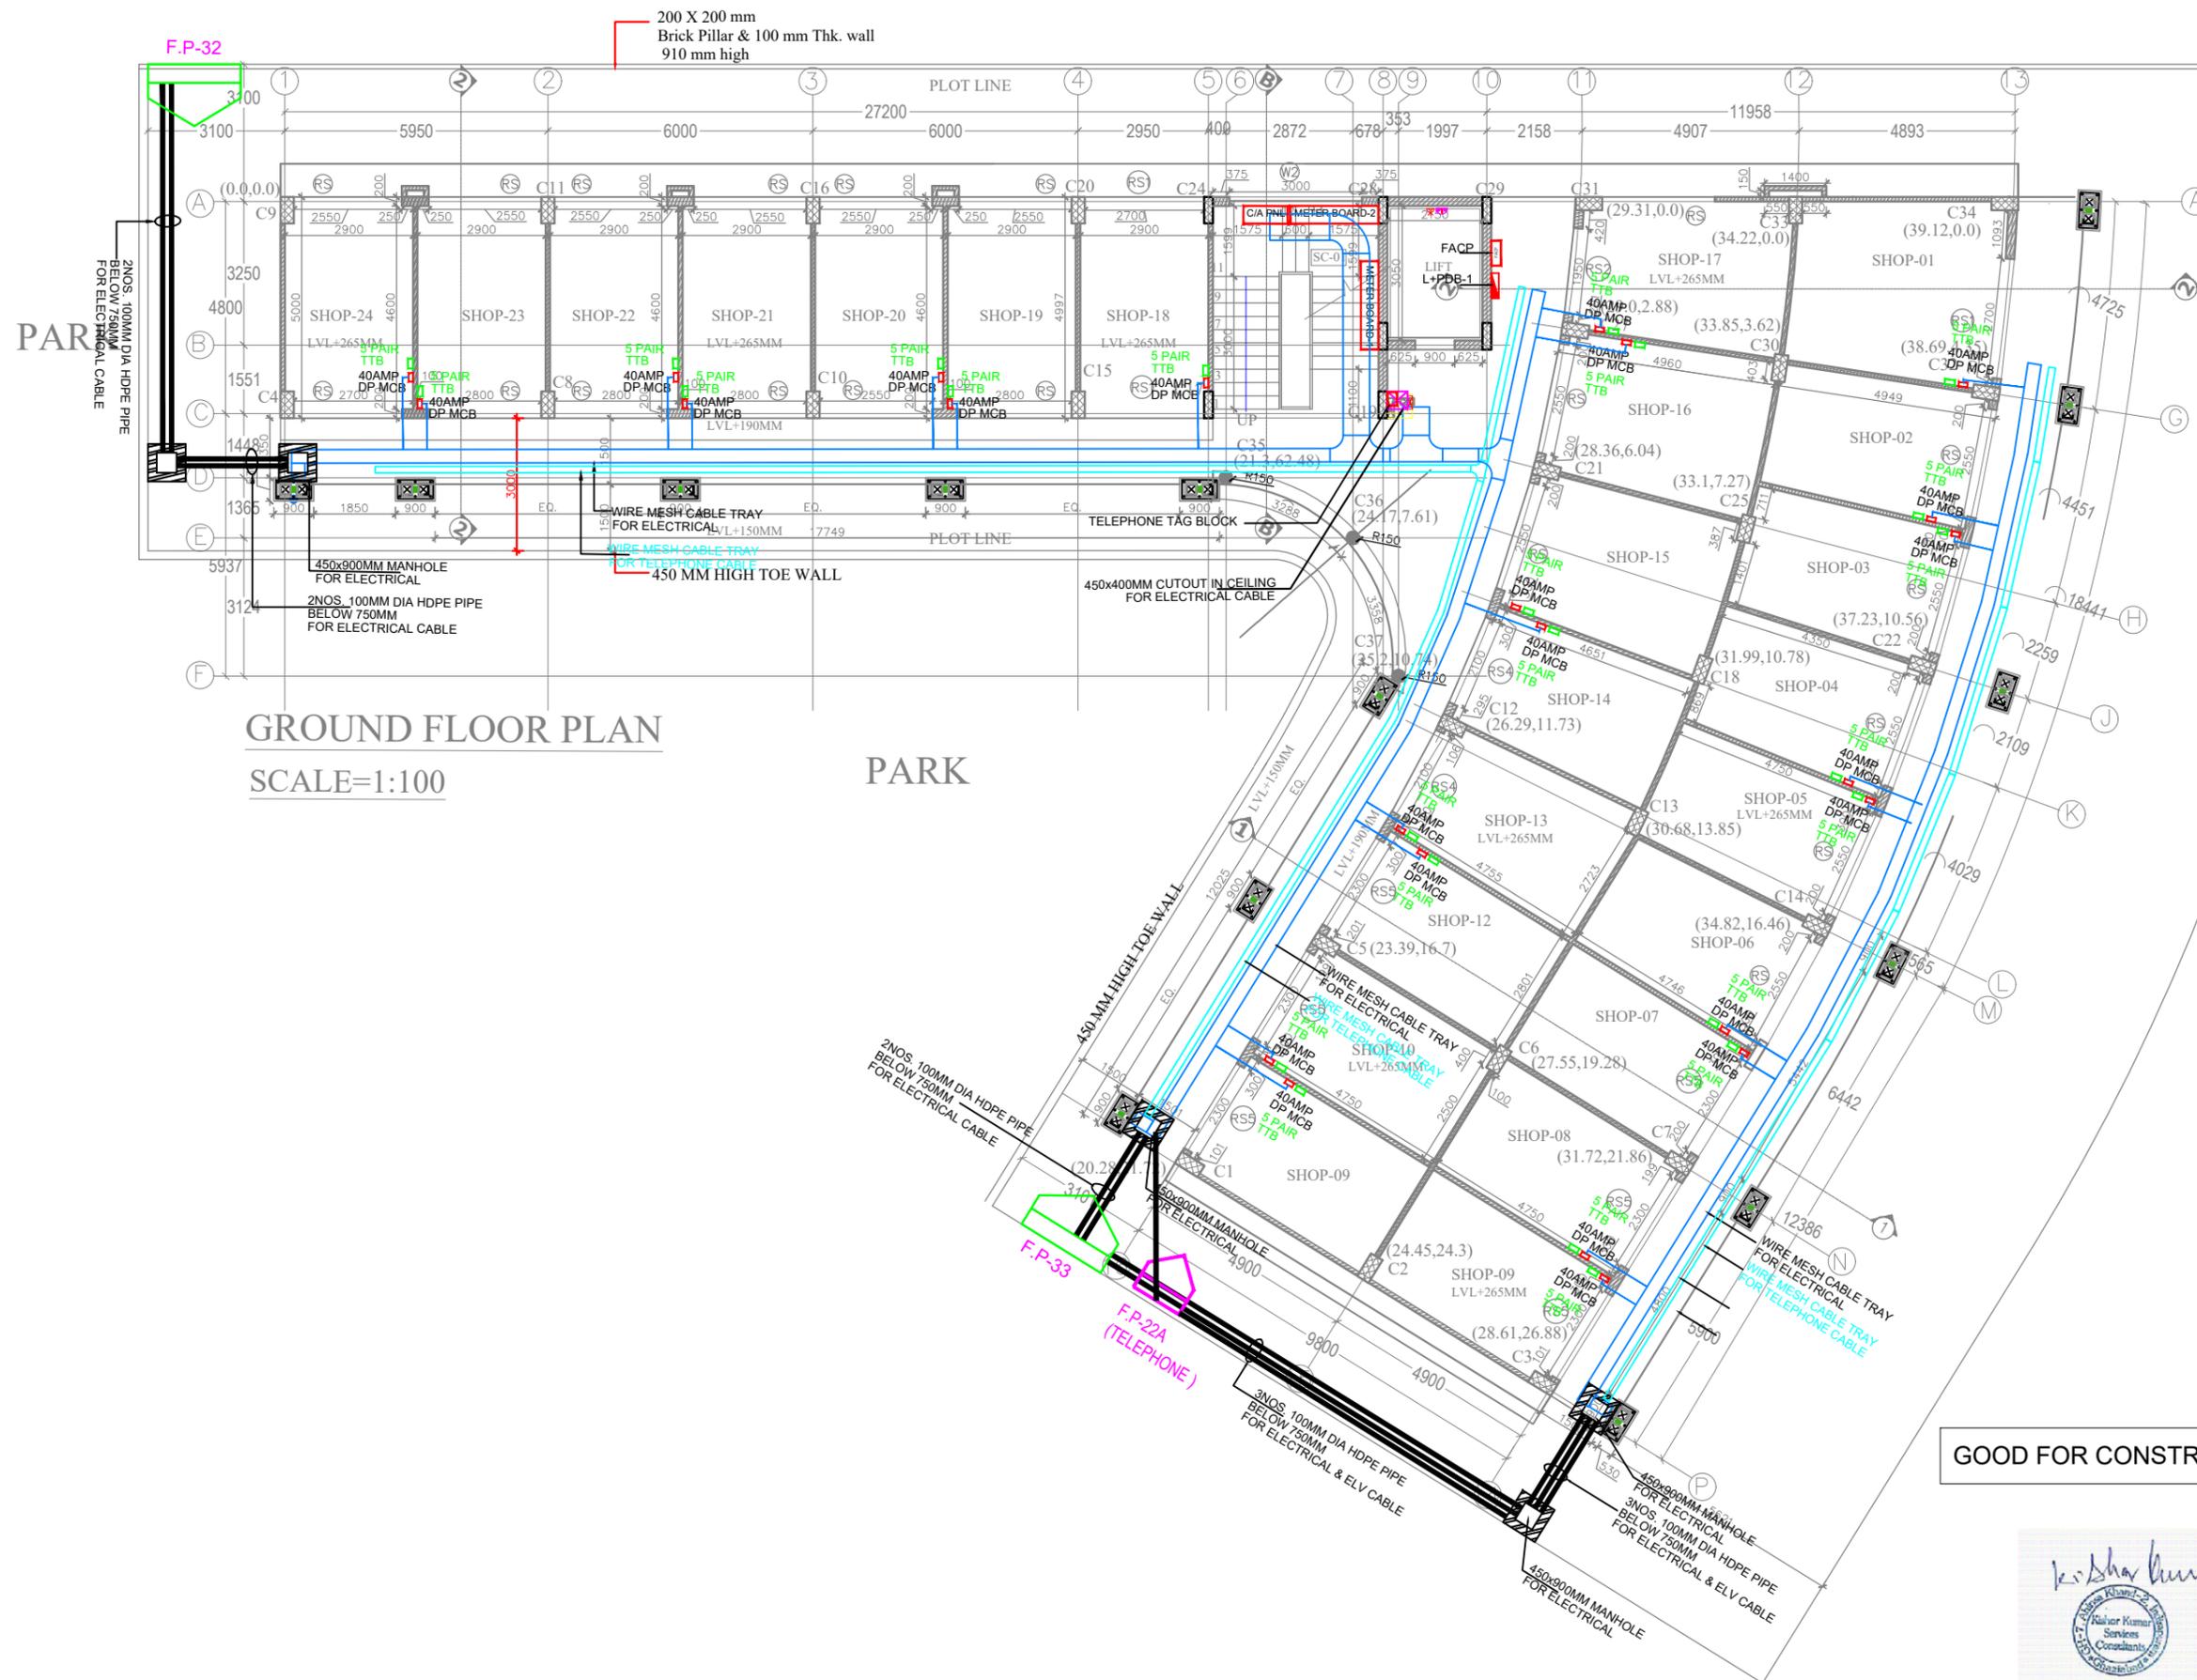

GROUND FLOOR PLAN
SCALE=1:100

PARK

GOOD FOR CONSTRUCTION



ARCHITECT:- Ar. SAMIR CHAKRAVORTY
DRAWN BY:- Ar. NIVEDITA TIWARI

OWNER and DEVELOPER :-
J.K. COTTON LTD.
FORMLY KNOWN AS J.K. Cotton Spinning And Weaving Mill,
Dwarkadheesh Temple Road,
Kamla Tower, Kanpur

ELECT & PLUMBING CONSULTANT:-
KKSC
KISHOR KUMAR SERVICES CONSULTANTS
007-PINNACLE TOWER, GH-7 AHINSA KHAND-2, INDRAPURAM GHAZIABAD, UP-201014
PHONE: +91 120 4132558 MOBILE: +91 9910487835 kksco101@gmail.com

Project:-
PROPOSED BUILDING PLAN FOR CONVENIENT SHOPS AT EMERALD GULISTAN, J.K.RAYON, JAJMAU, KANPUR.

DRAWING TITLE
GROUND FLOOR ELECTRICAL CABLE TRAY LAYOUT

DRAWN BY
PARDDEP


DATED
16-02-2022

CHECKED BY
R.D

SCALE
A-1/75

APPROVED BY
K.K

DRG.No.
KKSC/JK.C./CS/CT-01

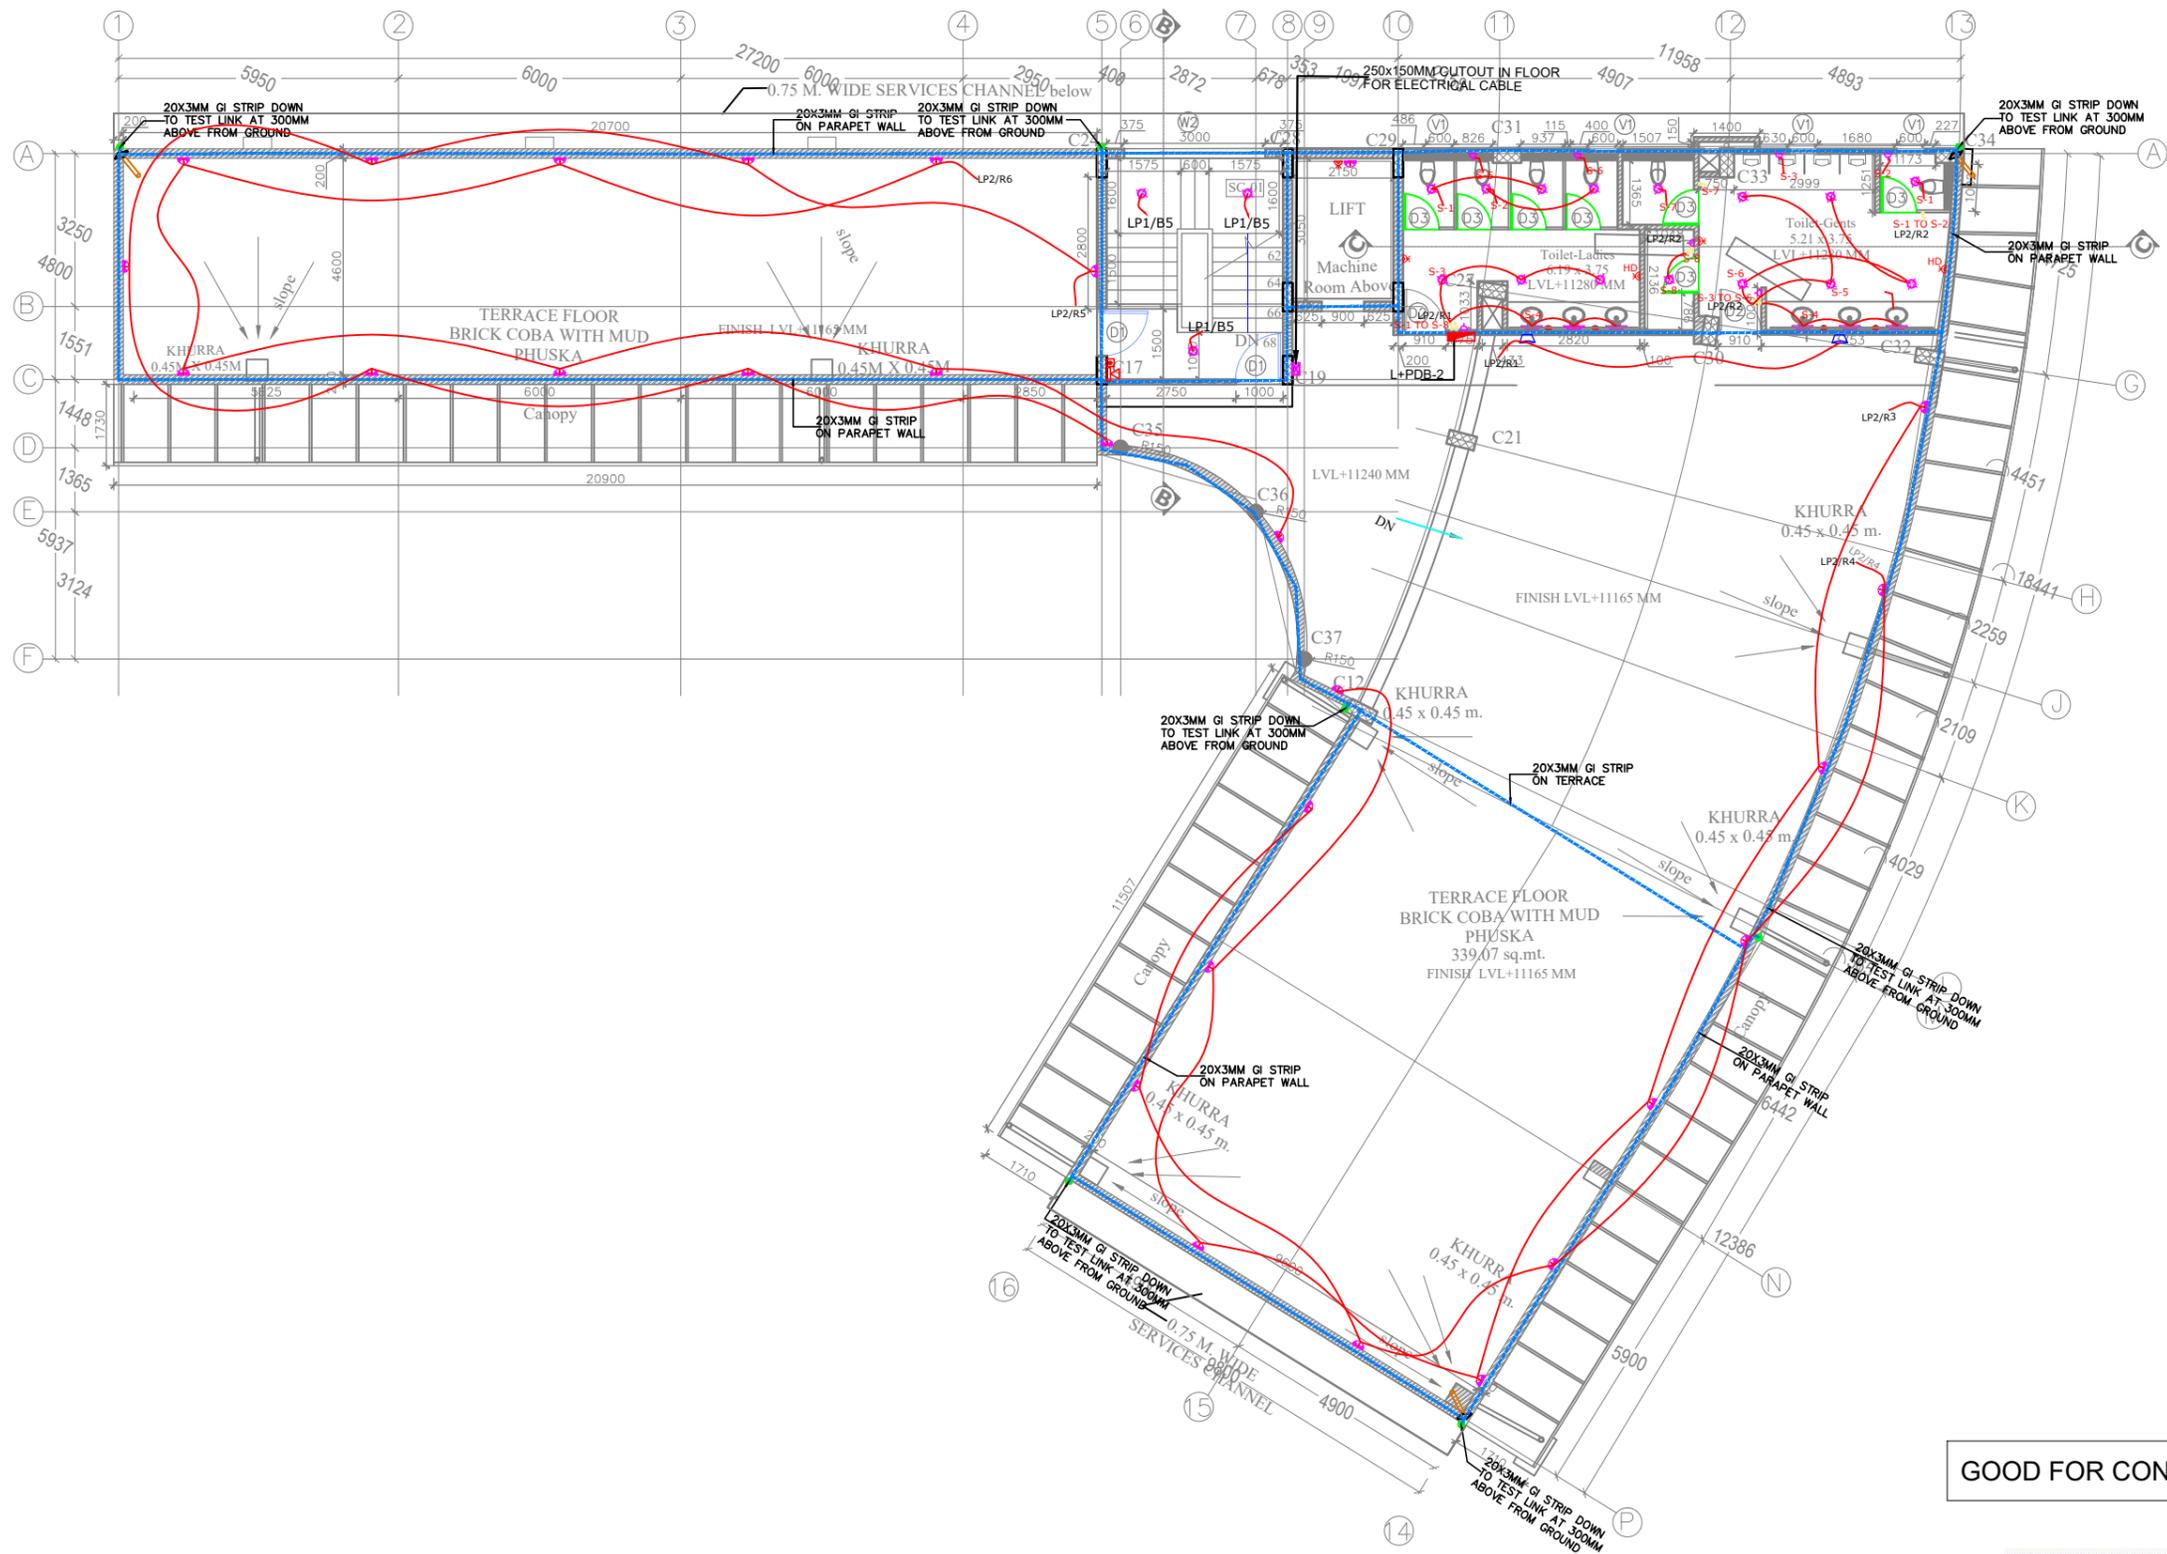

LEGEND:-	
SYMBOL	DESCRIPTION
[Symbol]	SWITCH BOARD
[Symbol]	6AMP SWITCH & SOCKET
[Symbol]	6/16AMP SWITCH & SOCKET
[Symbol]	6/16AMP SWITCH & SOCKET FOR HAND DRYER
[Symbol]	10W BULK HEAD LIGHT
[Symbol]	10W LED CEILING LIGHT
[Symbol]	MIRROR LIGHT
[Symbol]	MANUAL CALL POINT
[Symbol]	HOOTER WITH STROBE
[Symbol]	DISTRIBUTION BOARD
[Symbol]	LOOPING FOR NORMAL LIGHT
[Symbol]	EARTHING G.I STRIP
[Symbol]	EARTHING DOWN TAKE
[Symbol]	FIRE ALARM CONTROL PANEL

ARCHITECT:- Ar. SAMIR CHAKRAVORTY
 DRAWN BY:- Ar. NIVEDITA TIWARI

OWNER and DEVELOPER :-
J.K. COTTON LTD.
 FORMLY KNOWN AS J.K. Cotton Spinning And Weaving Mill,
 Dwarkadheesh Temple Road,
 Kamla Tower, Kanpur

ELECT & PLUMBING CONSULTANT:-
KKSC
 KISHOR KUMAR SERVICES CONSULTANTS
 007-PINNACLE TOWER, GH-7, AHINSA KHAND-2, INDRAPURAM, GHAZIABAD, UP-201014
 PHONE: +91 120 4132558 MOBILE: +91 9910487835
 kksc0101@gmail.com

Project:-
PROPOSED BUILDING PLAN FOR CONVENIENT SHOPS AT EMERALD GULISTAN, J.K.RAYON, JAJMAU, KANPUR.

DRAWING TITLE
TERRACE LEVEL ELECTRICAL LIGHTING & FIRE ALARM LAYOUT


DRAWN BY PARDDEP	DATED 16-02-2022
CHECKED BY R.D	SCALE A-1/75

APPROVED BY. K.K	DRG.No. KKSC/JK.C./CS/EL-03
----------------------------	---------------------------------------

GOOD FOR CONSTRUCTION



LEGEND:-	
SYMBOL	DESCRIPTION
	SWITCH BOARD
	6AMP SWITCH & SOCKET
	6/16AMP SWITCH & SOCKET
	6/16AMP SWITCH & SOCKET FOR HAND DRYER
	10W BULK HEAD LIGHT
	10W LED CEILING LIGHT
	MIRROR LIGHT
	MANUAL CALL POINT
	HOOTER WITH STROBE
	DISTRIBUTION BOARD
	LOOPING FOR NORMAL LIGHT
	EARTHING G.I STRIP
	EARTHING DOWN TAKE
	FIRE ALARM CONTROL PANEL

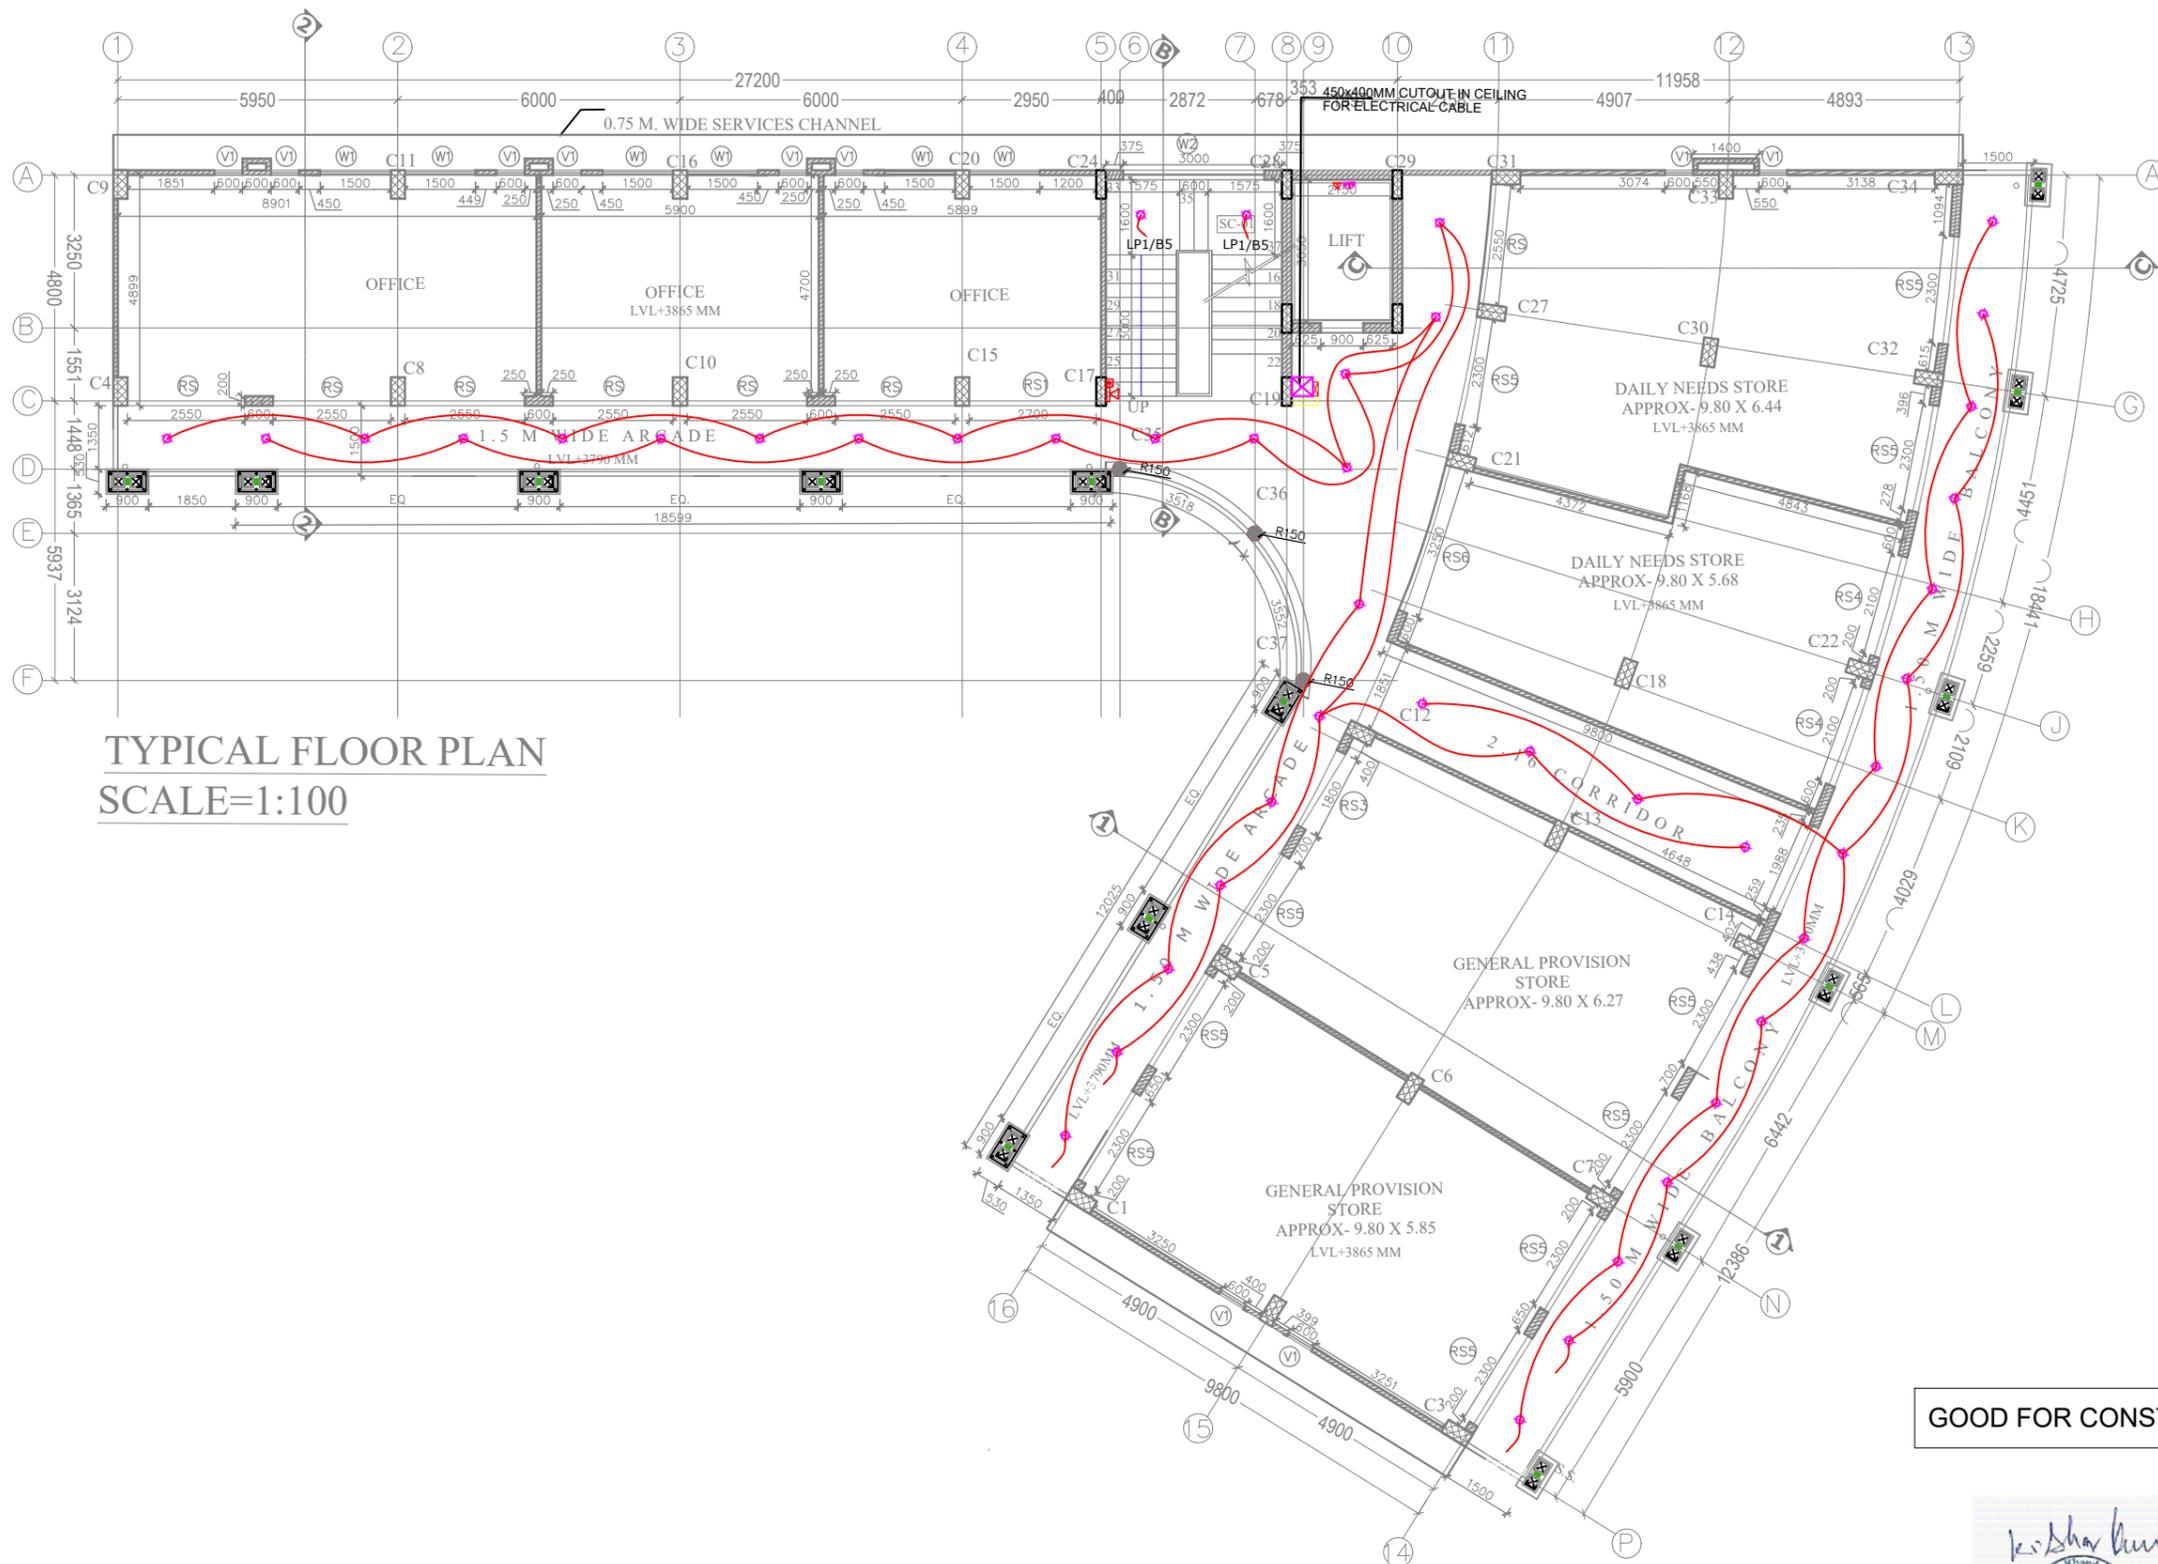

TYPICAL FLOOR PLAN
SCALE=1:100

GOOD FOR CONSTRUCTION

Kishor Kumar
Kishor Kumar
Services
Consultants

ARCHITECT:- Ar. SAMIR CHAKRAVORTY
DRAWN BY:- Ar. NIVEDITA TIWARI

OWNER and DEVELOPER :-
J.K. COTTON LTD.
FORMLY KNOWN AS J.K. Cotton Spinning And Weaving Mill,
Dwarkadheesh Temple Road,
Kamla Tower, Kanpur

ELECT & PLUMBING CONSULTANT:-
KKSC
KISHOR KUMAR SERVICES CONSULTANTS
007-PINNACLE TOWER, GH-7
AHINSA KHAND-2, INDRAPURAM
GHAZIABAD, UP-201014
PHONE: +91 120 4132558
MOBILE: +91 9910487835
kksc0101@gmail.com

Project:-
**PROPOSED BUILDING PLAN FOR CONVENIENT
SHOPS AT EMERALD GULISTAN, J.K.RAYON,
JAJMAU, KANPUR.**


DRAWING TITLE
**TYPICAL FLOOR ELECTRICAL
LIGHTING & FIRE ALARM LAYOUT**

DRAWN BY PARDDEP	DATED 16-02-2022
----------------------------	----------------------------

CHECKED BY R.D	SCALE A-1/75
--------------------------	------------------------

APPROVED BY. K.K	DRG.No. KKSC/JK.C./CS/EL-02
----------------------------	---------------------------------------

LEGEND:-	
SYMBOL	DESCRIPTION
	TELEPHONE TAG BLOCK
	POWER MCB BOX
	ELECTRICAL CONDUIT
	ELECTRICAL CABLE TRAY
	LV CABLE TRAY
	FIRE ALARM CONTROL PANEL
	MANUAL CALL POINT
	HOOTER WITH STROBE
	DISTRIBUTION BOARD

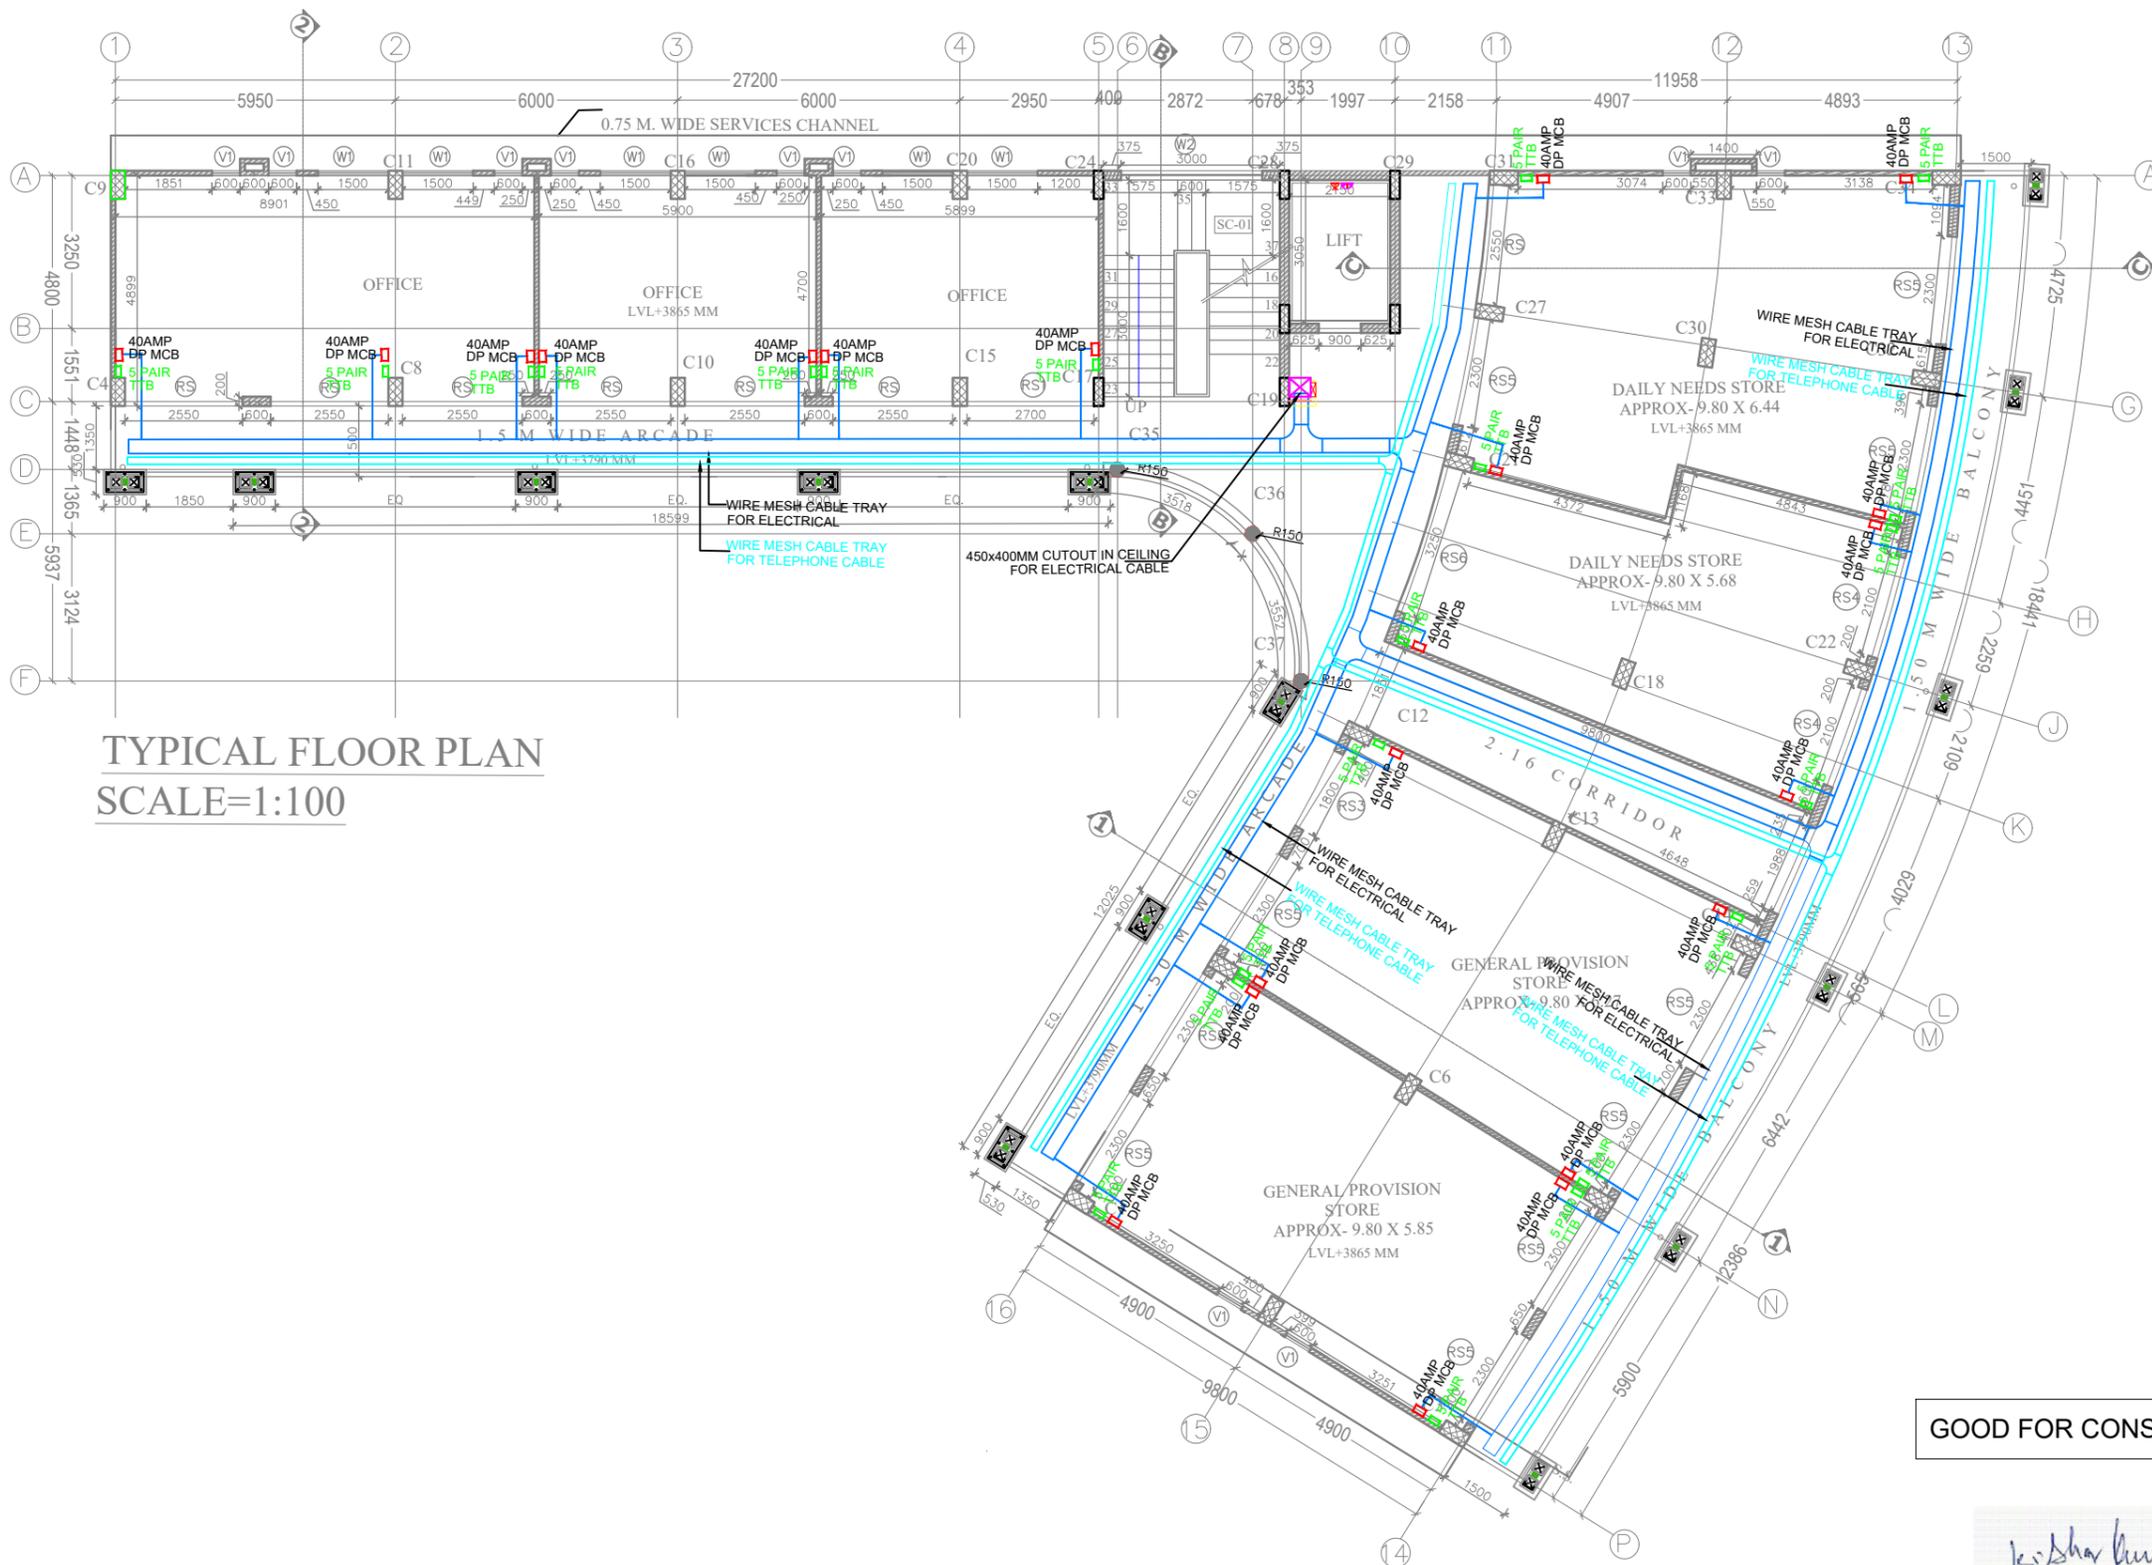

TYPICAL FLOOR PLAN
SCALE=1:100

ARCHITECT:- Ar. SAMIR CHAKRAVORTY
DRAWN BY:- Ar. NIVEDITA TIWARI

OWNER and DEVELOPER :-
J.K. COTTON LTD.
FORMLY KNOWN AS J.K. Cotton Spinning And Weaving Mill,
Dwarkadheesh Temple Road,
Kamla Tower, Kanpur

ELECT & PLUMBING CONSULTANT:-
KKSC
KISHOR KUMAR SERVICES CONSULTANTS
007-PINNACLE TOWER, GH-7, AHINSA KHAND-2, INDRAPURAM, GHAZIABAD, UP-201014
PHONE: +91 120 4132558
MOBILE: +91 9910487835
kksc0101@gmail.com

Project:-
PROPOSED BUILDING PLAN FOR CONVENIENT SHOPS AT EMERALD GULISTAN, J.K.RAYON, JAJMAU, KANPUR.

DRAWING TITLE
TYPICAL FLOOR ELECTRICAL CABLE TRAY LAYOUT

DRAWN BY
PARDDEP

DATED
16-02-2022

CHECKED BY
R.D

SCALE
A-1/75

APPROVED BY.
K.K

DRG.No.
KKSC/JK.C./CS/CT-02

GOOD FOR CONSTRUCTION

Kishor Kumar