


WATER SUPPLY LEGEND	
SYMBOL	DESCRIPTION
	GARDEN HYDRANT
	DOMESTIC WATER SUPPLY LINE
	VALVE

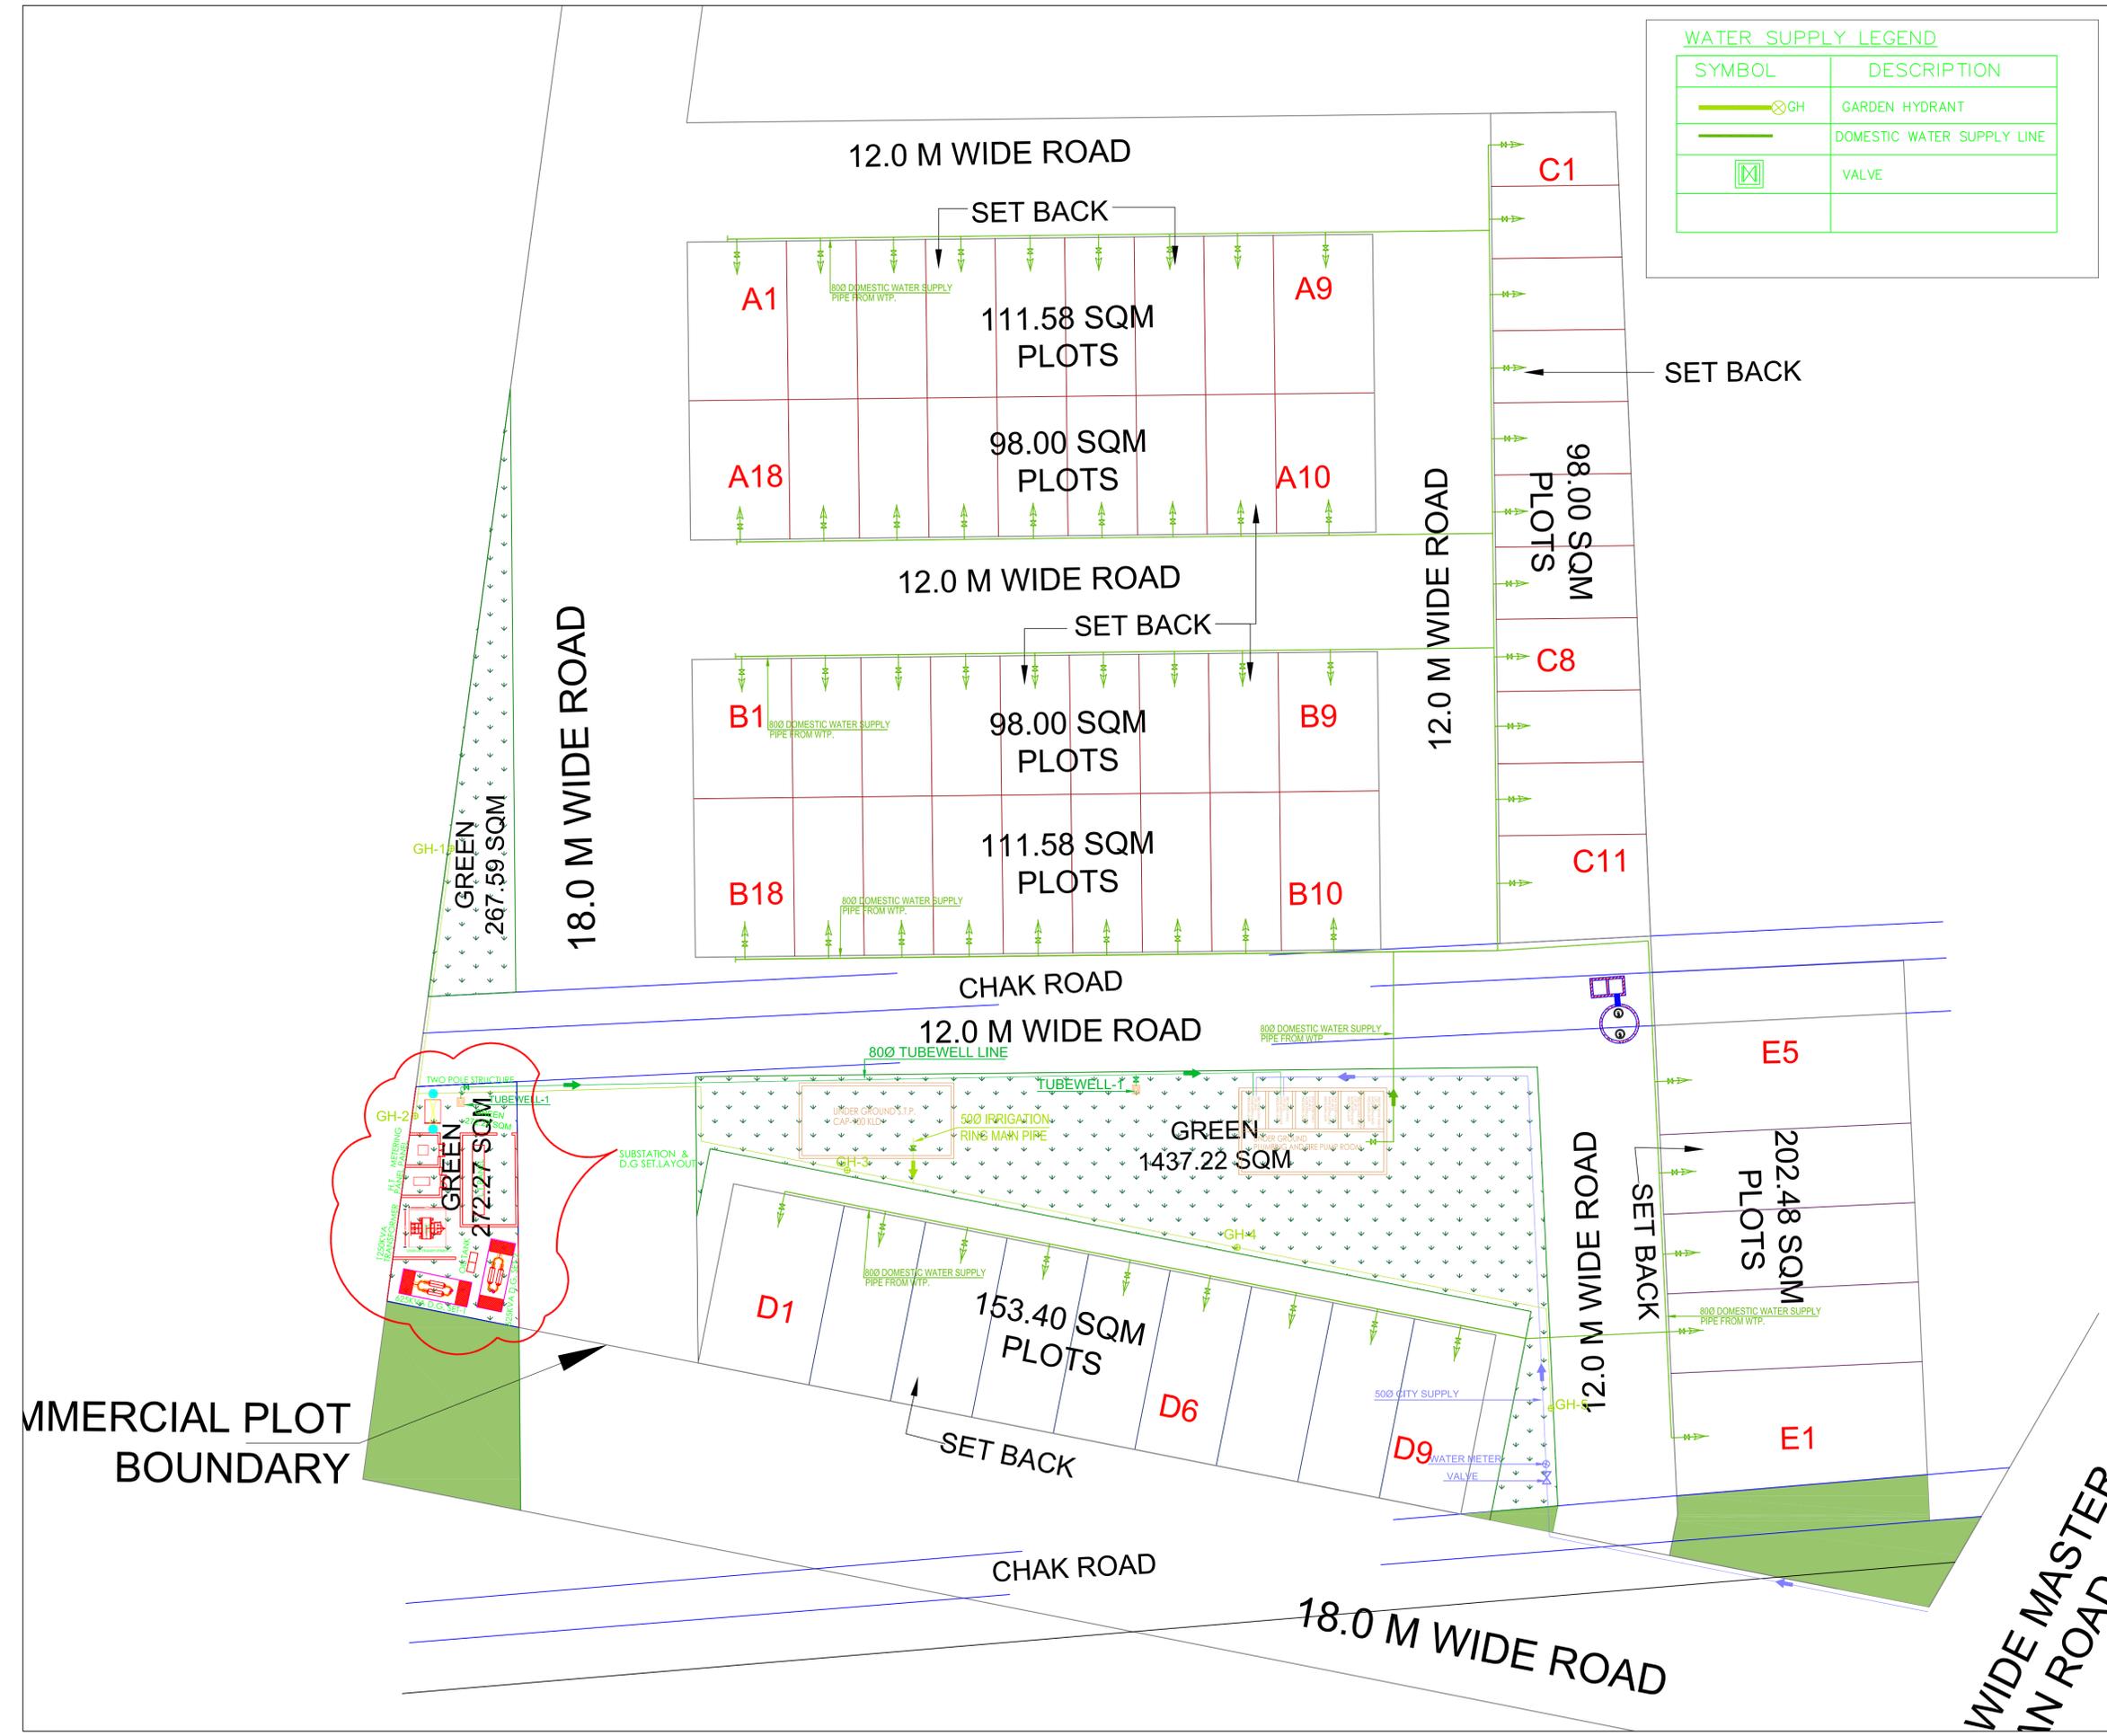

SUBMISSION DRAWING

DATE	NO.	ISSUED TO	FOR
13.01.25	-	ARCHITECT	SUBMISSION
06.01.25	-	ARCHITECT	SUBMISSION

DATE	REV. NO.	DESCRIPTION
13.01.25	R1	S.T.P. LOCATION CHANGE AS PER ARCHITECT COMMENTS.

CLIENT
PROJECT
PLOTTING AT NIZAMPUR, PILAKHUA



MEP Consultants
MAVERICK ENGG. CONSULTANT(P) LTD.
Electro-Mechanical Consulting engineers
A-440, 4TH FLOOR
LOGIXTECHNOVA, SECTOR-132, NOIDA-201304
P: +91-01203141581, 9911933696
E-mail: maverickenggmep@gmail.com, maverickengg23@gmail.com

PLUMBING DRAWING	
TITLE: EXTERNAL SITE PLAN WATER SUPPLY AND TUBE-WELL AND IRRIGATION LAYOUT (COMMERCIAL BUILDING)	
DEALT BY: P.K	APPROVED BY:
CHKD BY: D.SINGH	PROJECT NO.
SCALE: 1:300	DATE: 06.01.2025
SIGN:	DRAWING NO. NORTH
<input type="checkbox"/> FOR SUBMISSION <input type="checkbox"/> FOR INFORMATION <input type="checkbox"/> FOR EXECUTION <input type="checkbox"/> FOR APPROVAL <input type="checkbox"/> FOR GFC	WS-C-01 REVISION: R0 R1
THIS DRAWING IS THE SOLE PROPERTY OF MAVERICK ENGINEERING PVT. LTD. AND IS NOT TO BE COPIED OR REPRODUCED WITHOUT THEIR PERMISSION	
SIZE	A1