


30.00 M. WIDE ROAD

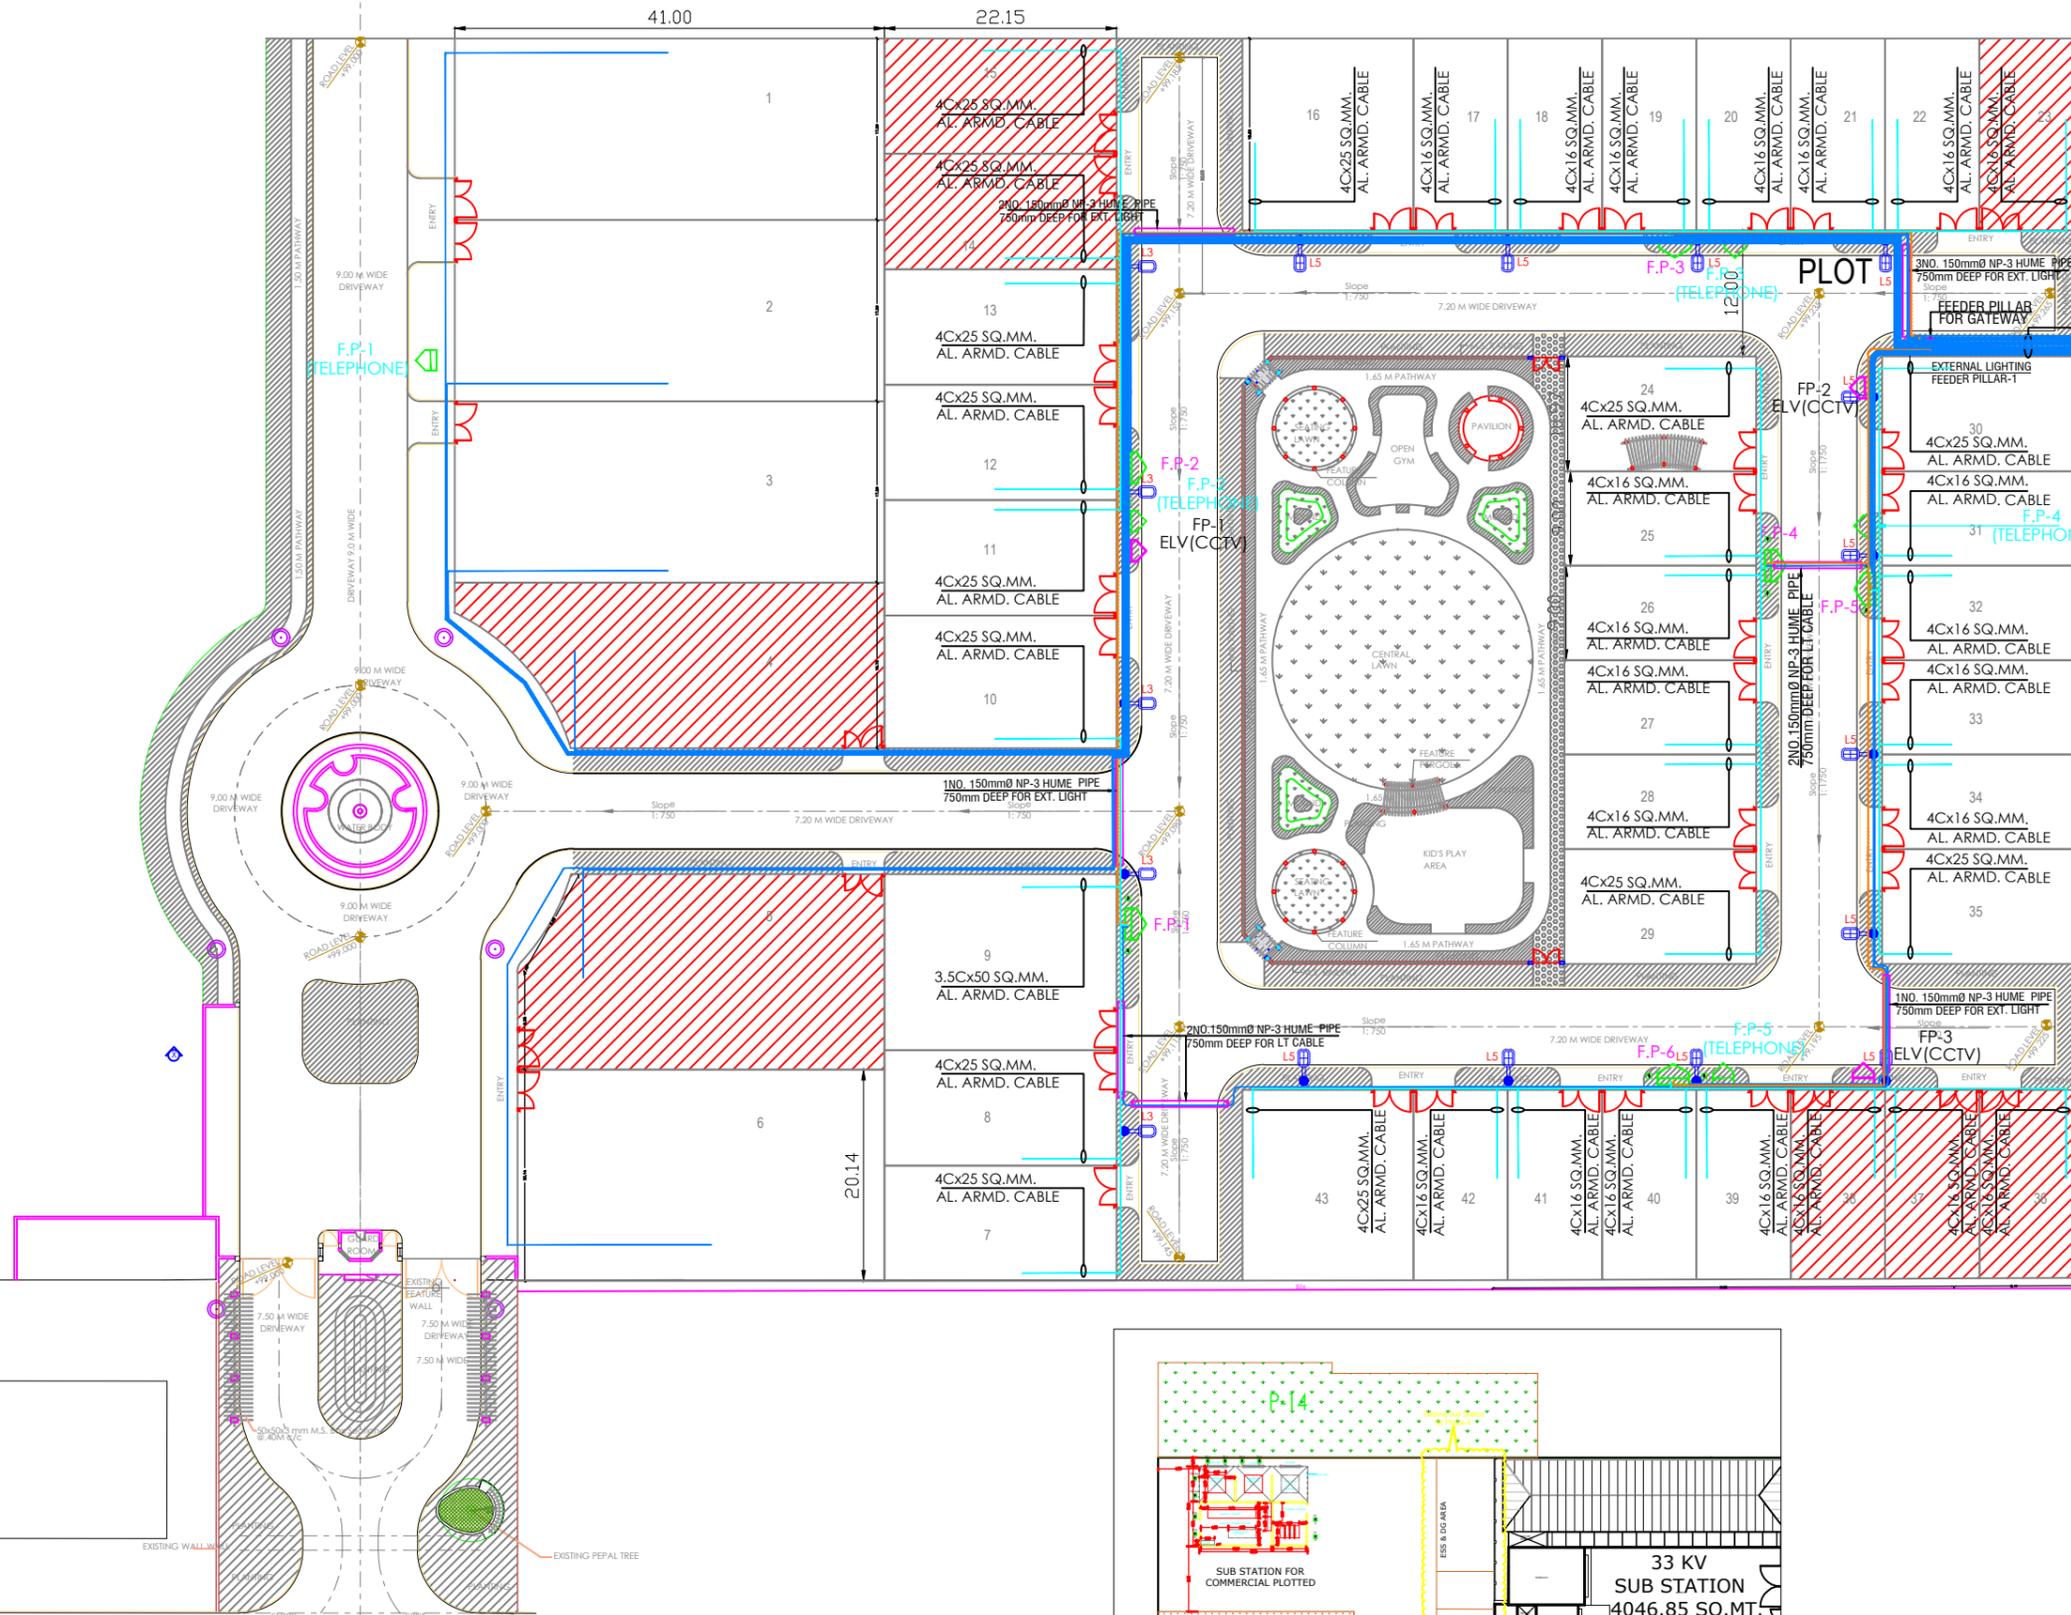

MAIN LT PANEL TO FP-1
3.5Cx300 SQ.MM.
MAIN LT PANEL TO FP-2
3.5Cx300 SQ.MM.
MAIN LT PANEL TO FP-3
3.5Cx300 SQ.MM.
MAIN LT PANEL TO PLOT NO.-1
3.5Cx300 SQ.MM.
MAIN LT PANEL TO PLOT NO.-2
3.5Cx300 SQ.MM.
MAIN LT PANEL TO PLOT NO.-3
3.5Cx300 SQ.MM.
MAIN LT PANEL TO PLOT NO.-3
3.5Cx300 SQ.MM.
MAIN LT PANEL TO FP-4
3.5Cx240 SQ.MM.
MAIN LT PANEL TO FP-5
3.5Cx240 SQ.MM.
MAIN LT PANEL TO FP-6
3.5Cx300 SQ.MM.
MAIN LT PANEL TO PLOT NO.-4
3.5Cx240 SQ.MM.
MAIN LT PANEL TO PLOT NO.-5
3.5Cx240 SQ.MM.
MAIN LT PANEL TO PLOT NO.-6
3.5Cx240 SQ.MM.
COMMON AREA EMER. PANLE
TO EXTR. LIGHTING PANLE
4Cx16 SQ.MM.

ELECTRICAL LEGEND :	
	EXTRA LOW VOLTAGE CCTV/TELEPHONE FEEDER PILLAR
	OUTDOOR BOX TYPE CAMERA VANDAL RESISTANCE IK-10,IP66 FULL HIGH DEFINITION BULLET IR CAMERA 2 MEGAPIXEL 1/2 IMAGE SENSOR 0.05 LUX COLOUR VARI FOCAL LENCE 2.8MM TO 13MM
	ELECTRICAL FEEDER PILLAR
	60W LED LIGHT FIXTURE ON 6.5.0 MTR. POLE WITH SINGLE ARM
	PSS TO FEEDER PILLAR LT CABLE
	ELECT. FEEDER PILLAR PLOT
	2Cx22 AWG STRANDED (7X30) TINNED COOPER SHEILDLED CABLE
	HT CABLE
	NP-3 HUMIE PIPE FOR LT CABLE
	EARTHING PIT

ISSUED TO	DESCRIPTION	DATE	BY
ISSUED LOG			

REV. NO DESCRIPTION DATE BY

STAGE:-
GOOD FOR CONSTRUCTION

CLIENT:-
J. K. COTTON LTD.
FORMLY KNOWN
AS J.K. COTTON Spinning And Weaving
MillDwarkadheesh Temple Road,Kanpla
Tower,Kanpur

ELECT & PLUMBING CONSULTANT:-
KKSC
KISHOR KUMAR SERVICES CONSULTANTS

007-PINNACLE TOWER, GH-7 PHONE: +91 120 4132558
AHINSA KHAND-2, INDRAPURAM MOBILE: +91 9910487835
GHAZIABAD, UP-201014 kksco101@gmail.com

Project:-
COMMERCIAL PLOTTED
JAJMAU, KANPUR

DRAWING TITLE
LT CABLE ROUTE LAYOUT
PLAN COMMERCIAL AREA

DRAWN BY PRADEEP	DATE 25.01.2022
CHECKED BY R.D.	SCALE NTS (A1)
APPROVED BY. K.K	DRG.No. KKSC/JK.C./PL/RT ROUTE-01

