


CLIENT
 EXPERION DEVELOPERS PRIVATE LIMITED
 8th Floor, Wing B, Milestone Experion Centre, Sector 15 Part 2,
 Sector 15, Gurugram, Haryana 122001

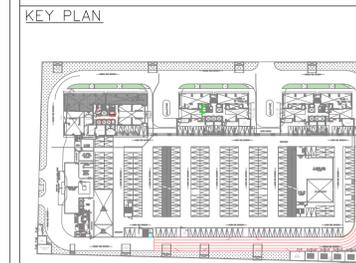

NOTES:-

PROJECT
EXPERION RESIDENTIAL
 NOIDA, SECTOR 151

PRINCIPAL ARCHITECT :
 DPA CONSULTANTS PVT LTD
 MUMBAI
 76, FREE PRESS HOUSE, 7TH FLOOR, 215
 NARIMAN POINT, MUMBAI 400 021.
 TEL: +91 22 6651 0838
 FAX: +91 22 6651 0836

EXECUTIVE ARCHITECT :
ACPL ISO 9001:2008
 Architecture Management Planning
 ACPL Design Ltd E-24 South Extension 1-1-91 11 24622195
 New Delhi 110049, India +91 11 24646709
 E: contact@acplonline.com IN 11 24634069

STRUCTURAL CONSULTANTS :
 DR. KELKAR DESIGNS PRIVATE LIMITED
 SHOP NO. 610, KESHAVA BUILDING, BANDRA KURLA COMPLEX RD,
 NEAR FAMILY COURT, E BLOCK BKC, BANDRA KURLA COMPLEX,
 BANDRA EAST, MUMBAI, MAHARASHTRA 400051
 TEL: 022 26592278

MEP CONSULTANTS :
 DESIGN CENTRE CONSULTING ENGINEERS PVT. LTD.
 4TH FLOOR, ANSAL PLAZA, 4F, CS-44 - 47, MALL, SECTOR-1, VAISHALI,
 GHAZIABAD, DELHI, UTTAR PRADESH PIN CODE - 201010

ARCHITECT'S SEAL & SIGNATURE OWNER'S SEAL & SIGNATURE


[Signature]
KULMEET SHANGARI
 ARCHITECT
 CA/97/21741

[Signature]
 Experion Developers Private Limited
 Authorised Signatory

SCALE :- 1: 300

DRG. TITLE : WATER SUPPLY LAYOUT GROUND FLOOR PLAN

DCCE/PL/03

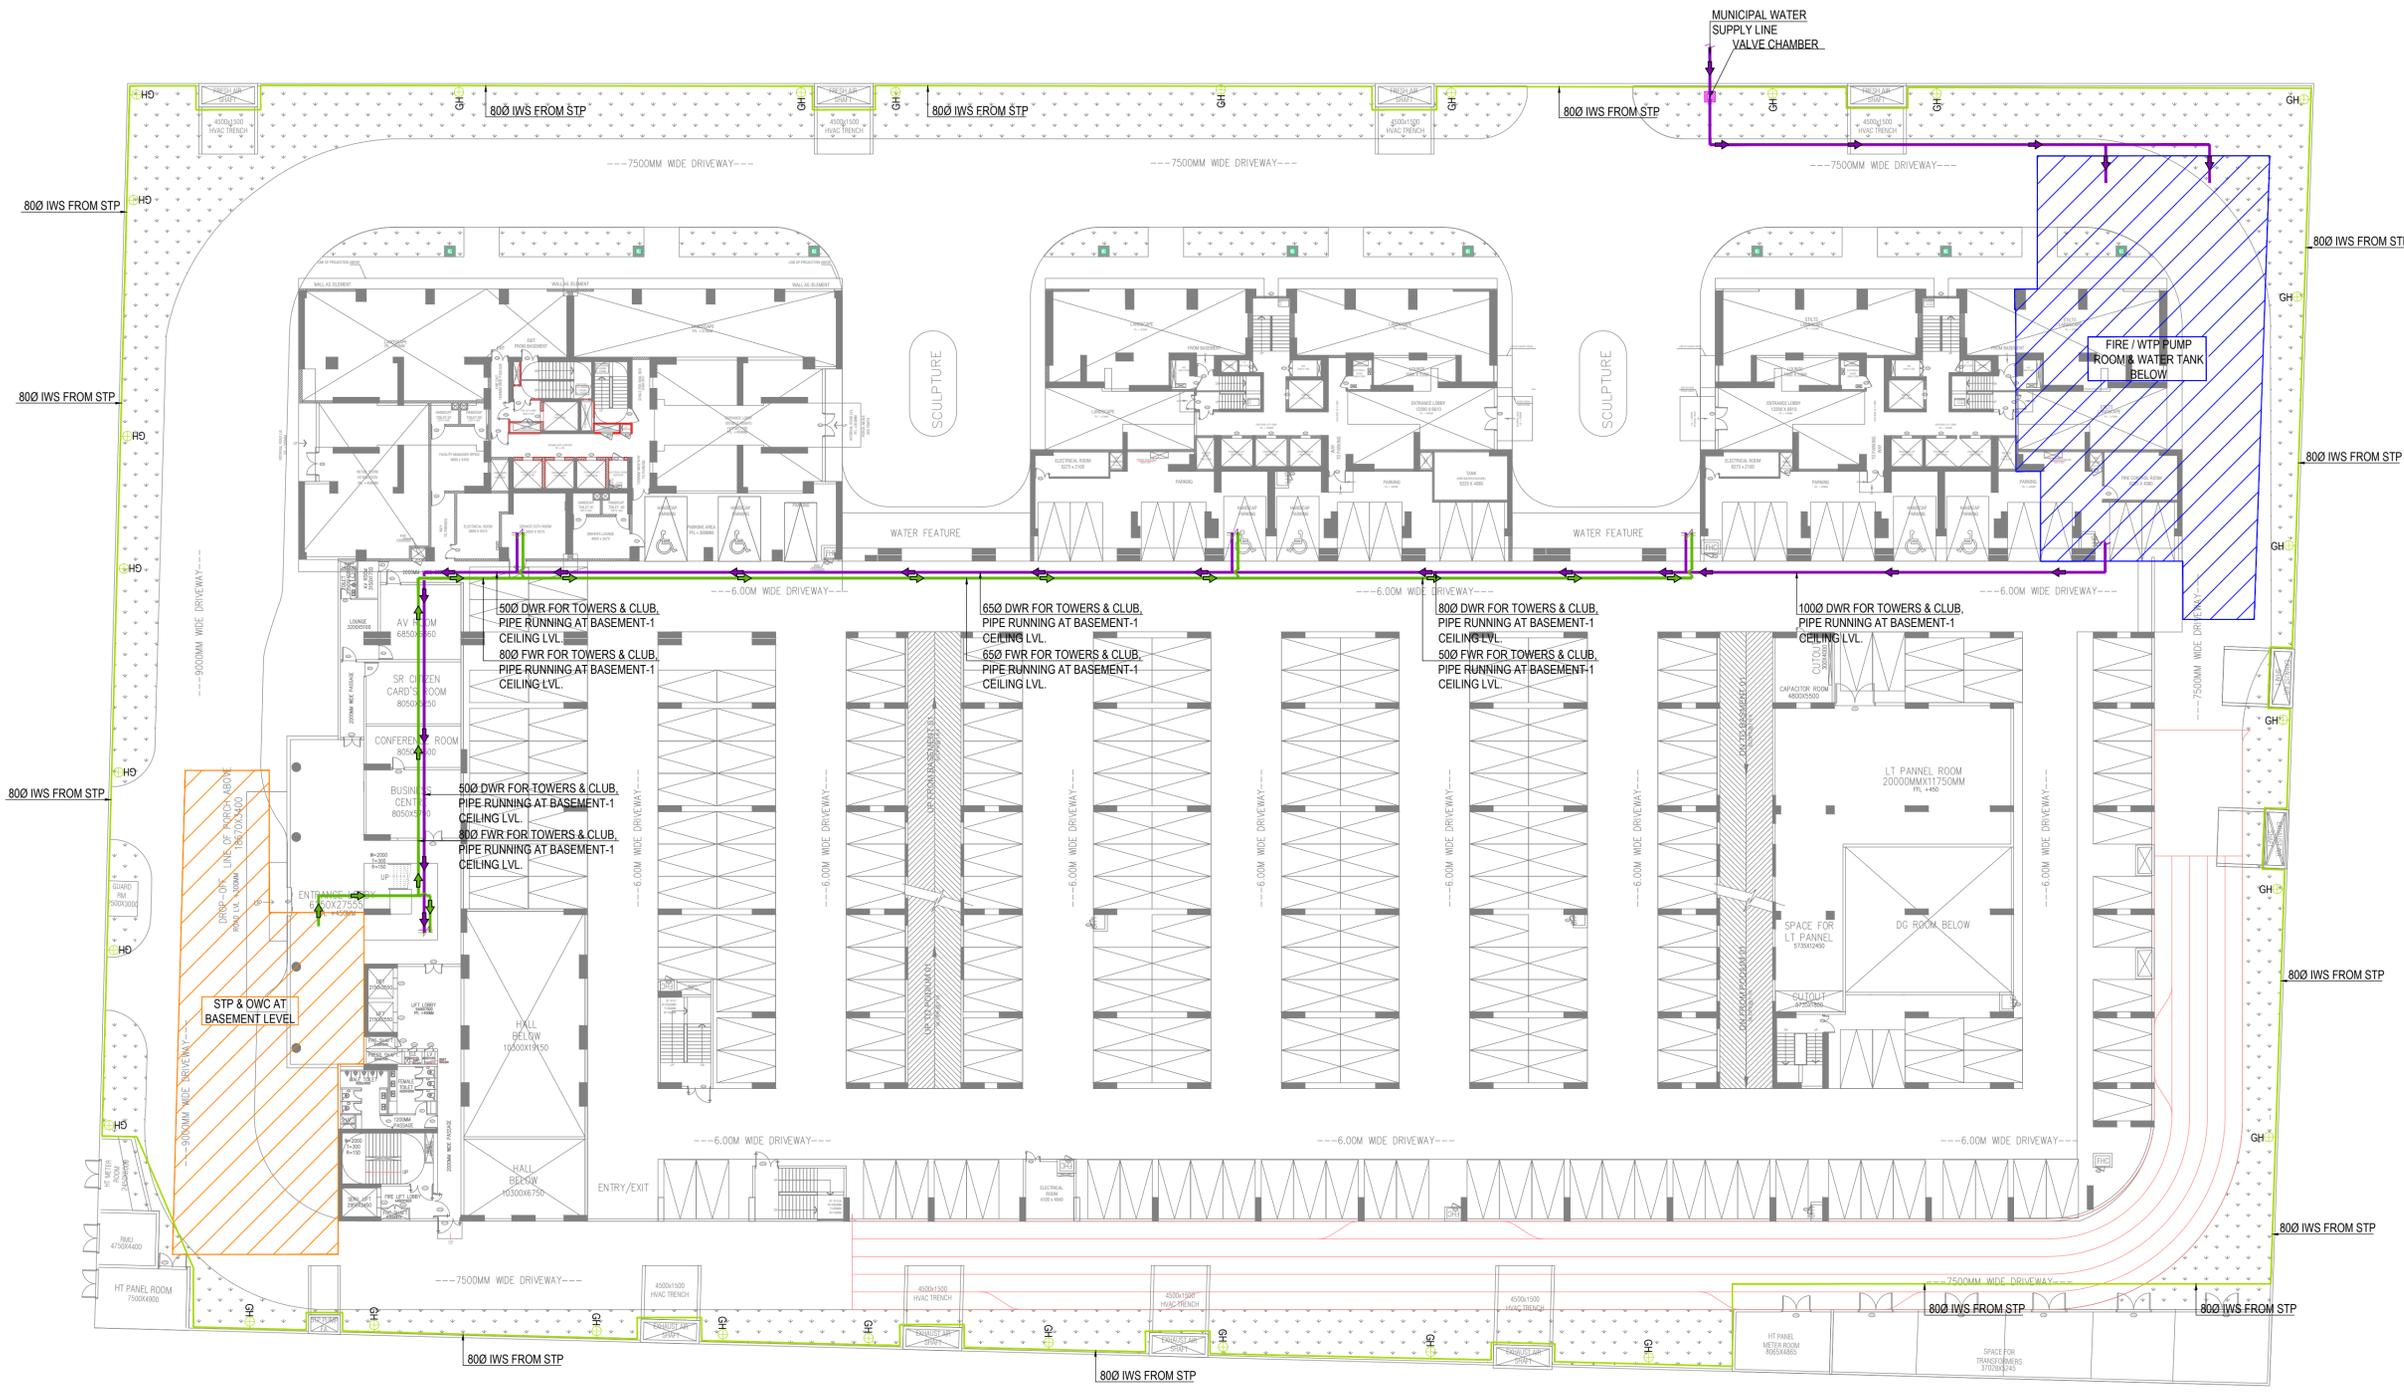

GROUND / PODIUM-1 / STILT-1 FLOOR PLAN

PLUMBING LEGEND: WATER SUPPLY

	DOMESTIC WATER RISER
	FLUSHING WATER RISER
	MUNICIPAL WATER SUPPLY
	IRRIGATION WATER SUPPLY
	GARDEN HYDRANT NOZZEL
	VALVE CHAMBER