


LEGEND:- (electrical)

S NO.	SYMBOL	DESCRIPTION	POSITION
1		1x28W T5 TUBE LIGHT FIXTURE(SURFACE)	2550
2		1x28W T5 TUBE LIGHT FIXTURE(CEILING)	ON CEILING
3		2x28W T5 TUBE LIGHT FIXTURE(CEILING)	ON CEILING
4		1x25W CFL WALL MOUNTED LIGHT FIXTURE	2550
5		2x11W CFL TYPE CEILING LIGHT (SURFACE)	ON CEILING
6		MIRROR LIGHT	1850
7		SWITCH BOARD	1100
8		5 -AMP PLUG POINT	200
9		5 -AMP PLUG POINT	1100 or 300 ABOVE PLATFORM
10		5 -AMP PLUG POINT	2250
11		5/15 -AMP POWER POINT	200
12		5/15 -AMP POWER POINT FOR GYSER	SOCKET-1650 SWITCH-1100
13		5/15 -AMP POWER POINT	1100 or 300 ABOVE PLATFORM
14		5/15 -AMP POWER POINT	900
15		20/32 -AMP MCB(A.C. POINT)	200
16		CEILING FAN	ON CEILING
17		EXHAUST FAN	IN WINWEN
18		TELEPHONE / INTERCOM SOCKET	200
19		CALL BELL	1200
20		BUZZER	2400
21		INDICATES CONTROLLING OF LIGHT/FAN FROM SWITCH BOARD	
22		T.V. ANTENNA POINT	200
23		DISTRIBUTION BOARD	1600 (TOP OF D.B.)
24		L.D.B. LIGHTING DISTRIBUTION BOARD	
25		P.D.B. POWER DISTRIBUTION BOARD	
26		SUBMAIN CONDUIT FROM L.T. PANEL TO L.D.B./D.B.	

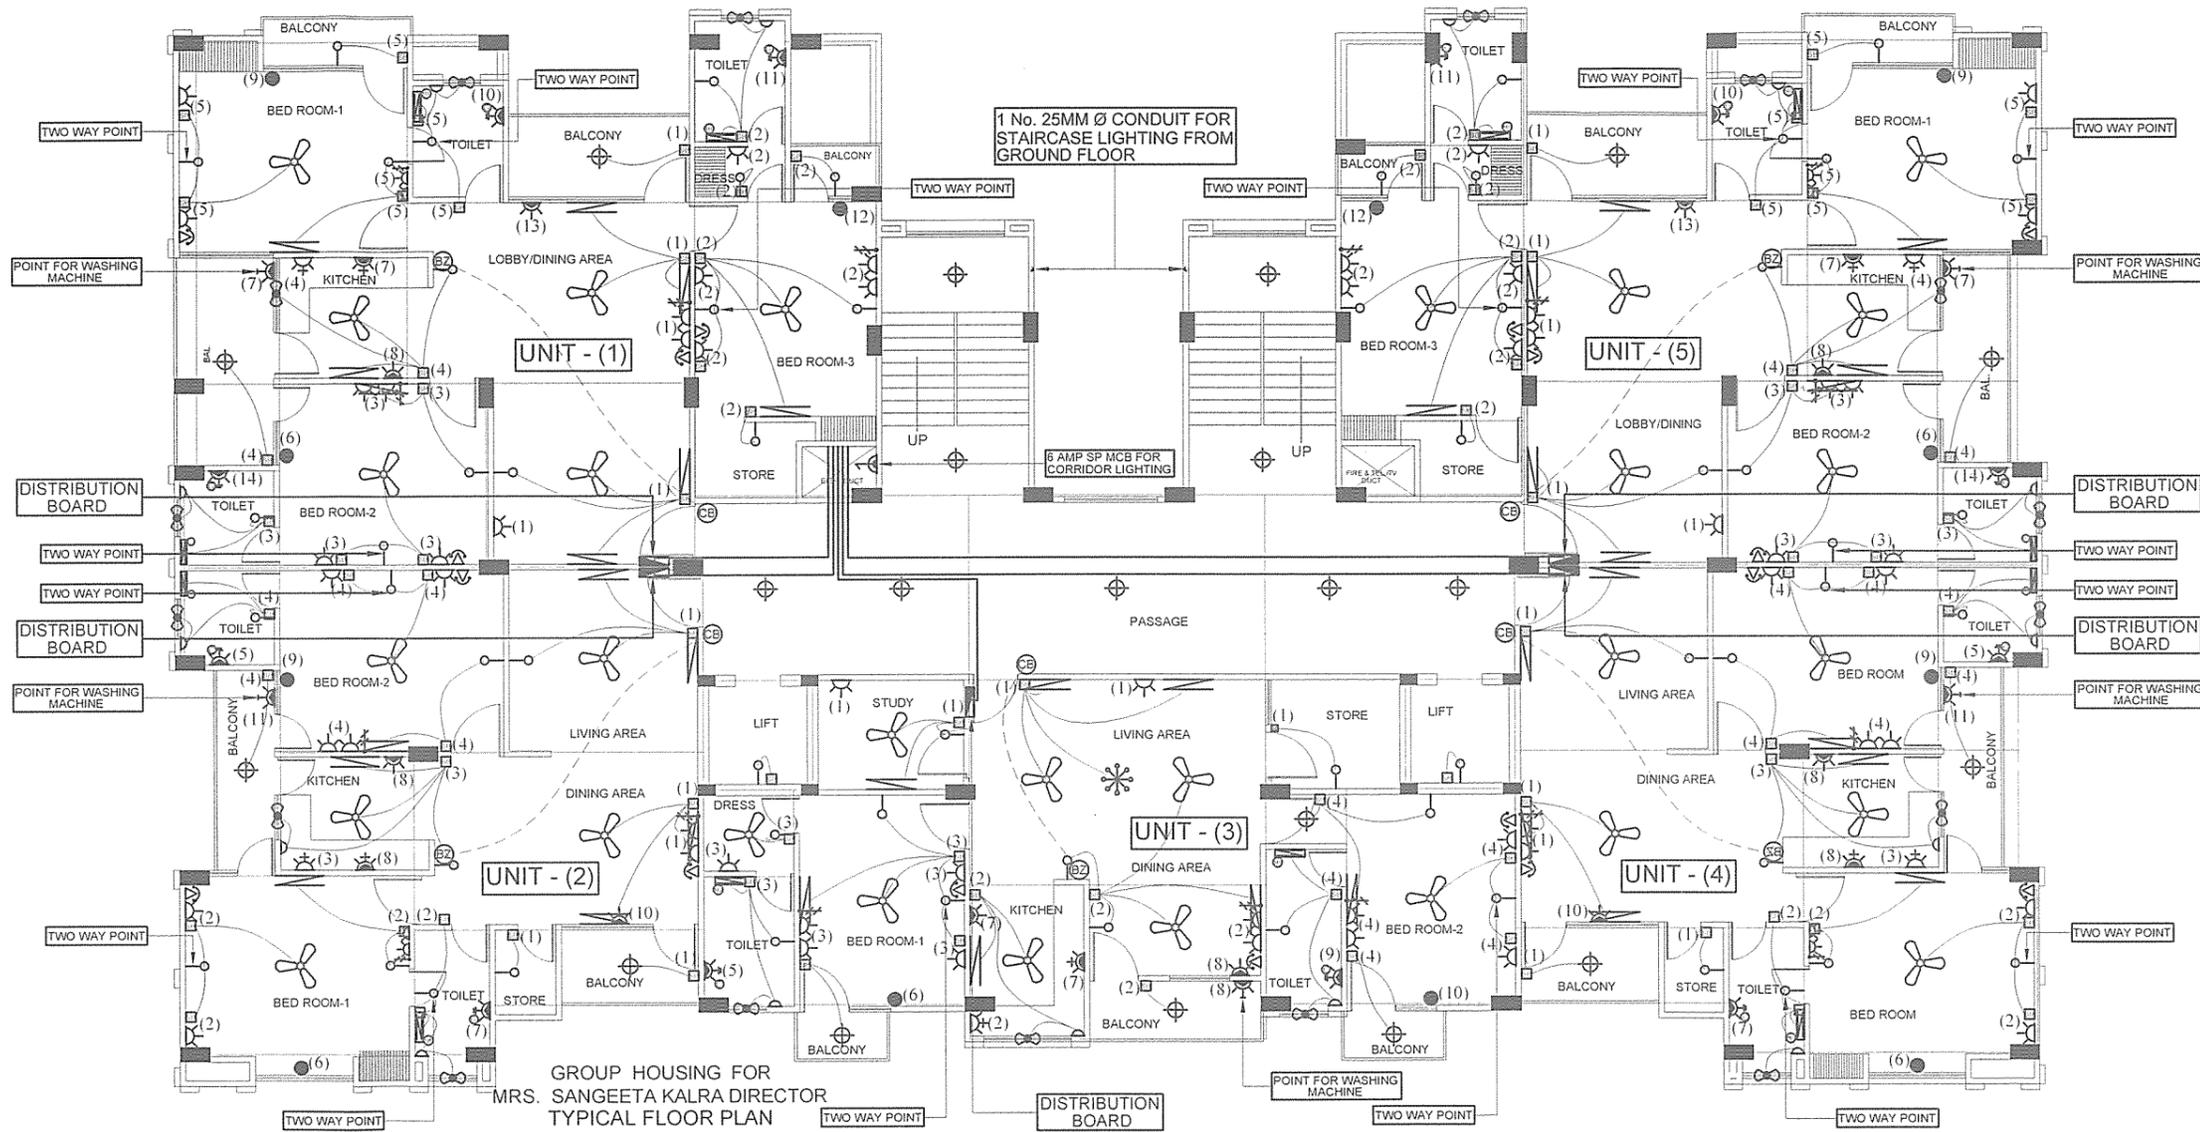

TYPICAL FLOOR PLAN


PROJECT: PROPOSED GROUP HOUSING FOR MRS. SANGEETA KALRA DIRECTOR SAS GLOBAL PRIVATE LTD. AT PLOT NO-11/COM-105.(C) VRINDAVAN YOJNA LUCKNOW	DRG TITLE:- TYPICAL FLOOR PLAN (ELECTRICAL)	PROJECT MANAGER: SCALE: 1:100	ARCHITECTURAL CONSULTANTS :- The Vision Arch Office No.5 First Floor, Natraj Complex 11.B.N.Road Lal Bagh Lucknow U.P. Mobile No.9415006154	Services Consultant : SHAH & PANT CONSULTING ENGINEERS (P) LTD. AN ISO 9001-2008 COMPANY (Building services Consultant, Soil & foundation Experts, Highway Engineering) 1, 4th Floor, HALWASIYA COURT, HAZRATGANJ, LUCKNOW (U.P.) Tele. No. : 0522-2230625, Fax : 0522-2230625, Cell : 9839013280, 9415027719 Email : shah_pant@yahoo.co.in, Web : www.shahpantconsultingengineers.com
	SUB. TITLE: RESIDENTIAL BUILDING	DRG. NO. : RE. BUI./SEE-03	DRN BY : JITENDRA	
		DATE: DEC-2013		

PRODUCED BY AN AUTODESK EDUCATIONAL PRODUCT

PRODUCED BY AN AUTODESK EDUCATIONAL PRODUCT

LEGEND:- (electrical)

S. NO.	SYMBOL	DESCRIPTION	POSITION
1		1x2W T5 TUBE LIGHT FIXTURE(SURFACE)	2550
2		1x2W T5 TUBE LIGHT FIXTURE(CEILING)	ON CEILING
3		2x2W T5 TUBE LIGHT FIXTURE(CEILING)	ON CEILING
4		1x2W CFL WALL MOUNTED LIGHT FIXTURE	2550
5		2x11W CFL TYPE CEILING LIGHT (SURFACE)	ON CEILING
6		MIRROR LIGHT	1850
7		SWITCH BOARD	1100
8		5 -AMP PLUG POINT	200
9		5 -AMP PLUG POINT	1100 or 200 ABOVE PLATFORM
10		5 -AMP PLUG POINT	2250
11		5/15 -AMP POWER POINT	200
12		5/15 -AMP POWER POINT FOR GYSER	SOCKET-1550 SWITCH-1100
13		5/15 -AMP POWER POINT	1100 or 200 ABOVE PLATFORM
14		5/15 -AMP POWER POINT	900
15		20/32 -AMP MCB(A.C. POINT)	200
16		CEILING FAN	ON CEILING
17		EXHAUST FAN	IN WINDOW
18		TELEPHONE / INTERCOM SOCKET	200
19		CALL BELL	1200
20		BUZZAR	2400
21		INDICATES CONTROLLING OF LIGHT/FAN FROM SWITCH BOARD	
22		T.V. ANTENNA POINT	200
23		DISTRIBUTION BOARD	1600 (TOP OF D.B.)
24		L.D.B. LIGHTING DISTRIBUTION BOARD	
25		P.D.B. POWER DISTRIBUTION BOARD	
26		SUBMAIN CONDUIT FROM L.T. PANEL TO L.D.B./D.B.	

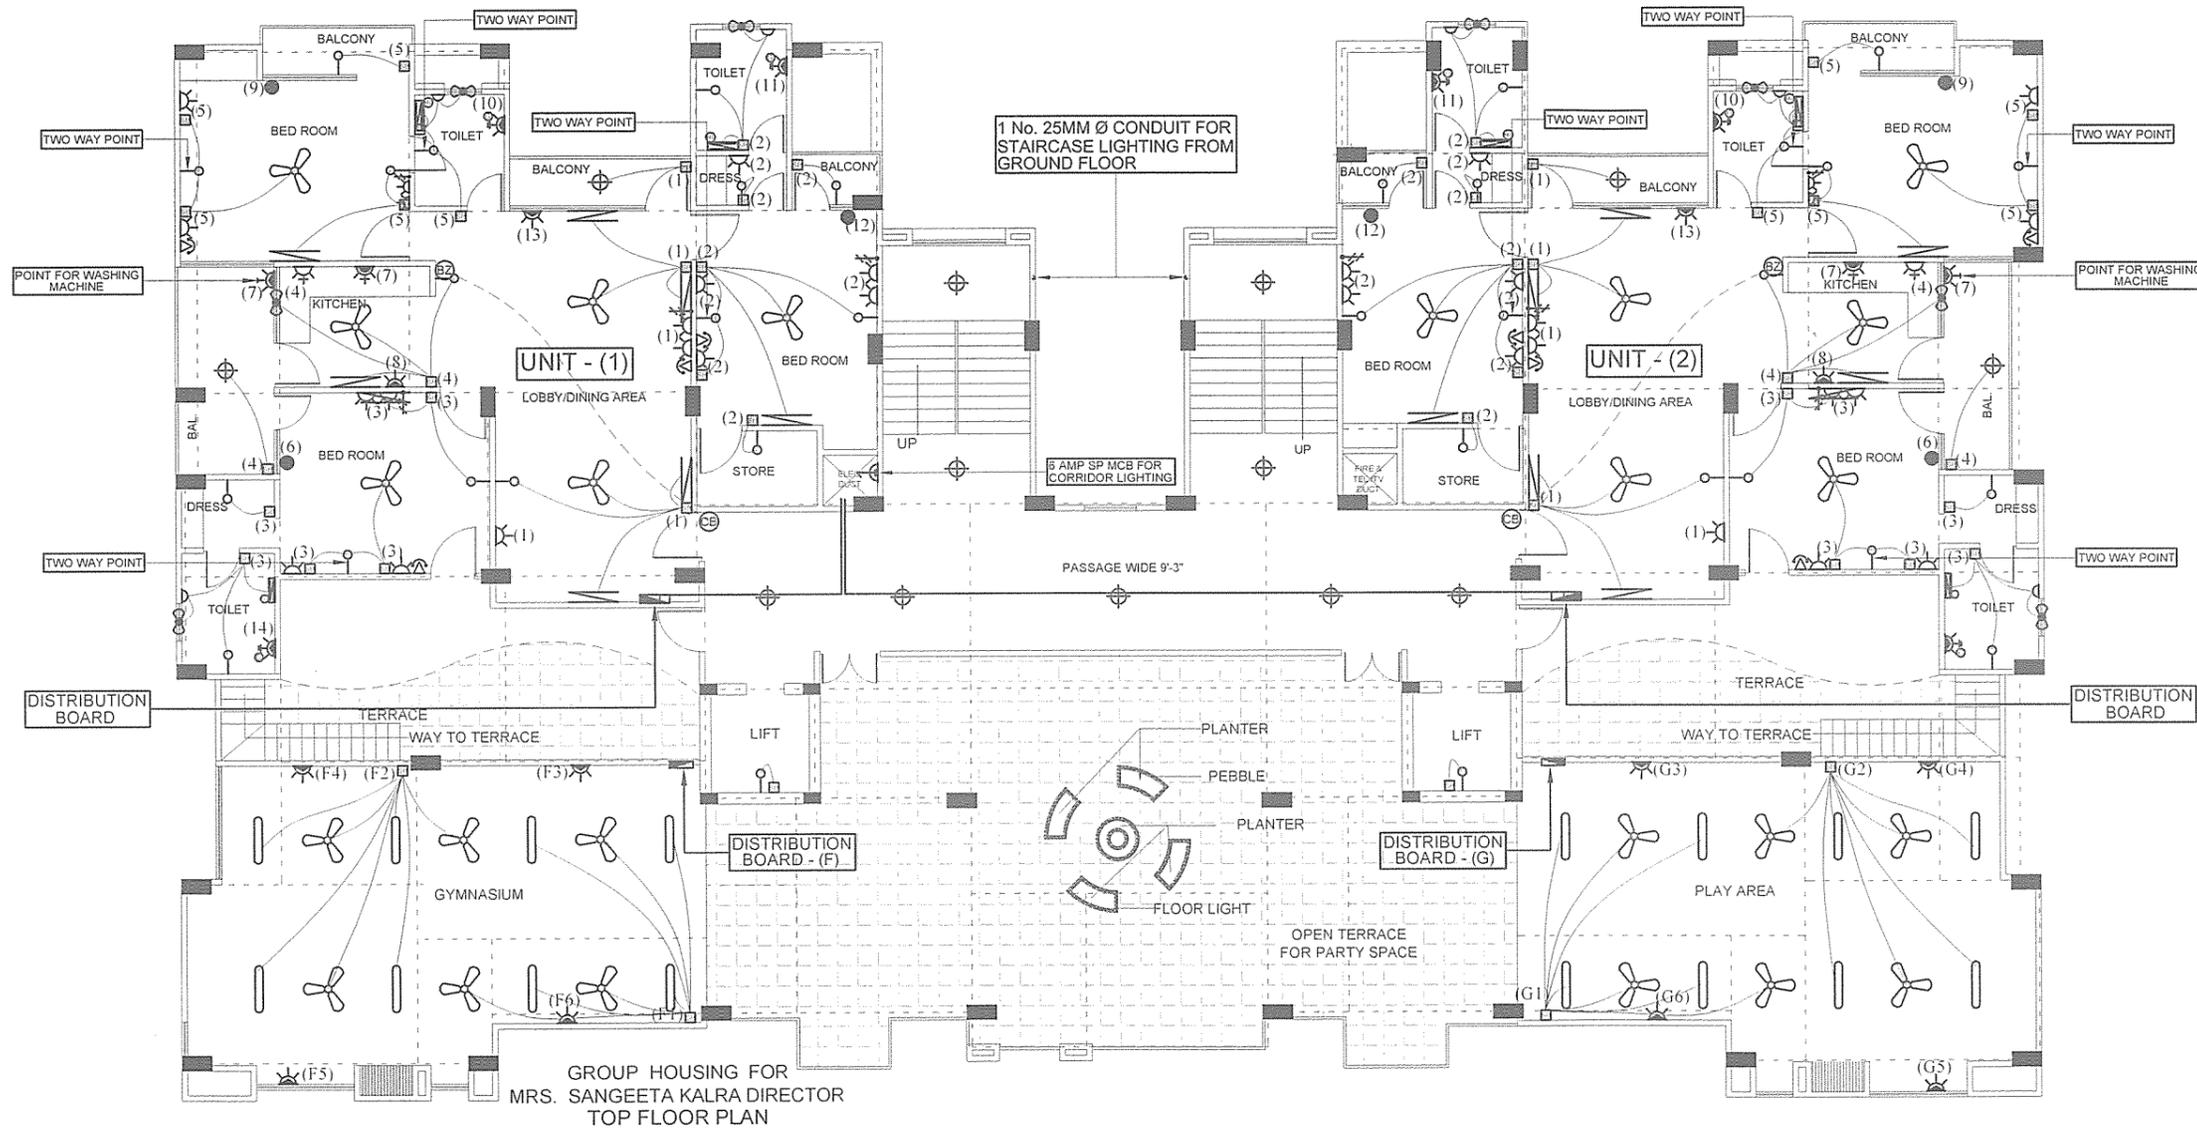

PRODUCED BY AN AUTODESK EDUCATIONAL PRODUCT

PRODUCED BY AN AUTODESK EDUCATIONAL PRODUCT

TOP FLOOR PLAN

<p>PROJECT</p> <p>PROPOSED GROUP HOUSING FOR MRS. SANGEETA KALRA DIRECTOR SAS GLOBAL PRIVATE LTD. AT PLOT NO-11/COM-105.(C) VRINDAVAN YOJNA LUCKNOW</p>	<p>DRG. TITLE:-</p> <p style="text-align: center;">TOP FLOOR PLAN (ELECTRICAL)</p> <p>SUB. TITLE:</p> <p style="text-align: center;">RESIDENTIAL BUILDING</p>	<p>PROJECT MANAGER:</p> <p>SCALE: 1:100</p> <p>DRN BY: JITENDRA</p> <p>DATE: DEC-2013</p>	<p>ARCHITECTURAL CONSULTANTS :-</p> <p style="text-align: center;">The Vision Arch Office No.5 First Floor, Natraj Complex 11.B.N.Road Lal Bagh Lucknow U.P. Mobile No.9415006154</p>	<p>Services Consultant :</p> <div style="text-align: center;"> <p>SHAH & PANT CONSULTING ENGINEERS (P) LTD. AN ISO 9001-2008 COMPANY</p> <p><small>(Building services Consultant, Soil & foundation Experts, Highway Engineering)</small></p> <p><small>1, 4th Floor, HALWASIYA COURT, HAZRATGANJ, LUCKNOW (U.P.) Tele. No. : 0522-2230625, Fax : 0522-2230625, Cell : 9839013280, 9415027719 Email : shah_pant@yahoo.co.in, Web : www.shahpantconsultingengineers.com</small></p> </div>
---	---	---	---	--

