



PLOT HOUSE OF DR. BANERJEE

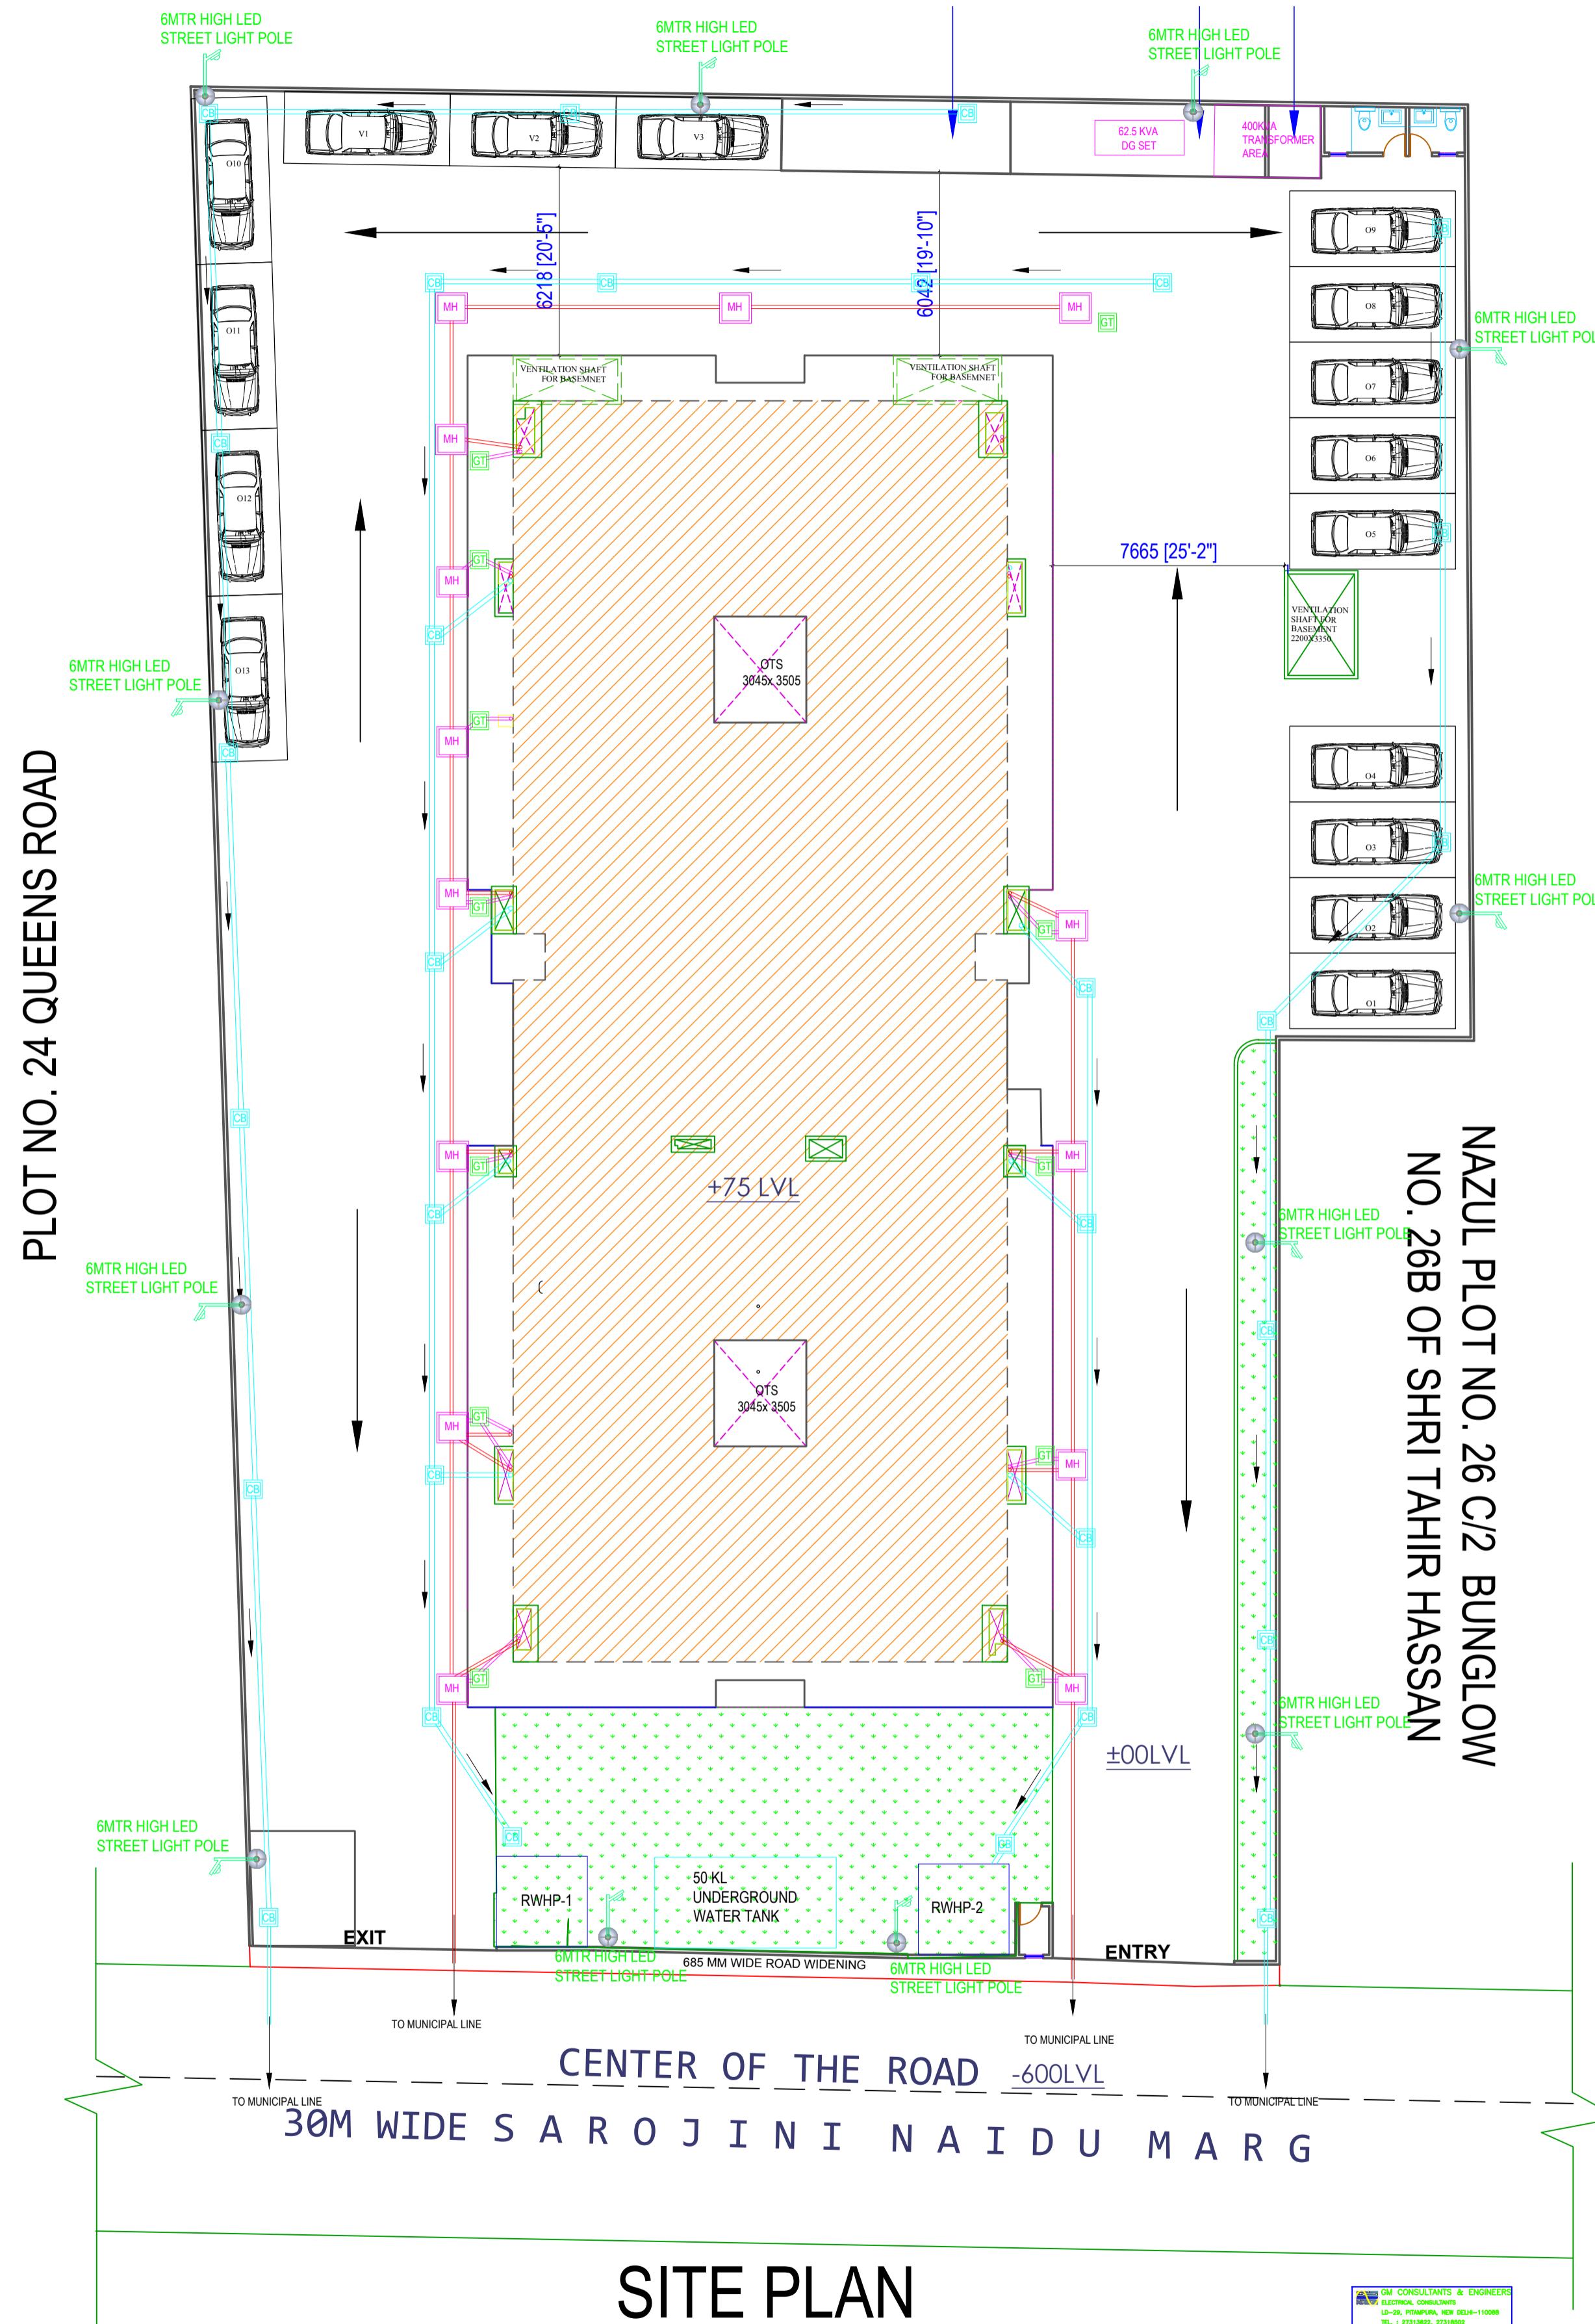

PLOT OF SHRI A.N SHERVANI AND OTHERS NUMBERS AS 26 C/2 BUNGLOW NO. 36C

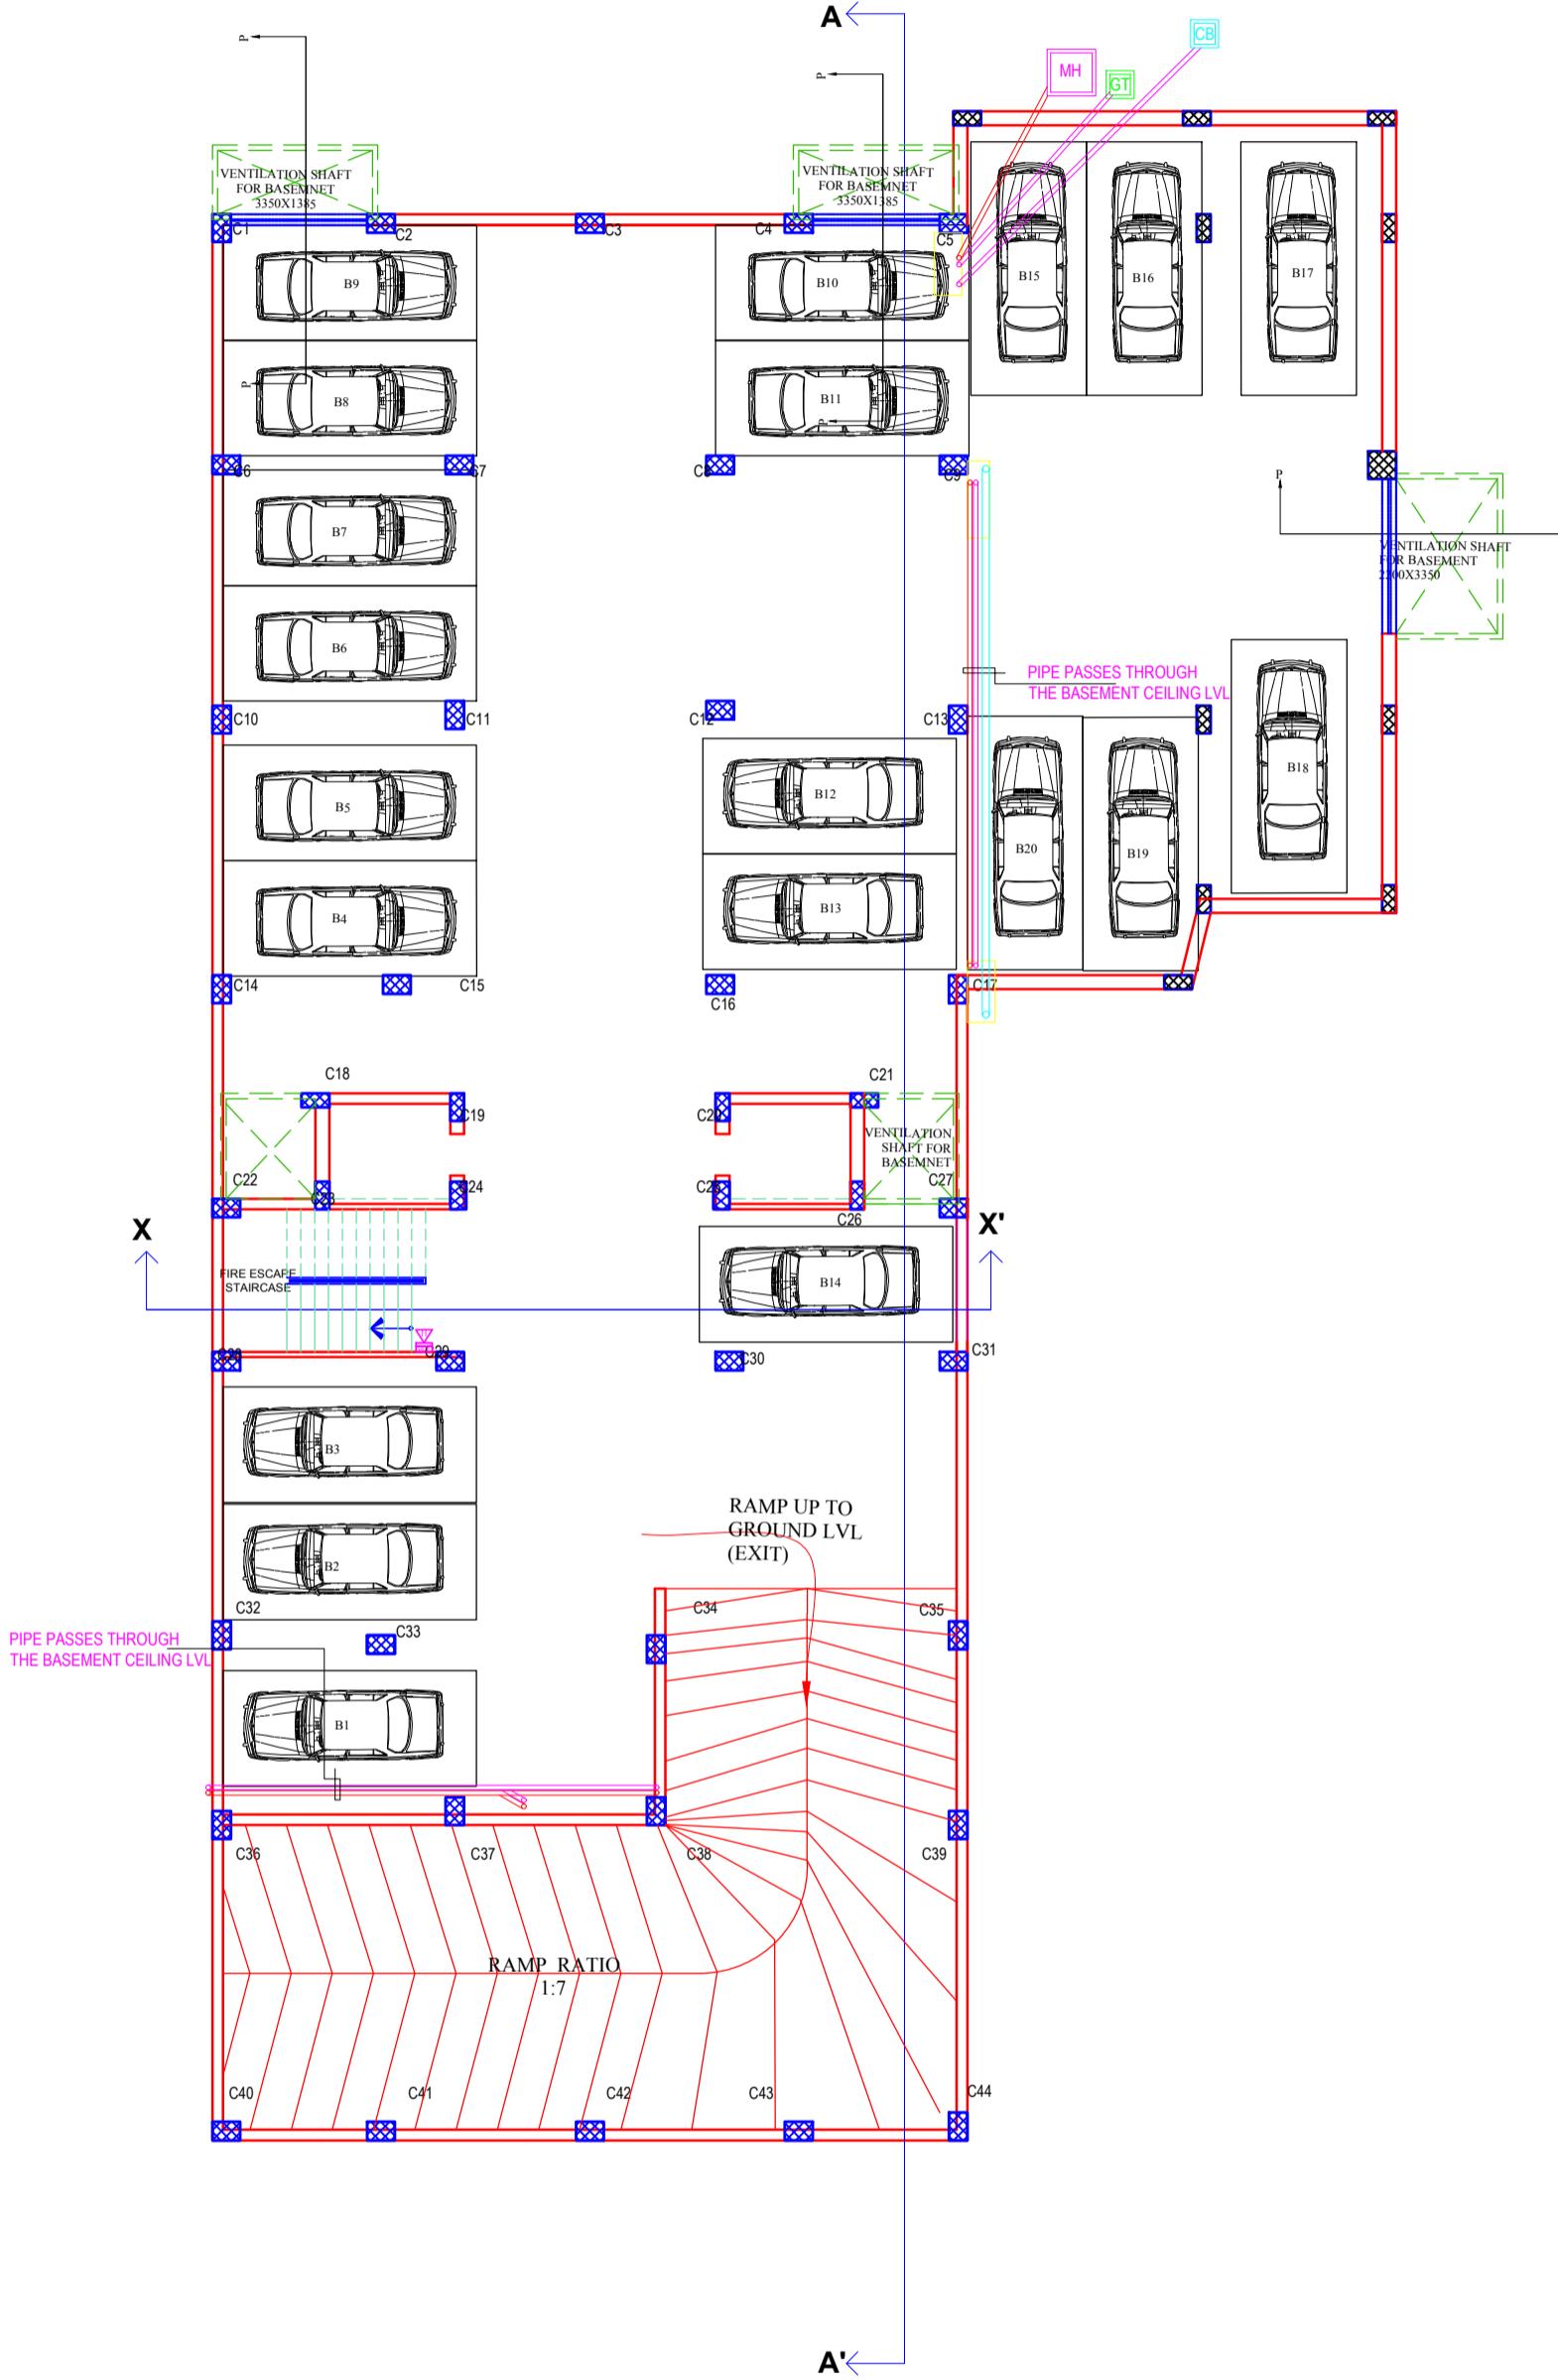

BASEMENT PLAN

PROPOSED GROUP HOUSING ON NAZUL PLOT NO.26-C(PART) CIVIL STATION, PRESENTLY NUMBERED AS 26-C/1, 26-C/3 & 26-C/4, NASIPUR BAKHTIARA (MAUZA) CHIKATPUR, PARGANA & TAHSIL SADAR, DISTRICT ALLAHABAD.

NOTE: THIS PROPOSAL CONFIRMS WITH THE STANDARDS OF "UPVIDHI 2008" and "MAHAYOJANA 2021"

Drawing Title
SUBMISSION DRAWING
PLUMBING PLAN

OWNERS:
MR. A.Q. KHAN
MR. SALEEM IQBAL SHERVANI
M/S SHERVANI INDUSTRIAL SYNDICATE LIMITED

Drg. No. 01/04
SITE PLAN
Scale 1 : 200
Date 06 FEB' 2020
N
North

ARCHITECT SIGN.

Architect
MANISH GUJRAL
(B. Arch, F.I.V.)
TARANA NASEER
(B.Arch, M.Plan)
Architects and Interior Designers
52/ 25 B MUIR ROAD, ALLAHABAD