


PHASE 1

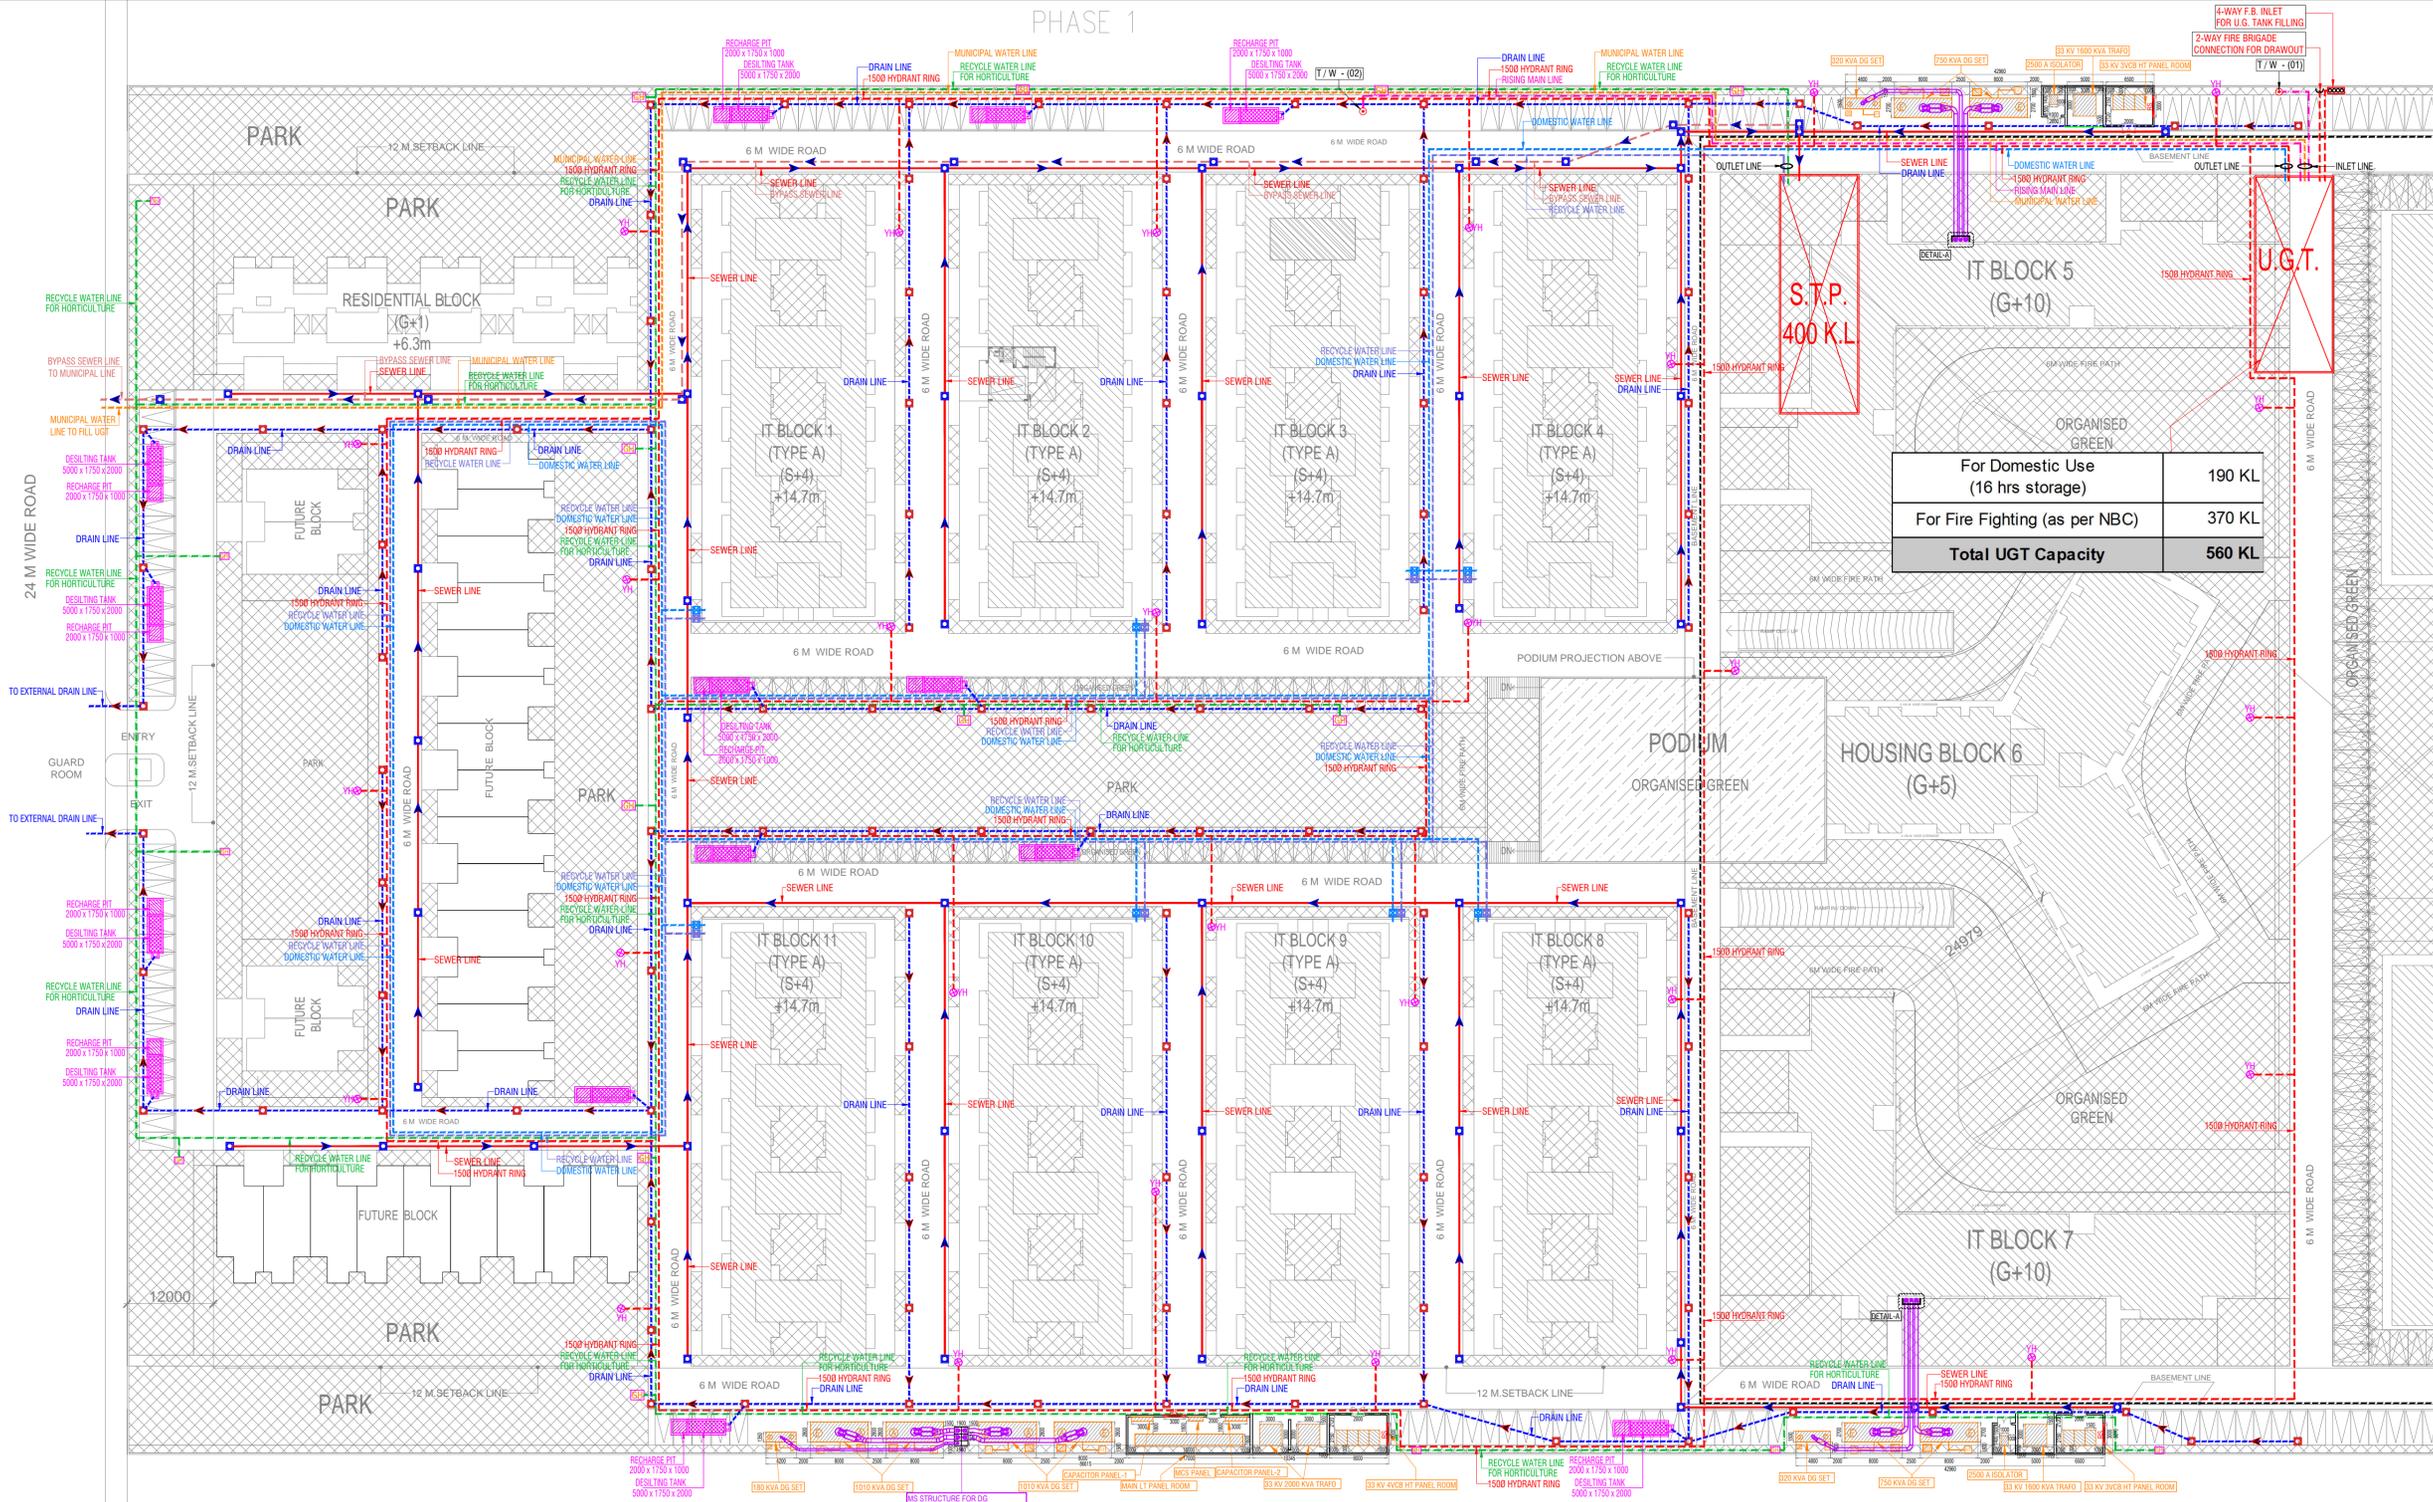

For Domestic Use (16 hrs storage)	190 KL
For Fire Fighting (as per NBC)	370 KL
Total UGT Capacity	560 KL

LEGEND :

S. No.	SYMBOL	DESCRIPTION
1.	M.H.	MANHOLE
2.	—	SEWER LINE
3.	- - -	BYPASS SEWER LINE
4.	C.P.	CATCH PIT
5.	- - -	UNDER GROUND DRAIN
6.	[Pattern]	RAIN WATER HARVESTING
7.	- - -	DOMESTIC WATER SUPPLY PIPE LINE
8.	- - -	RECYCLE WATER SUPPLY PIPE LINE
9.	- - -	RECYCLED WATER SUPPLY PIPE LINE (FOR HORTICULTURE)
10.	- - -	RIISING MAIN WATER PIPE LINE
11.	- - -	MUNICIPAL WATER SUPPLY PIPE LINE
12.	[Symbol]	ISOLATING VALVE
13.	[Symbol]	PROPOSED TUBE WELL
14.	[Symbol]	BASEMENT LINE
15.	[Symbol]	GARDEN HYDRANT

LEGEND : FIRE SYSTEM

S. No.	SYMBOL	DESCRIPTION
1.	- - -	FIRE LINE
2.	[Symbol]	YARD HYDRANT 63 M.M. DIA. SINGLE HEADED HYDRANT VALVE WITH 2 NOS. 15 M. LONG. 63 M.M. DIA. FIRE HOSE PIPE & 1 NO. BRANCH PIPE WITH NOZZLE
3.	[Symbol]	FIRE BRIGADE CONNECTION
4.	[Symbol]	BUTTERFLY VALVE
5.	[Symbol]	NONRETURN VALVE (CHECK VALVE)
6.	[Symbol]	ISOLATING VALVE WITH MASONRY CHAMBER

Rev. no.	Date	Revision

Project
PROPOSED I.T. PARK AT PLOT
 NO-06, K.P.-5, GREATER NOIDA WEST, GAUTAM
 BUDH NAGAR, UP

Owner
ELEGANT IT SOLUTIONS PVT LTD

Title
SITE PLAN

Subtitle
EXTERNAL COMBINED SERVICES

Drawing released for
 APPROVAL SUBMISSION
 ADVANCE COPY CONSTRUCTION

Drg. no. I.T. PARK / EX / S-05 **Drawn by** Kulwant

Scale 1:500 @ A1 **Designed by** R.K.

Date May 2017 **Checked by** Anand Havella

Architects
YUVAN
 195, Ram Vihar, Delhi-92

Services Consultant
Consummate Engineering Services (P) Ltd.
 Noida Office : B - 67, Sector - 67, Noida - 201 301
 Tel : (0120)6943500 (23 Lines)
 Lko. Office : R 006, Rohas Plumeria, Gorri Nagar, Lucknow
 e mail : mail@cespl.in, website : www.cespl.in

