


LOCATION & PROPOSED SITE IN JHANSI MASTER PLAN SCALE 1:4000

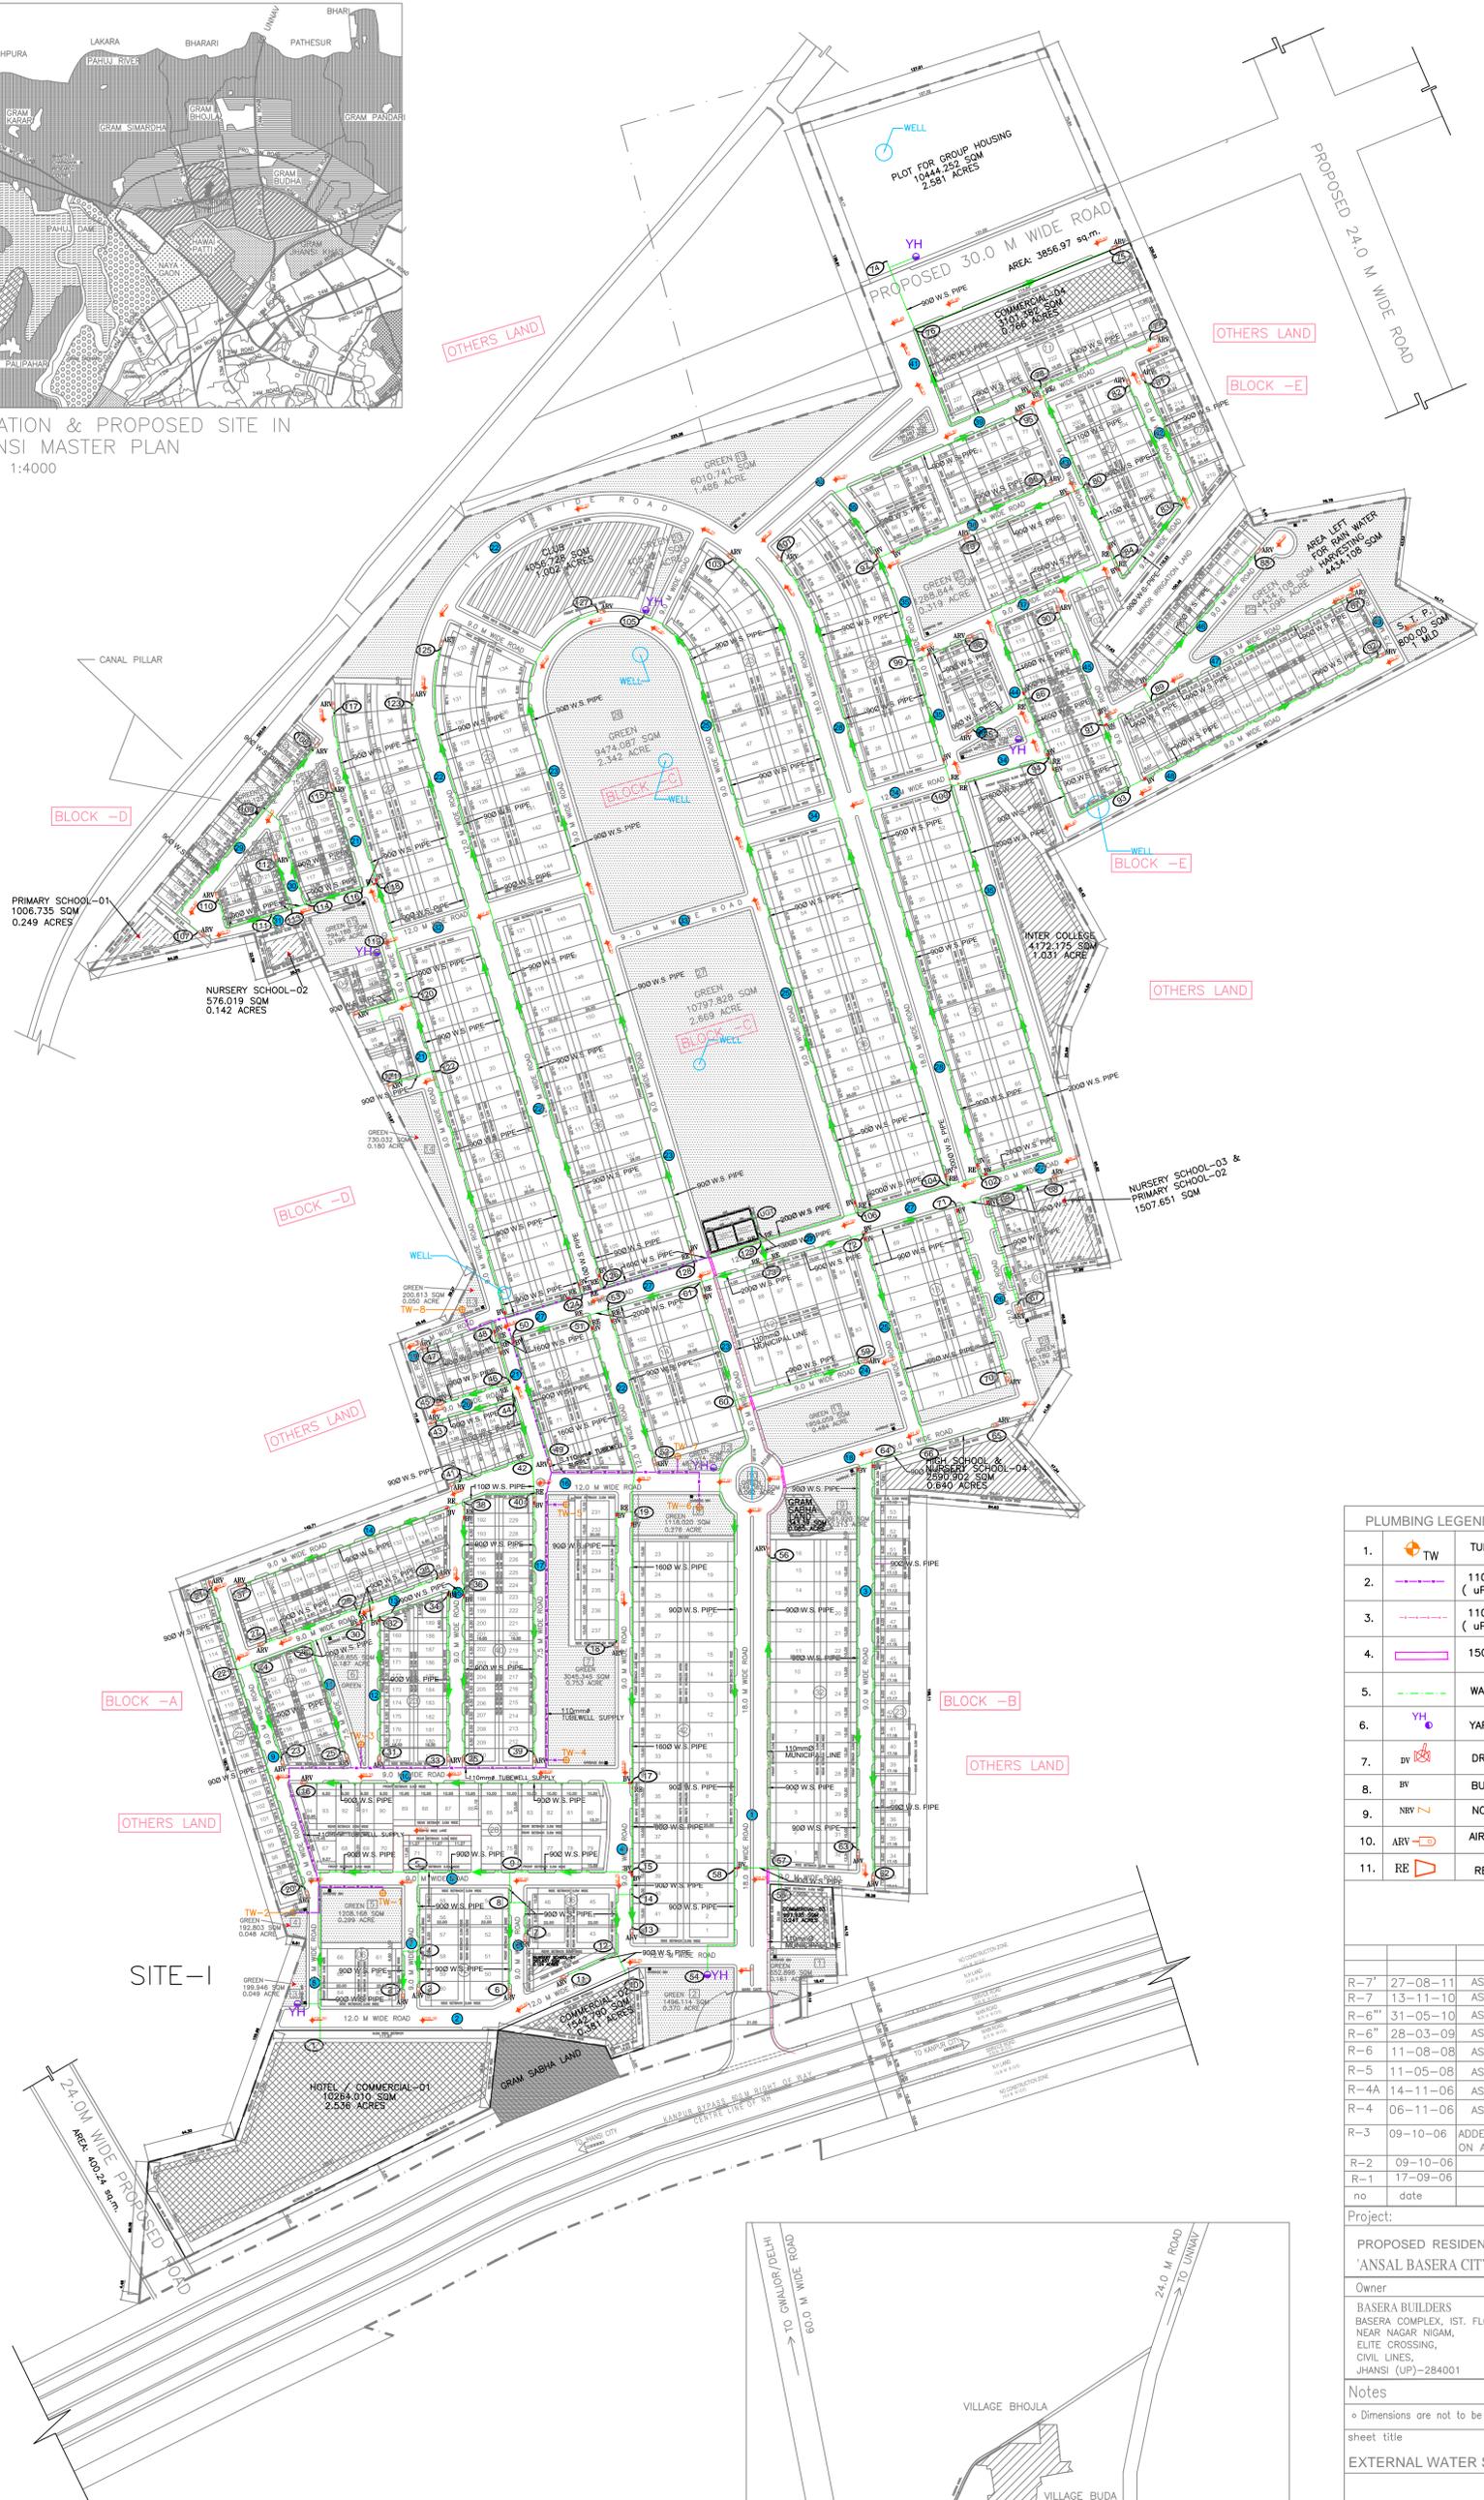

LAYOUT PLAN OF 'ANSAL BASERA CITY'



KEY PLAN (N.T.S.)

PLUMBING LEGEND	
1.	TW TUBEWELL
2.	110mm ϕ TUBE WELL SUPPLY LINE (uPVC PIPE)
3.	110mm ϕ MUNICIPAL SUPPLY LINE (uPVC PIPE)
4.	150MM SLEEVE FOR MUNICIPAL SUPPLY
5.	WATER SUPPLY LINE (uPVC PIPE)
6.	YH YARD HYDRANT
7.	BV DRAIN VALVE
8.	BV BUTTERFLY VALVES
9.	NRV NON RETURN VALVE
10.	ARV AIR RELEASE VALVE
11.	RE REDUCER

R-7'	27-08-11	AS/ARCH. LAYOUT REVISED	Ganesh
R-7'	13-11-10	AS/ARCH. LAYOUT REVISED	Sandeep
R-6''	31-05-10	AS/ARCH. LAYOUT REVISED	Sandeep
R-6''	28-03-09	AS/ARCH. LAYOUT REVISED	Sandeep
R-6	11-08-08	AS/ARCH. LAYOUT REVISED	ganesh
R-5	11-05-08	AS/ARCH. LAYOUT REVISED	ganesh
R-4A	14-11-06	AS/ARCH. LAYOUT REVISED	ganesh
R-4	06-11-06	AS/ARCH. LAYOUT REVISED	ganesh
R-3	09-10-06	ADDED DETAIL OF RECHARGEWELL ON ARCH. REVISED LAYOUT	ganesh
R-2	09-10-06	LAYOUT REVISED	ganesh
R-1	17-09-06	LAYOUT REVISED	ganesh
no	date	description/revision	sign

Project:
PROPOSED RESIDENTIAL COLONY 'ANSAL BASERA CITY' at Jhansi
 Owner:
 BASERA BUILDERS BASERA COMPLEX, IST. FLOOR NEAR NAGAR NIGAM, ELITE CROSSING, CIVIL LINES, JHANSI (UP)-284001
 MADAKINEE ESTATE PVT. LTD. 118, U.F.F., PRAKASH DEEP, 7 TOLSTOY MARG NEW DELHI-110001. Ph:- 23353051,23353052, FAX:-91-23310639

Notes
 * Dimensions are not to be scaled.
 sheet title
EXTERNAL WATER SUPPLY LAYOUT
 Architect's Signature
 Owners' Signature
 dealt Ganesh date 31.07.06 dwg no.
 checked Rajeev scale 1:750 ABL/JH/WS/SUB/LA-04 R-7
 Sr.G.M.(SERVICES)
 CAURAV MOHAN PURI CHIEF ARCHITECT
 ARCHITECTS
ANSAL BUILDWELL LTD.
 118, U.F.F., PRAKASH DEEP, 7 TOLSTOY MARG NEW DELHI-110001.

