

SEWERAGE LEGENDS	
SYMBOL	DESCRIPTION
MH	MANHOLE 900X800
MH	CIRCULAR MANHOLE
—	SEWER LINE
G.L.	GROUND LEVEL
I.L.	INVERT LEVEL
C.L.	CONNECTING LEVEL

DRAINAGE LEGENDS	
SYMBOL	DESCRIPTION
DMH	DRAINAGE MANHOLE
CB	CATCH BASIN 450X450
—	DRAINAGE LINE
G.L.	GROUND LEVEL
I.L.	INVERT LEVEL
C.L.	CONNECTING LEVEL

WATER SUPPLY LEGENDS	
SYMBOL	DESCRIPTION
CMS	COLD WATER SUPPLY
—	GARDEN WATER SUPPLY LINE
—	GARDEN HYDRANT
—	YARD HYDRANT
—	BORE WELL SUPPLY LINE
—	MUNICIPAL SUPPLY MAIN LINE

PROPOSED GROUP HOUSING PLAN OF ROYAL GREENS MS OMEGA DEVCON (P) LTD.
 SITE AT - KHASRA NO. - 71,72,73, 74 GRAM MANOHARPUR, DELHI ROAD, MORADABAD.

OWNERS - M/s. VASDEVA AWARD RAMI


APPROVED BY	DATE
WORKERS	

DRG. TITLE	SITE PLAN
SCALE	1:500
	NORTH

OWNER/SIGN


ARCHITECT SIGN

R.K.MALIK ASSOCIATES
 ARCHITECT - ENGINEER
 INTERIOR - EXTERIOR
 ENVIRONMENTAL CONSULTANT
 GANANSI, IRAS, MARGELI
 GATE NO. 10, PHASE - II
 INDRA PRASTH
 NEW DELHI - 110028

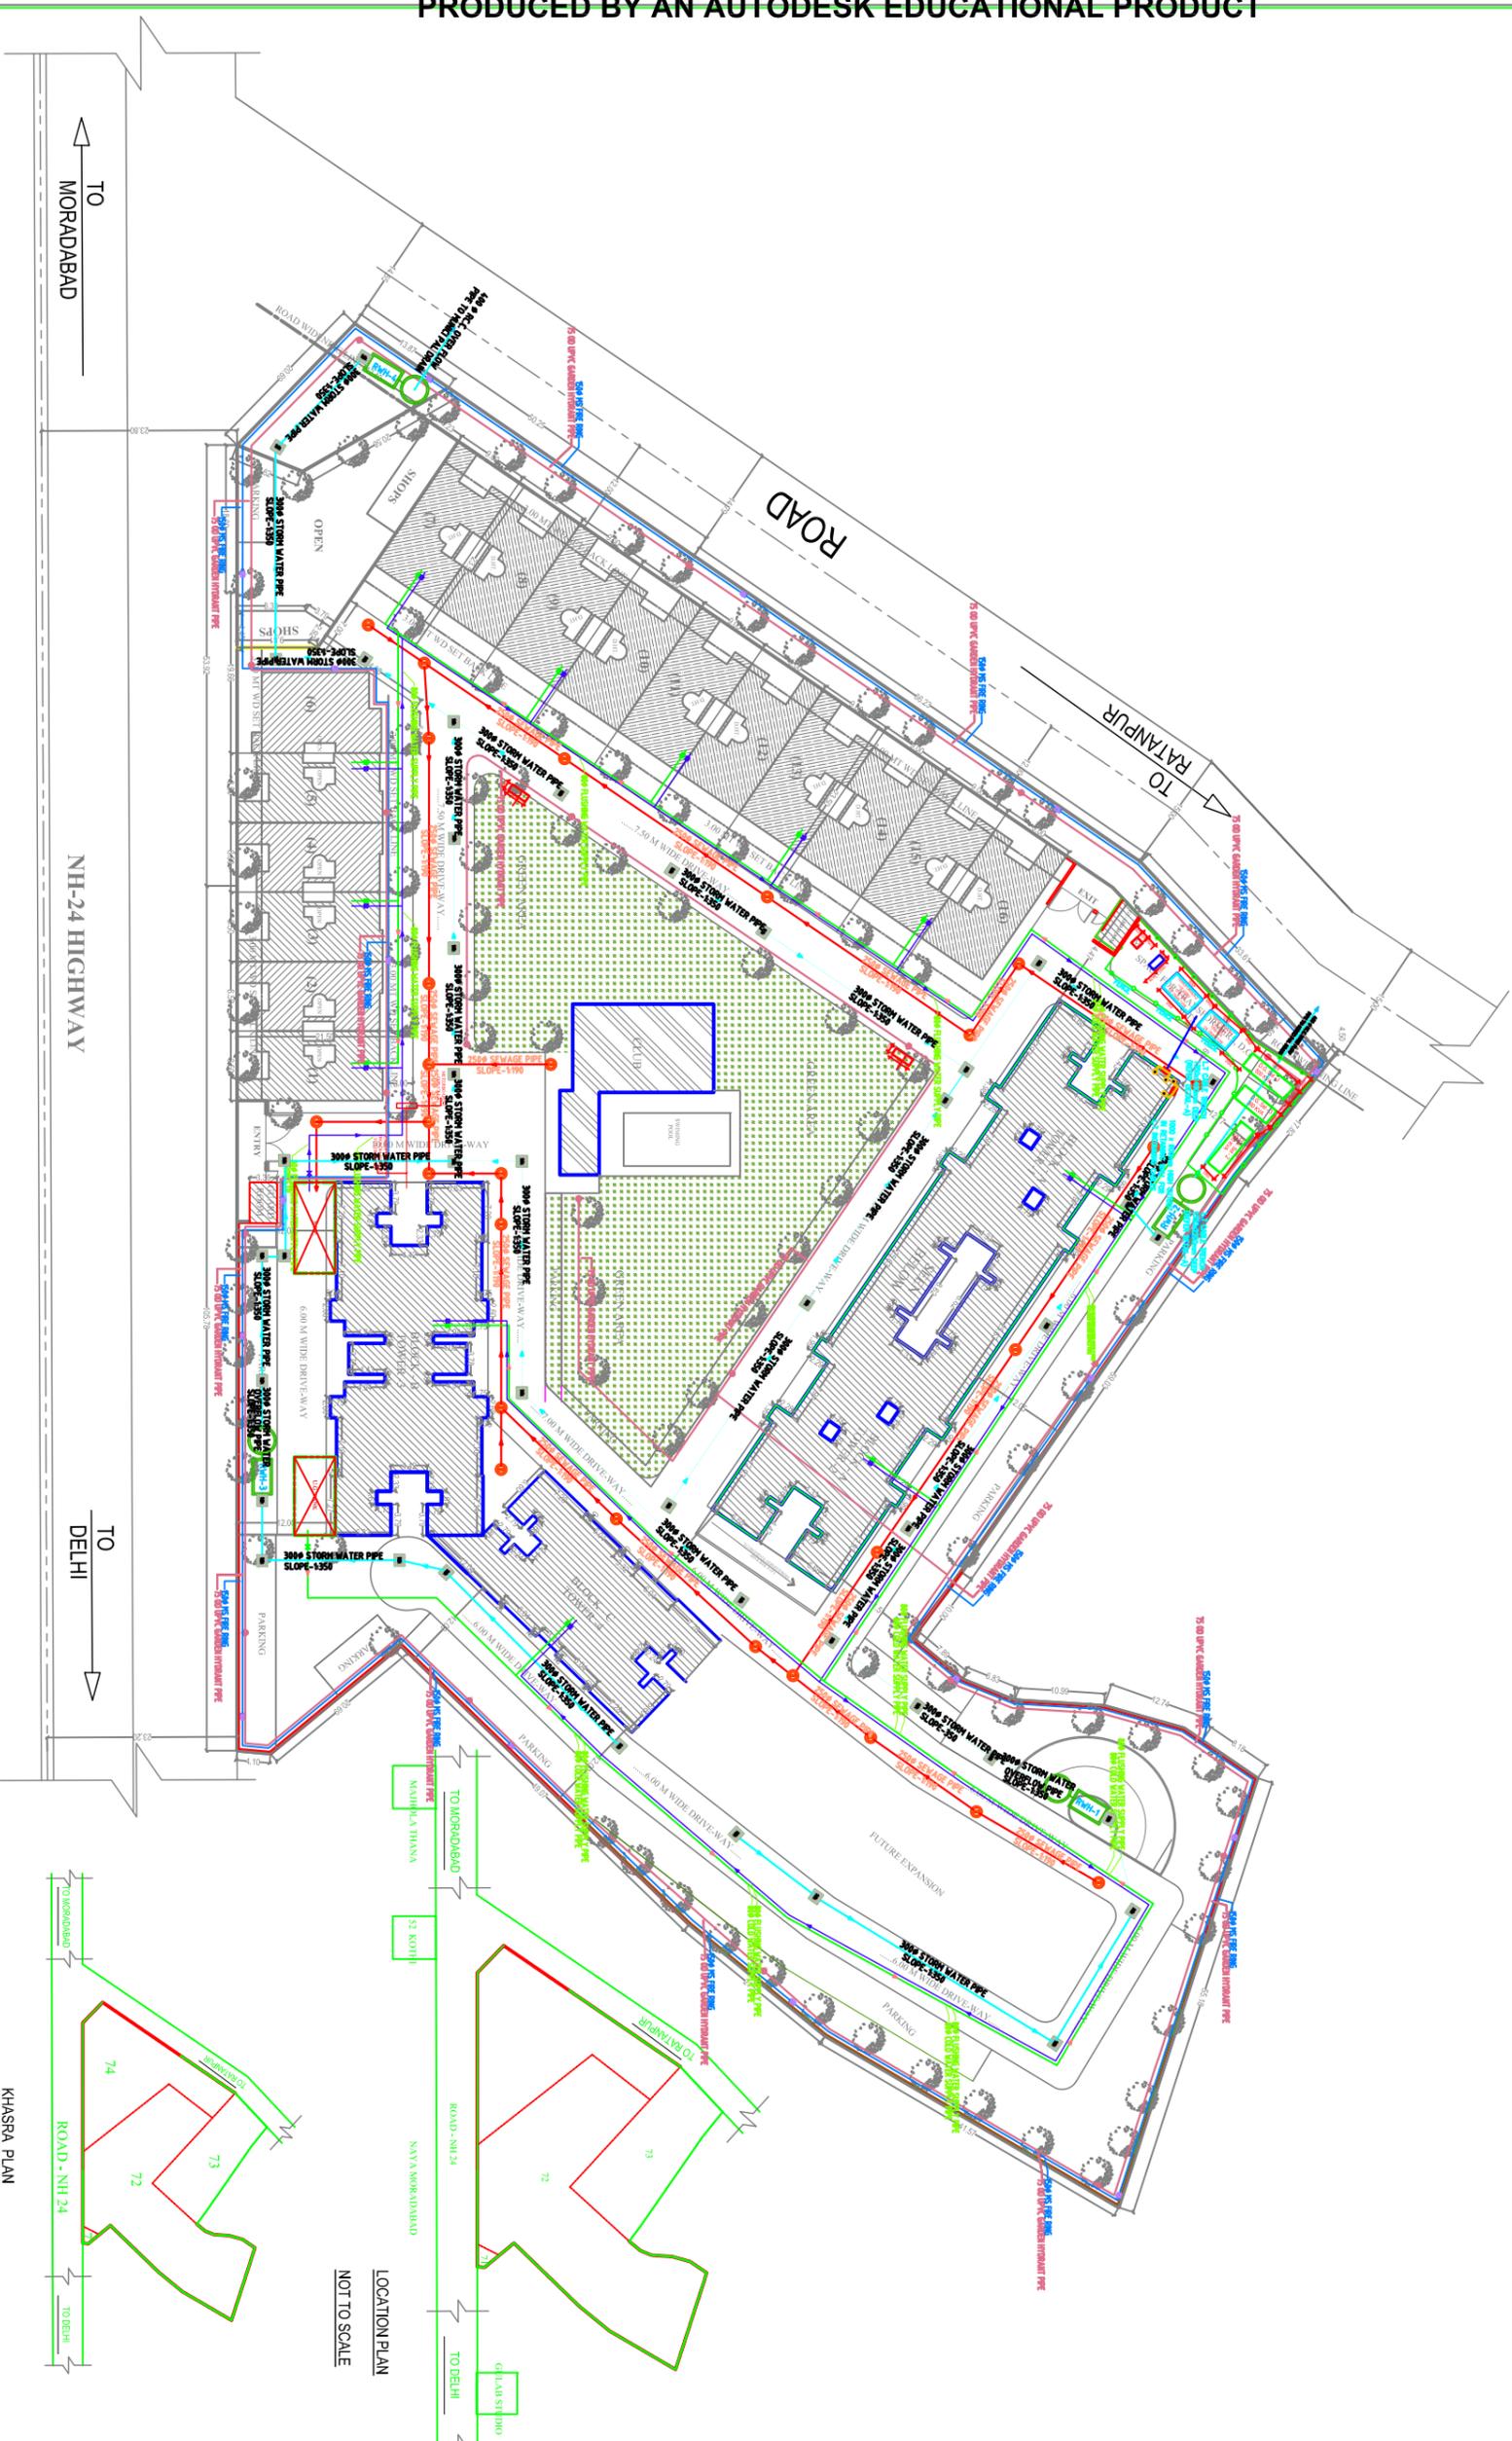

SITE PLAN