


PLUMBING LEGEND :

	STORM WATER MANHOLE WITH 5600 S.F.R.C. PERFORATED MANHOLE COVER.
	SEWER MANHOLE WITH 5600 S.F.R.C. MANHOLE COVER.
	CATCH BASIN (450 x 450) MM WITH PERFORATED MANHOLE COVER
	CATCH BASIN (600 x 600) MM WITH PERFORATED MANHOLE COVER
	EXTERNAL ROC STORM WATER LINE (DIA AS / DRAWING)
	DI MUNICIPAL WATER SUPPLY LINE
	TUBE WALL WATER SUPPLY LINE
	GARDEN IRRIGATION WATER SUPPLY LINE
	GARDEN HYDRANT WITH CHAMBER (300x300) MM
	R.P RECHARGE PIT (3.0M DIA)
	D.C. DESILTING CHAMBER (1500 x 3000) MM
	BUTTERFLY VALVE WITH CHAMBER
	NON RETURN VALVE (NRV) WITH CHAMBER

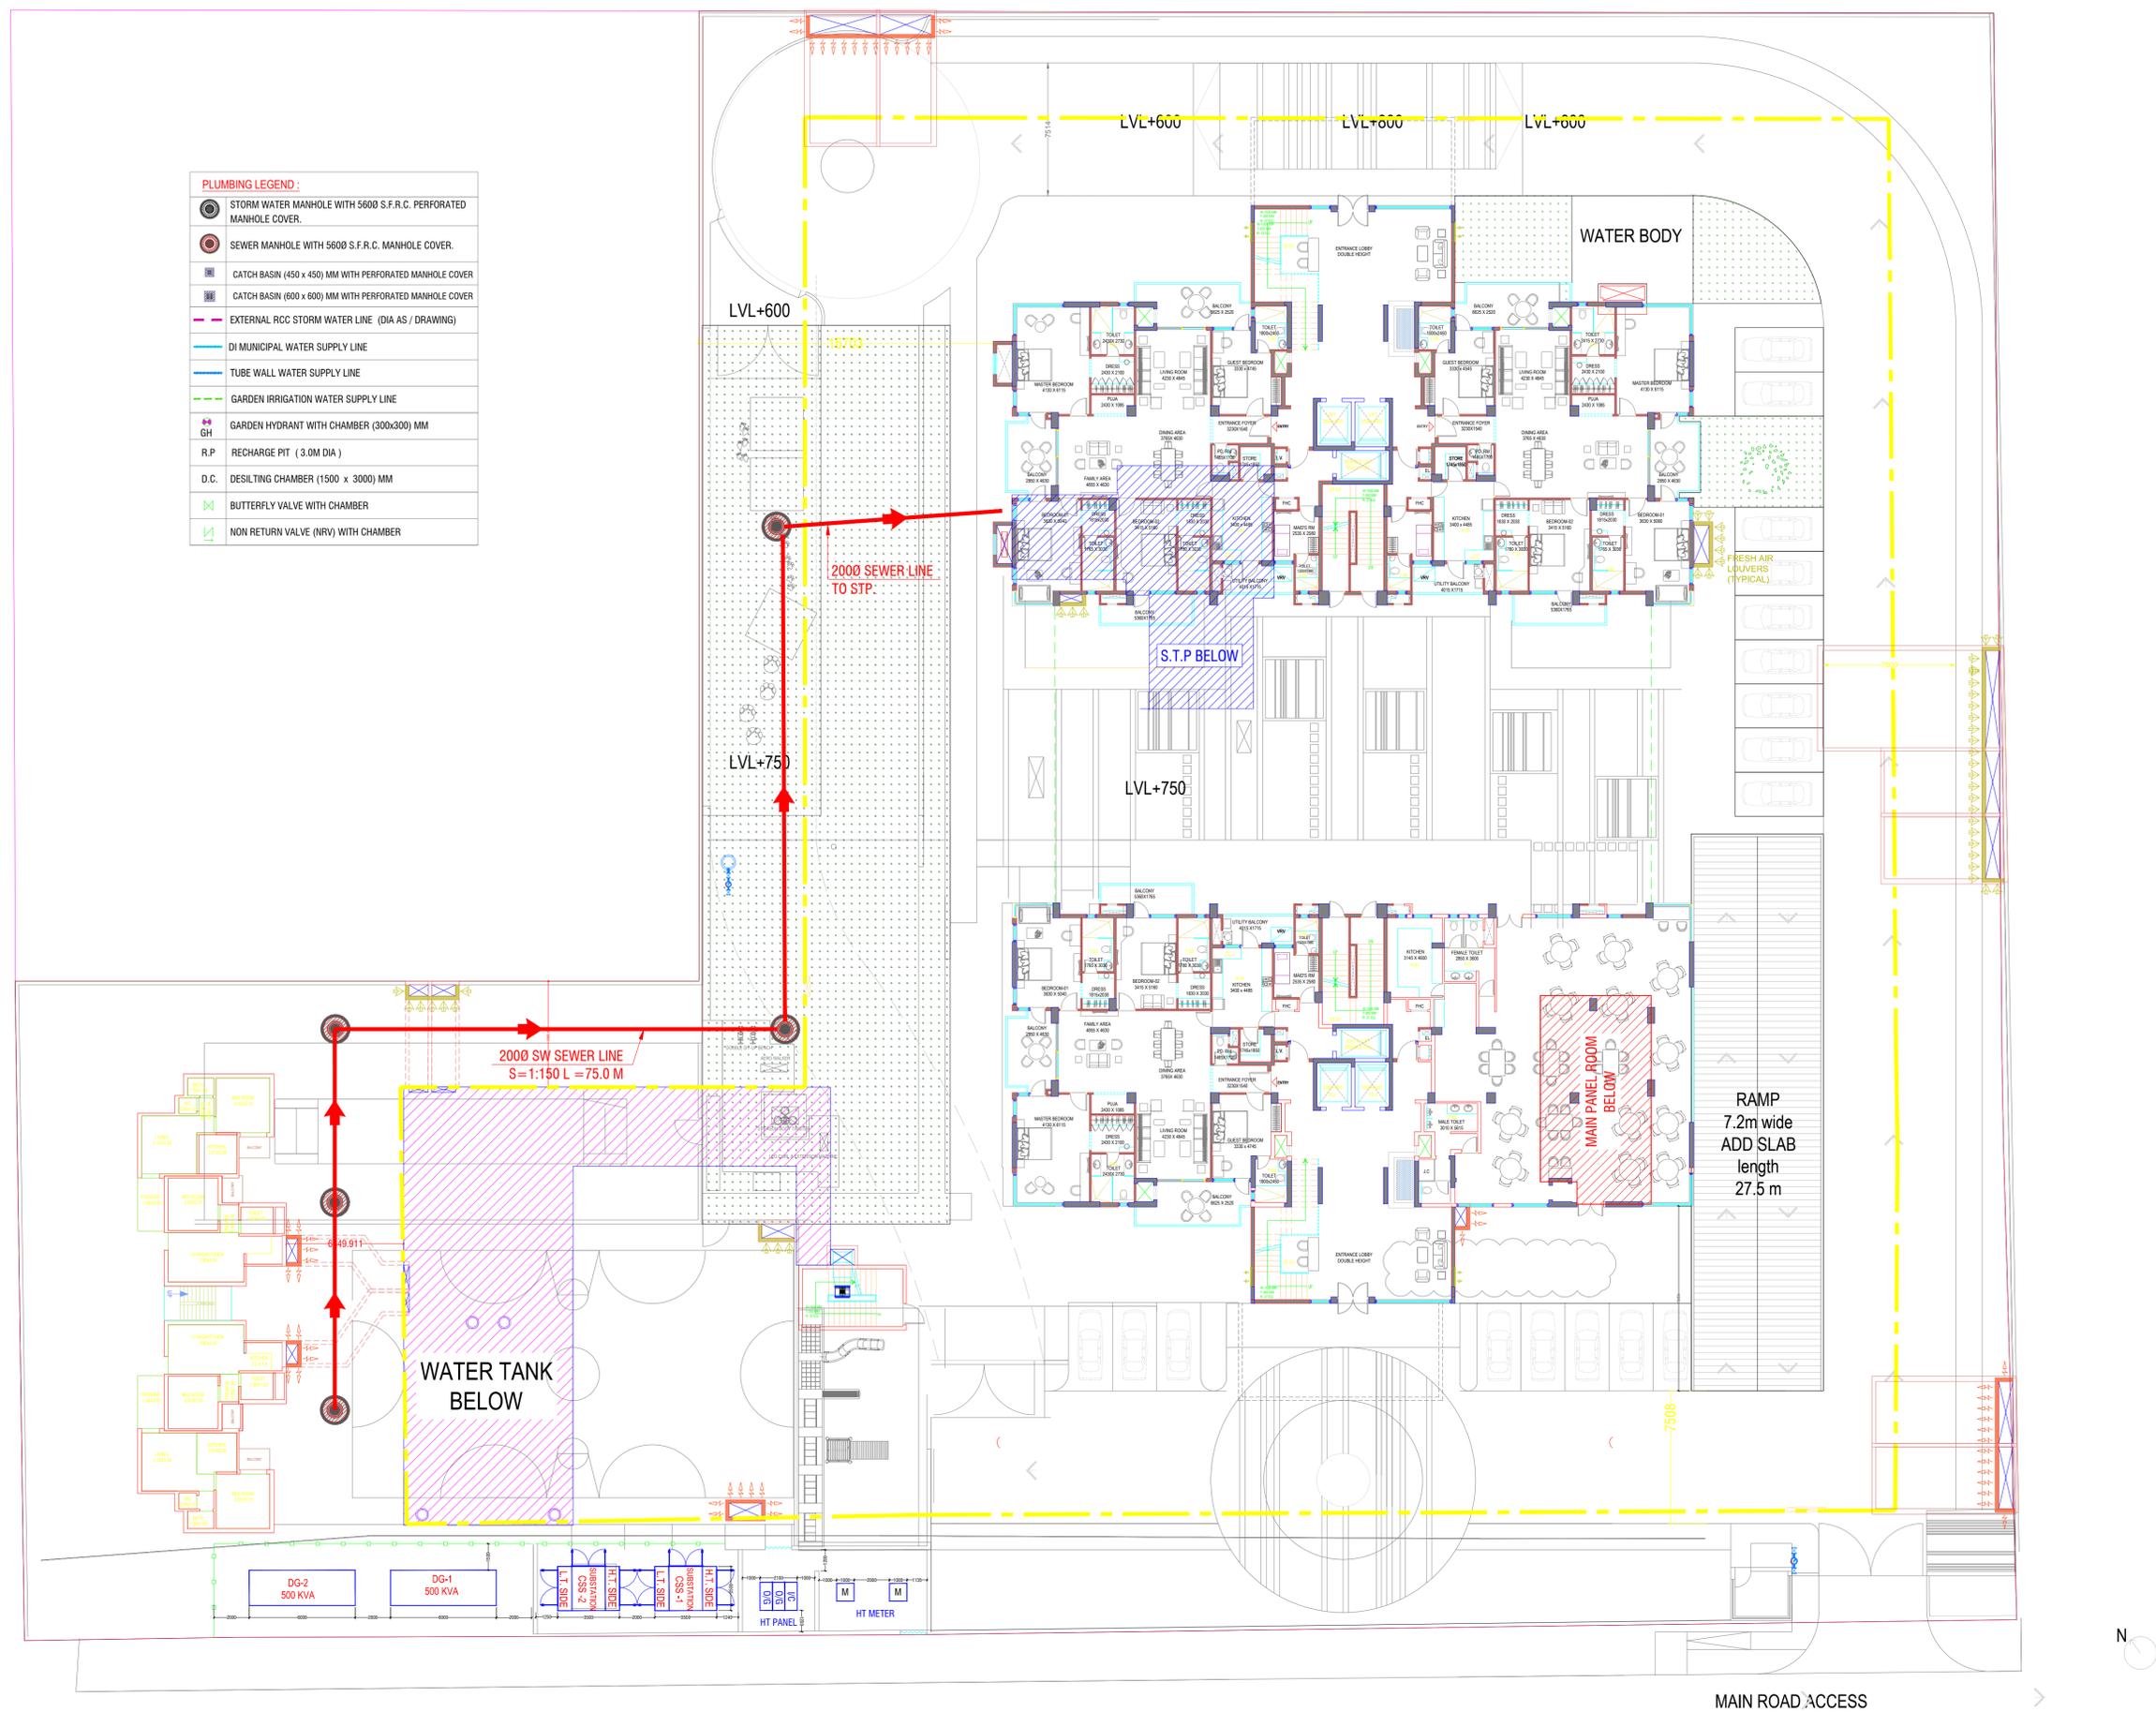

ISSUES

NO.	DATE	BY	DESCRIPTION	PRINTS

REVISIONS

NO.	DATE

SUBMISSION DRAWING

PROJECT
SHALIMAR GALLANT EXTENSION

CLIENT:
SHALIMAR CORP. LTD.

ARCHITECTS:
Arcop Associates Private Limited.
Plot No-36 B, Sector-32,
Gurgaon, India
Ph: +91-124-4595500
Fax : +91-124-4595500

MEP CONSULTANTS:
PARADISE CONSULTANTS
Plot No. 96, Basement,
Near Living Style Mall, Jasola Vihar
New Delhi - 110025
Landline:-011-29943601, 26943216
E-mail: paradiseconsultants@gmail.com

DRAWING TITLE :
**EXTERNAL SITE PLAN
SEWER LAYOUT**

scale : 1:175 (A1) drawn by : **MAN SINGH**
date : 22/06/22 checked by : **ANIL**
project no : ----- approved by : **NAFEES**
drawing no : -----

PL-PC-GALLANT-SITE-101

REVISION

RO				
----	--	--	--	--