


45.0 MT. WIDE ROAD

This drawing is a "COPYRIGHT" contents of this drawing or part thereof may not be used or reproduced without the permission of the Architect



PROJECT
 PROPOSED GROUP HOUSING-1, AT KHASRA NO.400,401,402,403,404,405,406,407(P)408(P), 409-410,411-412(P),480(P),497 & 446(G.S) IN OMAXE INTEGRATED TOWNSHIP AT SULTANPUR ROAD , LUCKNOW U.P.

36.0 MT. WIDE ROAD

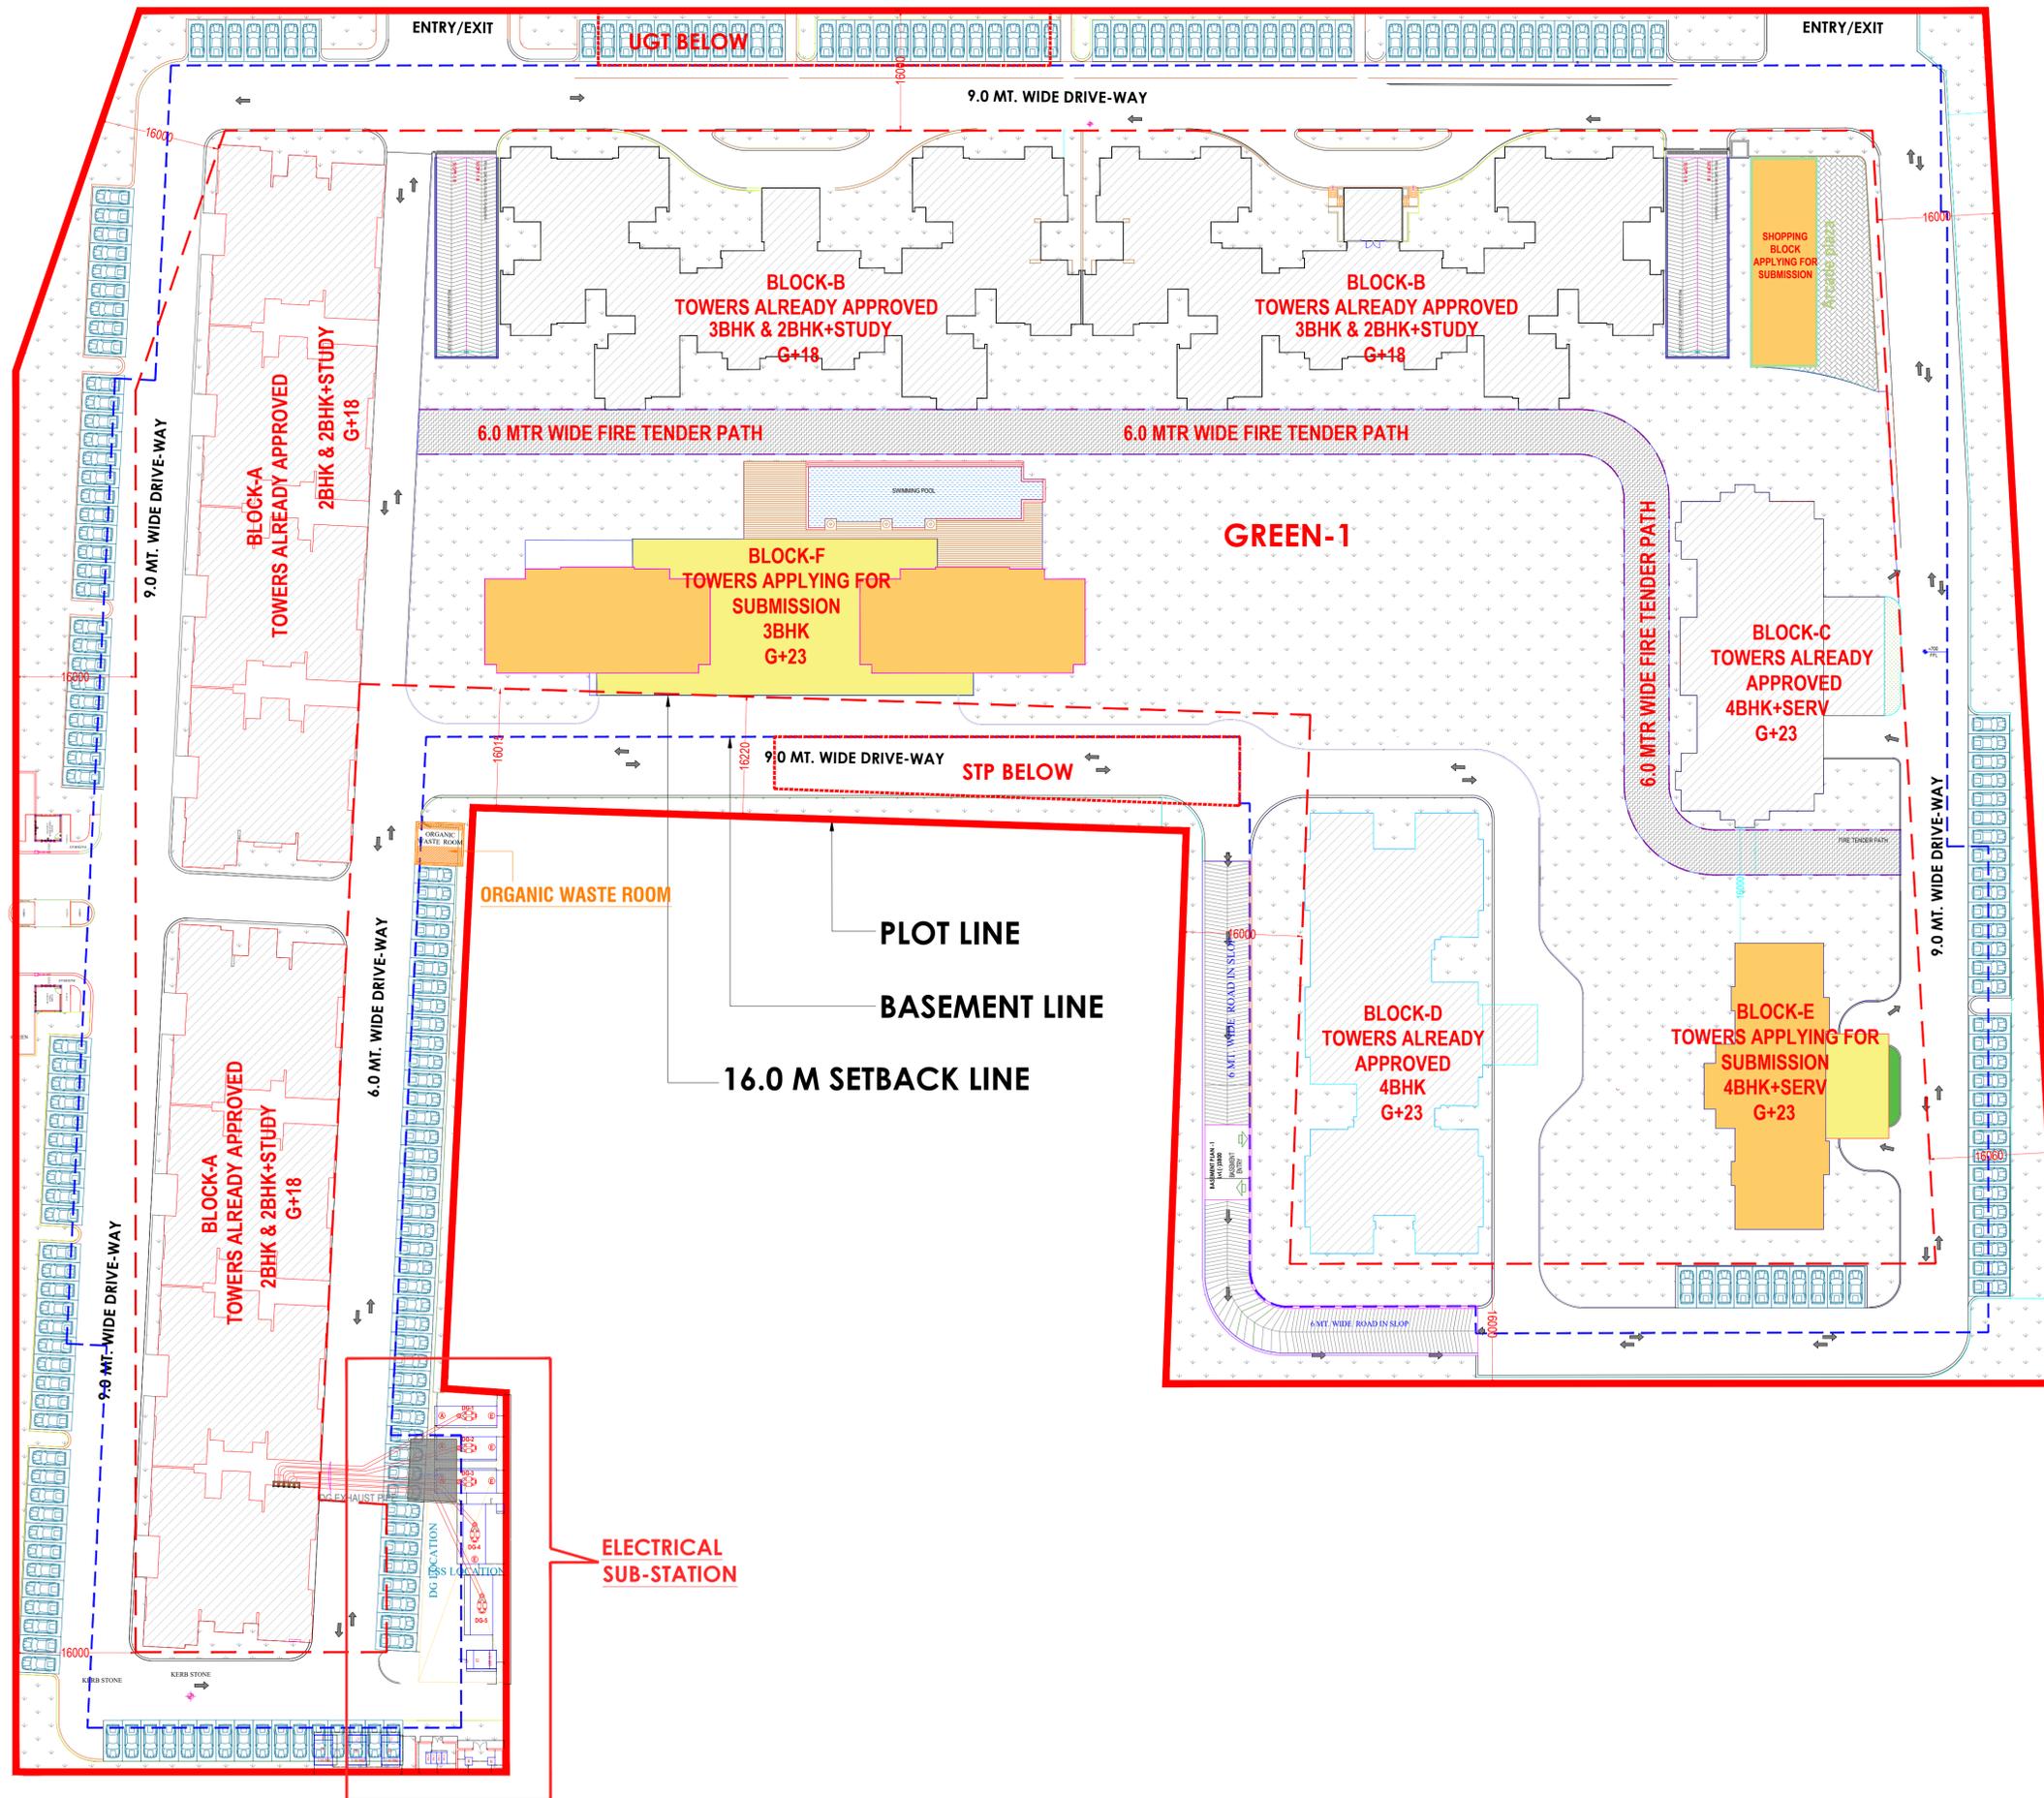

DRAWING TITLE
ELECTRICAL PLAN

SCALE
 N.T.S.

DATE
 JAN - 2025

ARCHITECT
 CLIENT/ OWNERS

DRAWING NUMBER-