


	STORM WATER LINE
	SEWER LINE
	CWS-COLD WATER SUPPLY LINE
	FWS-FLUSHING WATER SUPPLY LINE
	GARDEN HYDRANT LINE
	MANHOLE STORM WATER
	MANHOLE SEWER
	rain water harvesting
	desalting chamber

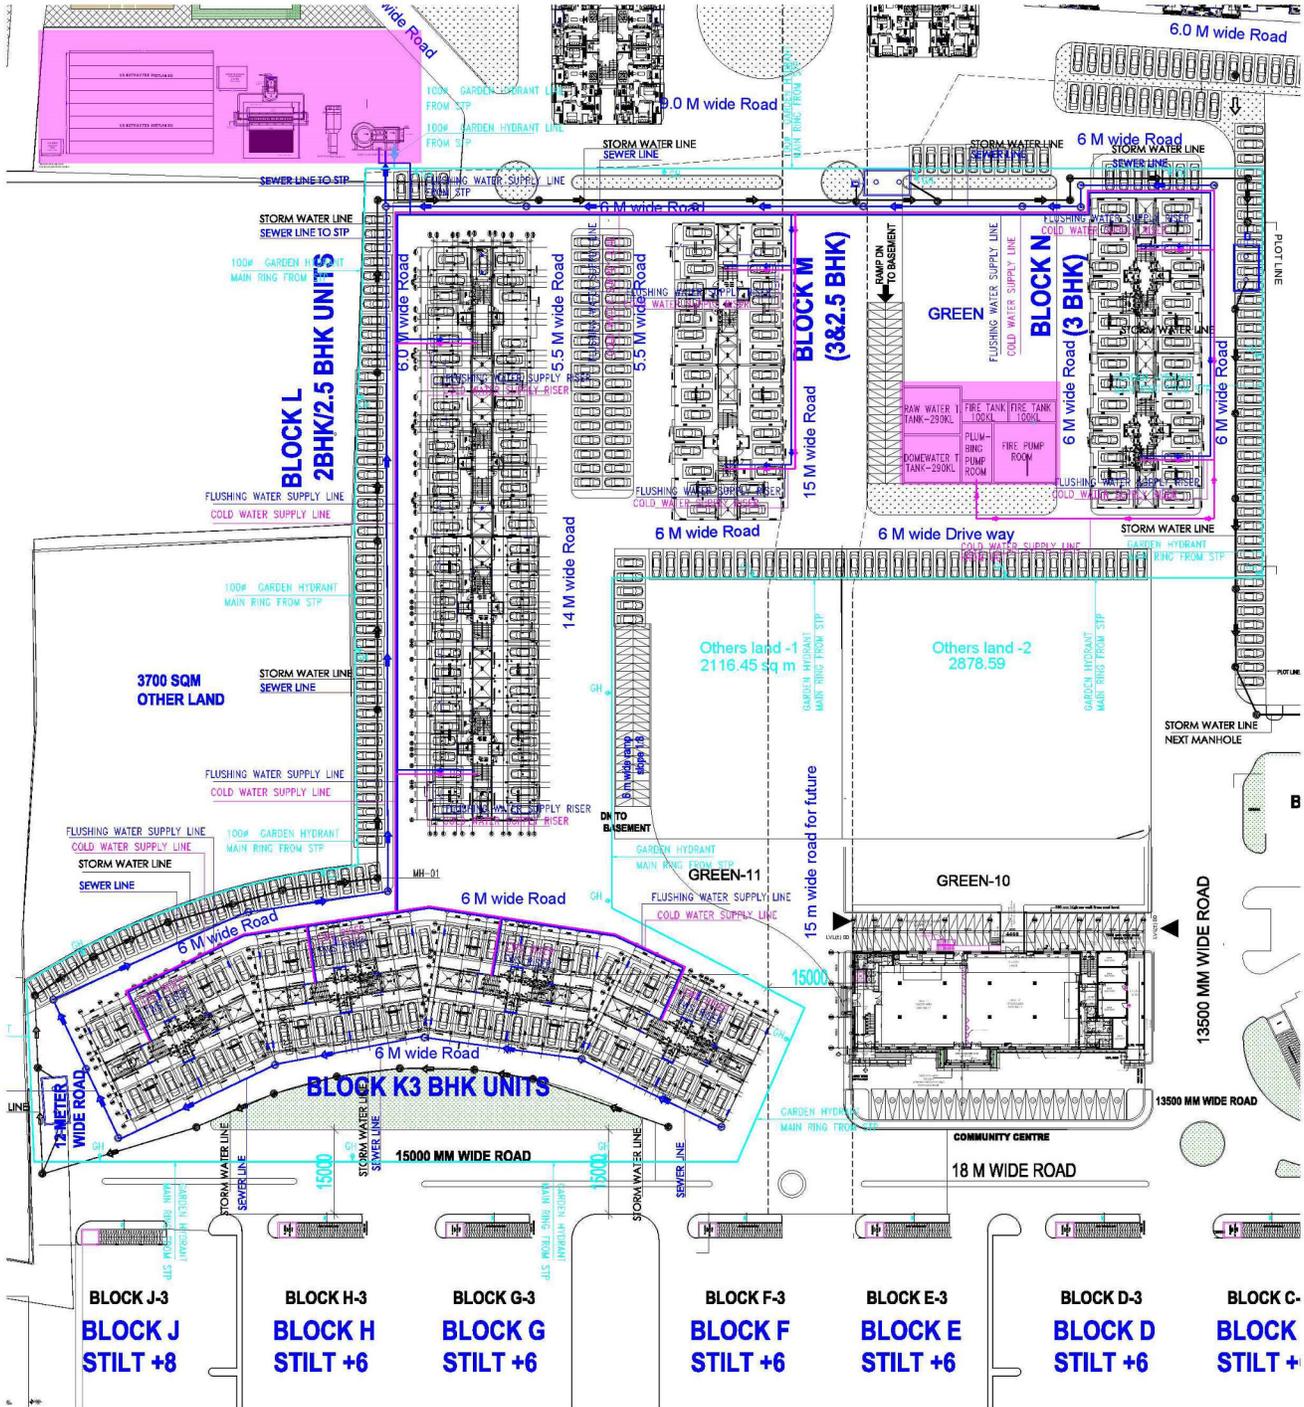

NOTES

- ALL DIMENSIONS ARE IN MM UNLESS NOTED OTHERWISE.
- ALL DIMENSIONS ARE TO BE READ AND NOT TO BE MEASURED.
- ALL LEVELS ARE IN MILLIMETRES.
- THE CONTRACTOR SHALL VERIFY ALL DIMENSIONS, DETAILS, SPECIFICATIONS & DATE CONDITIONS & SHALL REPORT ANY ERROR, OMISSION AND/OR INADEQUACY TO THE ARCHITECT BEFORE COMMENCEMENT OF WORK.
- FOR CONTRACTOR SUPPLIERS, THE DIMENSIONS SHALL NOT BE MEASURED DIRECTLY ON THE DRAWINGS. THE DIMENSIONS SHALL NOT BE USED FOR CONSTRUCTION UNLESS THEY ARE ISSUED FOR CONSTRUCTION.
- THIS DRAWING IS THE PROPERTY OF THE ARCHITECT AND IT SHOULD NOT BE COPIED AND REPRODUCED BY ANY OTHER PERSONS FOR ANY PURPOSES WITHOUT THE WRITTEN PERMISSION OF THE ARCHITECT.

S.NO	DATE	REVISIONS
4.		
3.		
2.		
1.		

REVISION CHART

PLUMBING & FIREFIGHTING CONSULTANTS

BEHERA ASSOCIATES PVT.LTD
 F-102A, LAD BAHN SECTOR 08D DIL्ली 110060
 PHONE: 011-4538388
 MOBILE: 9810181463
 EMAIL: office@beheraassociates.com

PROJECT
SHALIMAR MANNAT
PHASE-2

DRAWING TITLE
PL-EXTERNAL
SITE PLAN
PLUMBING LAYOUT

CONSULTANTS

jsr
 architecture. interiors. pnc
 C-67, Defence colony New delhi
 Phone: 011-42080080, Email: info@jsr.com

Scale	N.T.S
Date	
Drawn	SAJJAN
Checked	S.BEHERA
DRG. NO.	SH/MPH-2/PL/SUB/100
REV.	

