


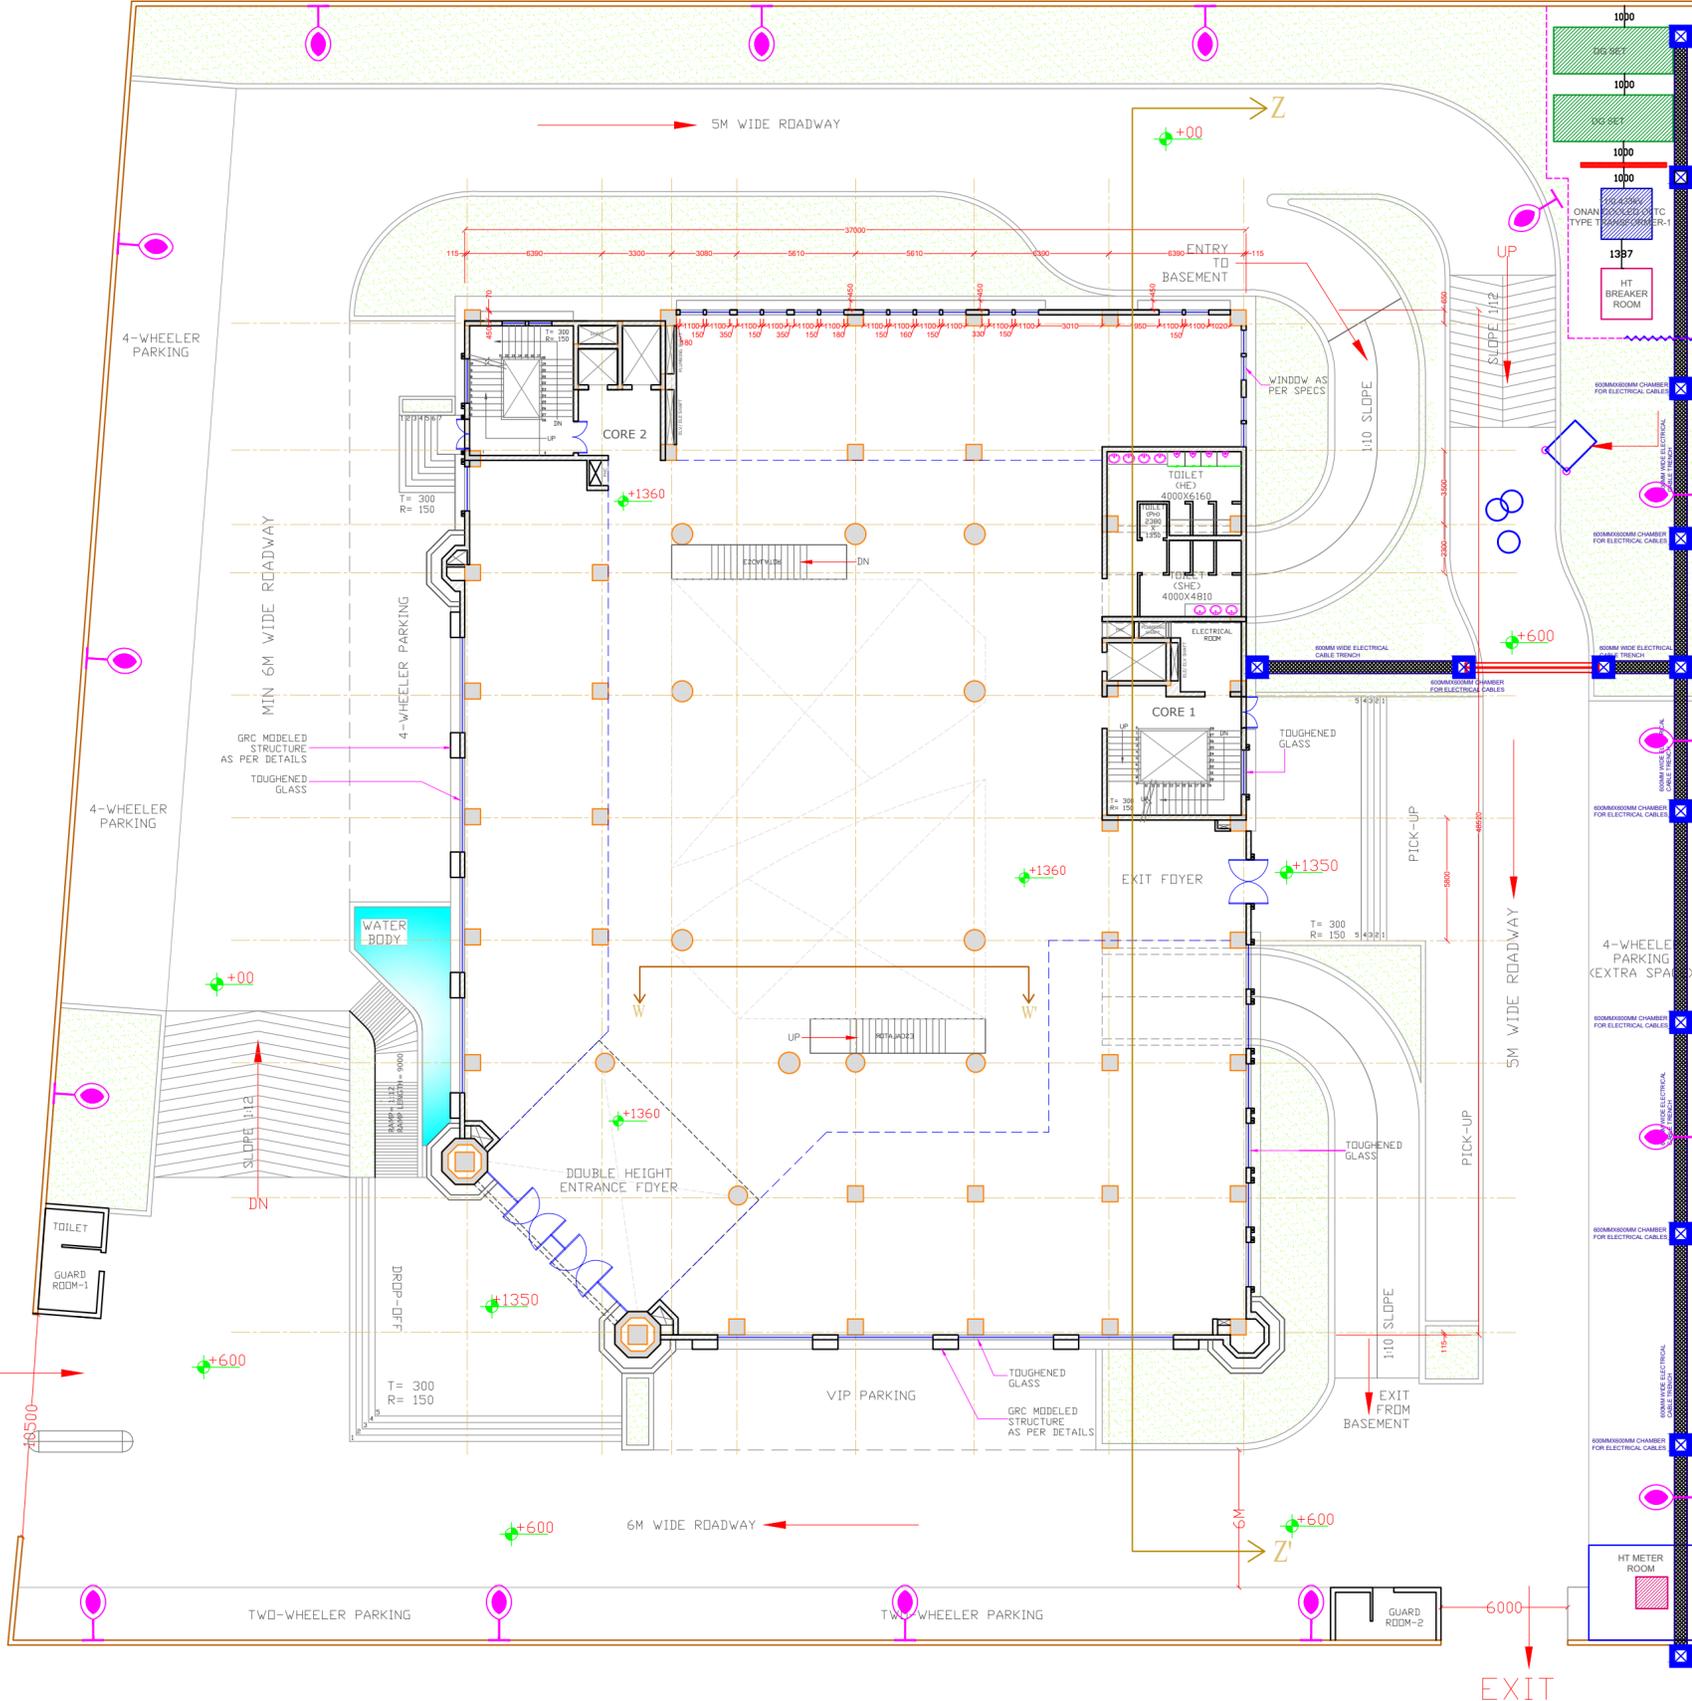

24.0 M WIDE ROAD

MAIN ENTRY

18.0 M WIDE ROAD



DRAWING ISSUE REGISTER			
SL. NO.	DATE	ISSUED TO	INITIALS
1	21-09-2022	Mr. P.K. GUPTA (AE BDA)	
2	12-11-2022	AE BDA / JE BDA / CONTRACTOR	
3	18-09-2023	AE BDA / JE BDA / CONTRACTOR	

REVISIONS			
SL. NO.	DATE	DESCRIPTION	INITIALS
1	12-11-2022	DRAWING UPDATED	SA

PROJECT TITLE:-
MULTISTOREY OFFICE COMPLEX AT SECTOR-2, RAMGANGA NAGAR SCHEME, BAREILLY

BUILDING TITLE:-
MULTISTOREY OFFICE COMPLEX

DRAWING TITLE:-
GROUND FLOOR EXTERNAL ELECTRICAL PLAN

MEP CONSULTANT
GNV CONSULTANTS
F2-233, Khimji Park Road, Khatipara, Jaipur-302012,
Email: - Singhganes@gnv.com
consultant.gnv@gmail.com

DATE	12-11-2022	SHT NO.	
DRN	BANKHT	BAREILLY DEVELOPMENT AUTHORITY	
TCD			
CHKD			
SCALE	AS SHOWN		

ARCOM
Shri KAILASHAM, 714, JANAKPURI,
Bareilly 243122
Mob: 9837095138
email: sumit.architects@gmail.com
sumit.architects@yahoo.com