

- PLUMBING LEGENDS**
- 1 - 100 MM DIA SOIL WASTE PIPE
 - 2 - 100 MM DIA WASTE PIPE
 - 3 - 75 MM DIA ASP
 - 4 - 50 MM DIA UP PIPE
 - 5 - 65/50 MM DIA DOWN PIPE
 - 6 - 150 MM DIA RAIN WATER PIPE


DOOR OPENING SCHEDULE					
S.NO	LABEL	SIZE(WXH)	LINTEL LVL	QUANTITY	REMARKS
1.	D1	2400 X 2100	2100	03	DOUBLE SHUTTER DOORS FOR OFFICE ENTRY.
2.	D2	1200 X 2100	2100	30	SINGLE SHUTTER DOORS FOR OFFICE ENTRY.
3.	D3	1200 X 2400	2400	04	SINGLE SHUTTER FIRE DOORS IN STAIRCASES & SERVICES
3.	D4	750 X 2100	2100	03	SINGLE SHUTTER DOORS IN TOILETS & PANTRY.
4.	GL1	1000 X 2400	2400	01	GLAZED LIFT LOBBY DOOR.

FIFTH FLOOR PLAN
F.F.L + 22750mm


FIFTH FLOOR AREA DETAILS						
XxY	X	Y			QTY.	
64.22	X	30.92				= 1985.68 SQ.M
DEDUCTIONS (D)						
3	19.15	X	30.92	X	0.50	= 296.06 SQ.M
4	REFER AS PER DRG					
5	8.56	X	13.81	X	0.50	= 59.11 SQ.M
6	8.56	X	8.49			= 72.67 SQ.M
7	8.56	X	5.30	X	0.50	= 22.68 SQ.M
8	REFER AS PER DRG					
9	24.29	X	1.58	X	0.50	= 19.19 SQ.M
10	REFER AS PER DRG					
11	7.16	X	5.33	X	0.50	= 19.08 SQ.M
12	REFER AS PER DRG					
13	4.10	X	19.56	X	0.50	= 40.10 SQ.M
14	REFER AS PER DRG					
						= 0.30 SQ.M
TOTAL						= 540.29 SQ.M
TOTAL DEDUCTION(D)						= XxY-D
	1985.68					= 1445.39 SQ.M
FIFTH FLOOR COVERED AREA						= 1445.39 SQ.M

SERVICES AREA ON FIFTH FLOOR						
Label	Length	Width	Area	Qty	Total Area	
A	5.00	X	4.16			= 20.80 SQ.M
B	7.03	X	4.40			= 30.93 SQ.M
C	3.00	X	8.79			= 26.37 SQ.M
D	6.36	X	4.54			= 28.87 SQ.M
E	2.30	X	0.90			= 2.07 SQ.M
F	2.40	X	0.60	X	2.00	= 2.88 SQ.M
G	1.20	X	0.60			= 0.72 SQ.M
H	1.23	X	0.60			= 0.74 SQ.M
I	2.54	X	0.83			= 2.11 SQ.M
J	1.20	X	1.16			= 1.39 SQ.M
K	1.20	X	0.60			= 0.72 SQ.M
1	2.35	X	2.30			= 5.41 SQ.M
2	2.40	X	2.50	X	6.00	= 36.00 SQ.M
FIFTH FLOOR SERVICES AREA						= 159.01 SQ.M

NET F.A.R. AREA= COVERED AREA - SERVICES AREA = 1445.39 - 159.01
NET F.A.R. AREA OF FIFTH FLOOR = 1286.38

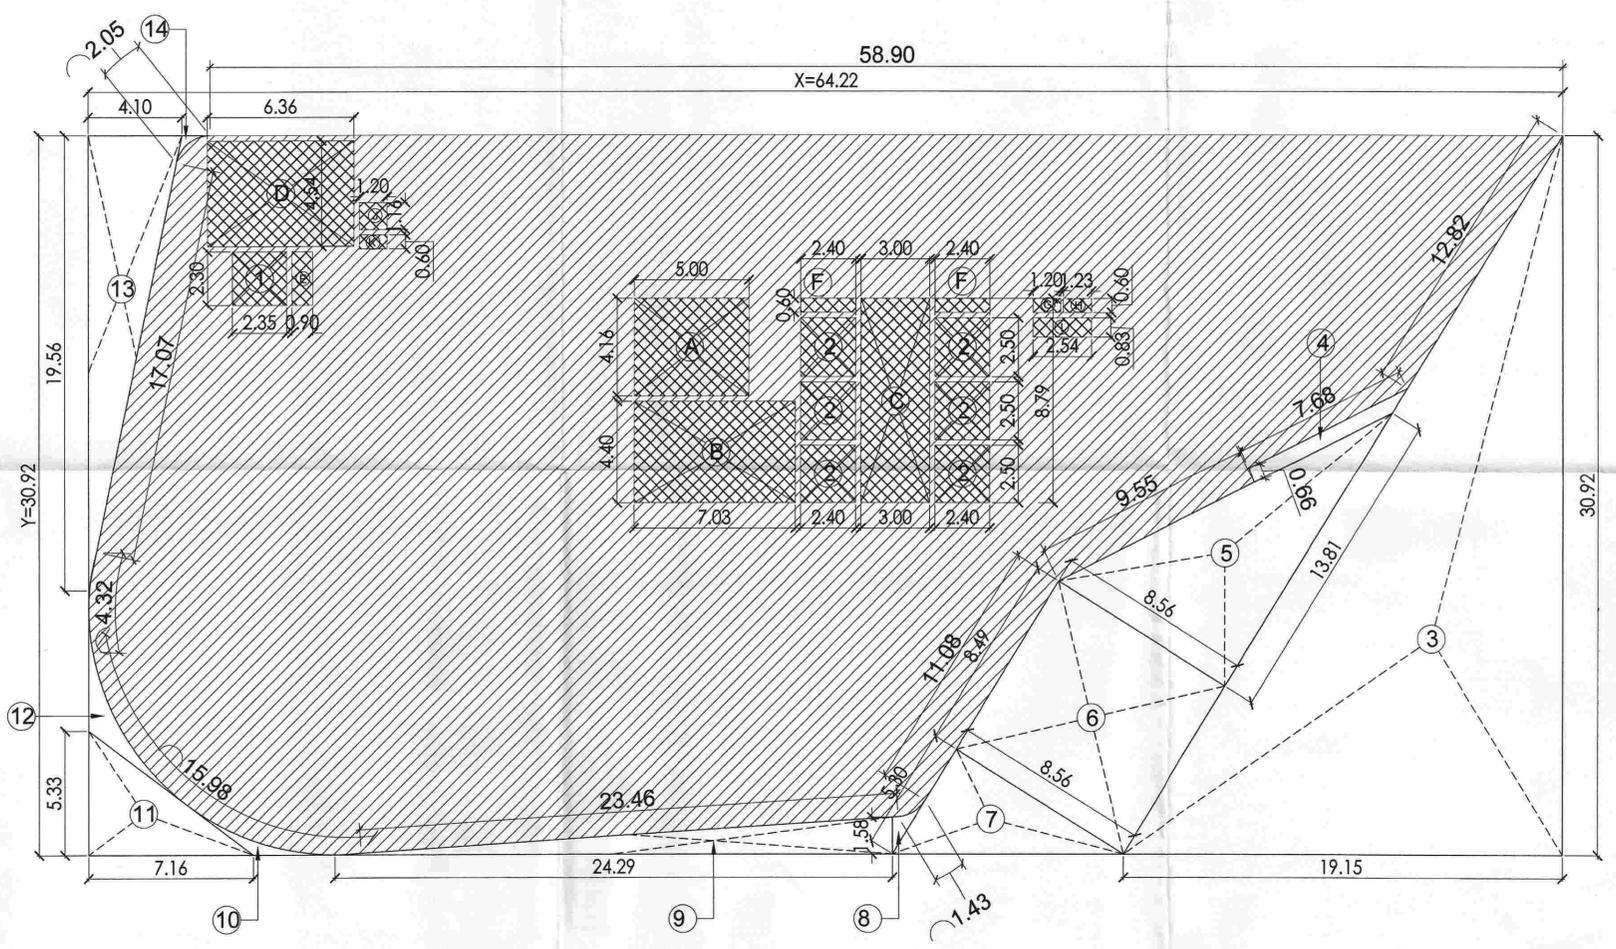

PROJECT
PROPOSED DEVELOPMENT FOR PLOT MEASURING 24.715 ACRES IN SECTOR-TECH.ZONE-4,PLOT NO.-17 GREATER NOIDA.
BEING DEVELOPED BY:
M/S S.P SAI IT PVT.LTD.
KEY PLAN

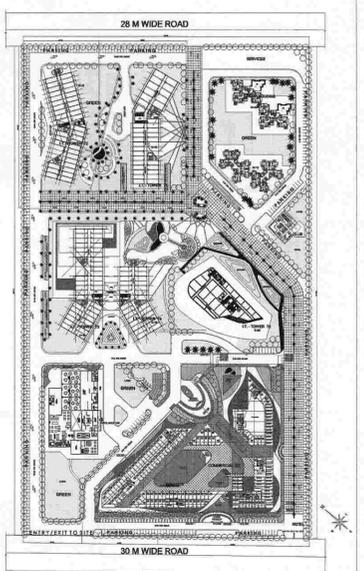

REVISION	SCALE	NORTH-
R3	1:150	

DRAWING NO.
1039/60/SUB/FLOOR PLAN-06

For S.P SAI IT PVT. LTD.
[Signature]
Authorised Signatory

OWNER'S SIGNATURE

[Signature]
REGISTERED ARCHITECT
ARCHITECT'S SIGNATURE

DRAWING
FIFTH FLOOR PLAN
IT TOWER - 5

DRAWN BY: ALANKRIT KUSHWAHA

