

- PLUMBING LEGENDS**
- 1 - 100 MM DIA SOIL WASTE PIPE
  - 2 - 100 MM DIA WASTE PIPE
  - 3 - 75 MM DIA ASP
  - 4 - 50 MM DIA UP PIPE
  - 5 - 65/50 MM DIA DOWN PIPE
  - 6 - 150 MM DIA RAIN WATER PIPE


DOOR OPENING SCHEDULE					
S.NO	LABEL	SIZE(WXH)	LINTEL LVL	QUANTITY	REMARKS
1.	D1	1200 X 2100	2100	02	DOUBLE SHUTTER DOORS FOR OFFICE ENTRY.
2.	D2	2400 X 2100	2100	30	SINGLE SHUTTER DOORS FOR OFFICE ENTRY.
3.	D3	1200 X 2400	2400	04	SINGLE SHUTTER FIRE DOORS IN STAIRCASES & SERVICES.
3.	D4	750 X 2100	2100	03	SINGLE SHUTTER DOORS IN TOILETS & PANTRY.
4.	GL1	1000 X 2400	2400	01	GLAZED LIFT LOBBY DOOR.

**NINTH FLOOR PLAN**  
 F.F.L +38750mm


NINTH FLOOR AREA DETAILS						
XxY	64.72	X	30.93			2001.79 SQ.M
<b>DEDUCTIONS (D)</b>						<b>QTY.</b>
3	19.15	X	30.93	X	0.5	= 296.15 SQ.M
4	9.04	X	14.59	X	0.5	= 65.95 SQ.M
5	9.04	X	6.97			= 63.01 SQ.M
6	9.04	X	5.60	X	0.5	= 25.31 SQ.M
7	REFER AS PER DRG					= 0.90 SQ.M
8	24.35	X	1.59	X	0.5	= 19.36 SQ.M
9	REFER AS PER DRG					= 1.59 SQ.M
10	6.80	X	5.58	X	0.5	= 18.97 SQ.M
11	REFER AS PER DRG					= 3.53 SQ.M
12	4.04	X	19.32	X	0.5	= 39.03 SQ.M
13	REFER AS PER DRG					= 0.30 SQ.M
<b>TOTAL</b>						<b>534.10 SQ.M</b>
<b>TOTAL DEDUCTION(D)</b>						<b>XxY-D</b>
						<b>2001.79</b>
<b>NINTH FLOOR COVERED AREA</b>						<b>= 1467.69 SQ.M</b>

SERVICES AREA ON NINTH FLOOR						
A	5.00	X	4.16			= 20.80 SQ.M
B	7.03	X	4.40			= 30.93 SQ.M
C	3.00	X	8.79			= 26.37 SQ.M
D	6.36	X	4.54			= 28.87 SQ.M
E	2.30	X	0.90			= 2.07 SQ.M
F	2.40	X	0.60	X	2.0	= 2.88 SQ.M
G	1.20	X	0.60			= 0.72 SQ.M
H	1.23	X	0.60			= 0.74 SQ.M
I	2.54	X	0.83			= 2.11 SQ.M
J	1.20	X	1.16			= 1.39 SQ.M
K	1.20	X	0.60			= 0.72 SQ.M
1	2.35	X	2.30			= 5.41 SQ.M
2	2.40	X	2.50	X	6	= 36.00 SQ.M
<b>NINTH FLOOR SERVICES AREA</b>						<b>= 159.01 SQ.M</b>

NET F.A.R. AREA = COVERED AREA - SERVICES AREA = 1467.69 - 159.01 = 1308.68

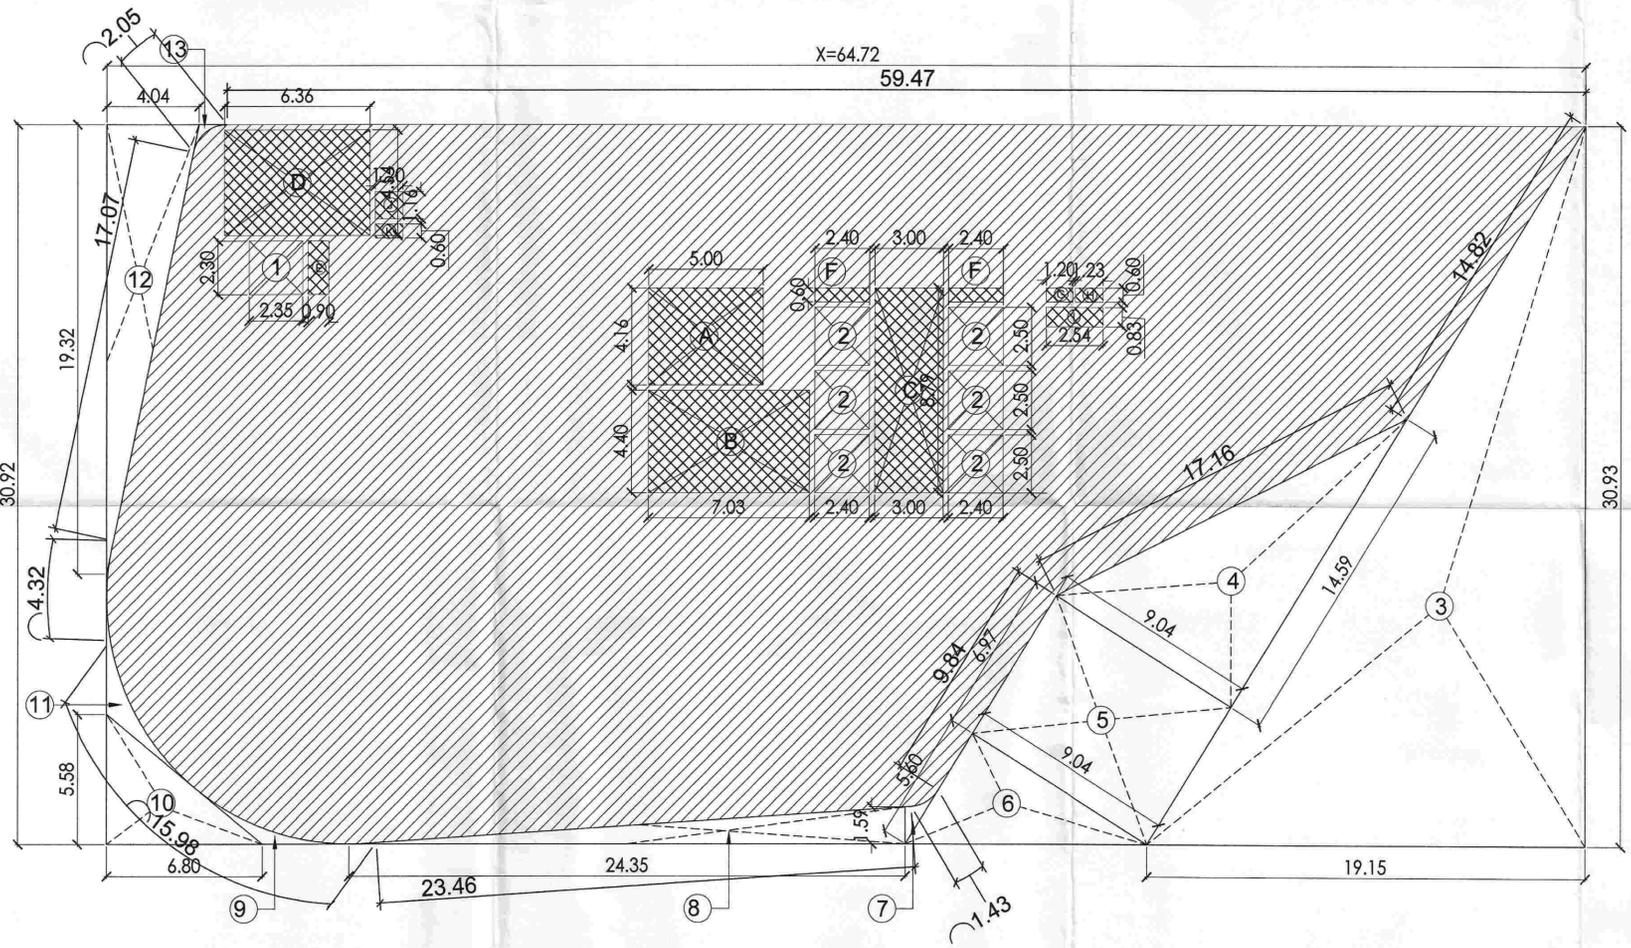

PROJECT  
**PROPOSED DEVELOPMENT FOR PLOT MEASURING 24.715 ACRES IN SECTOR-TECH.ZONE-4,PLOT NO.-17 GREATER NOIDA. BEING DEVELOPED BY: M/S S.P SAI IT PVT.LTD.**

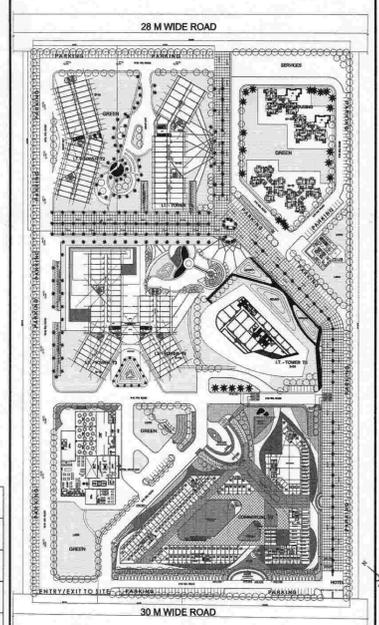

REVISION: **R3** SCALE: **1:150** NORTH: [Compass Rose]

DRAWING NO. **1039/60/SUB/FLOOR PLAN-10**

For SP SAI IT PVT. LTD.  
 [Signature]  
 Authorised Signatory  
 OWNER'S SIGNATURE

[Signature]  
 REGISTERED ARCHITECT  
 CA/87/10461  
 ARCHITECT'S SIGNATURE

**NINTH FLOOR PLAN**  
**IT TOWER-T5**

DRAWN BY: ALANKRIT KUSHWAHA

**ACPL** ISO 9001:2008  
 Architecture Management Planning

ACPL Design Ltd  
 J-103 South Extension-1  
 New Delhi-110049, India  
 T: +91 11 34622196  
 F: +91 11 34630609  
 E: contact@acpltd.com