

353.00


3.25 M. WD. ROAD WIDENING AREA

3.25 M. WD. ROAD WIDENING AREA

PARK-3  
8914.95 SQ. M.

3.50  
R/W/0000.00 lit-1

12.00 M. WIDE Access Road

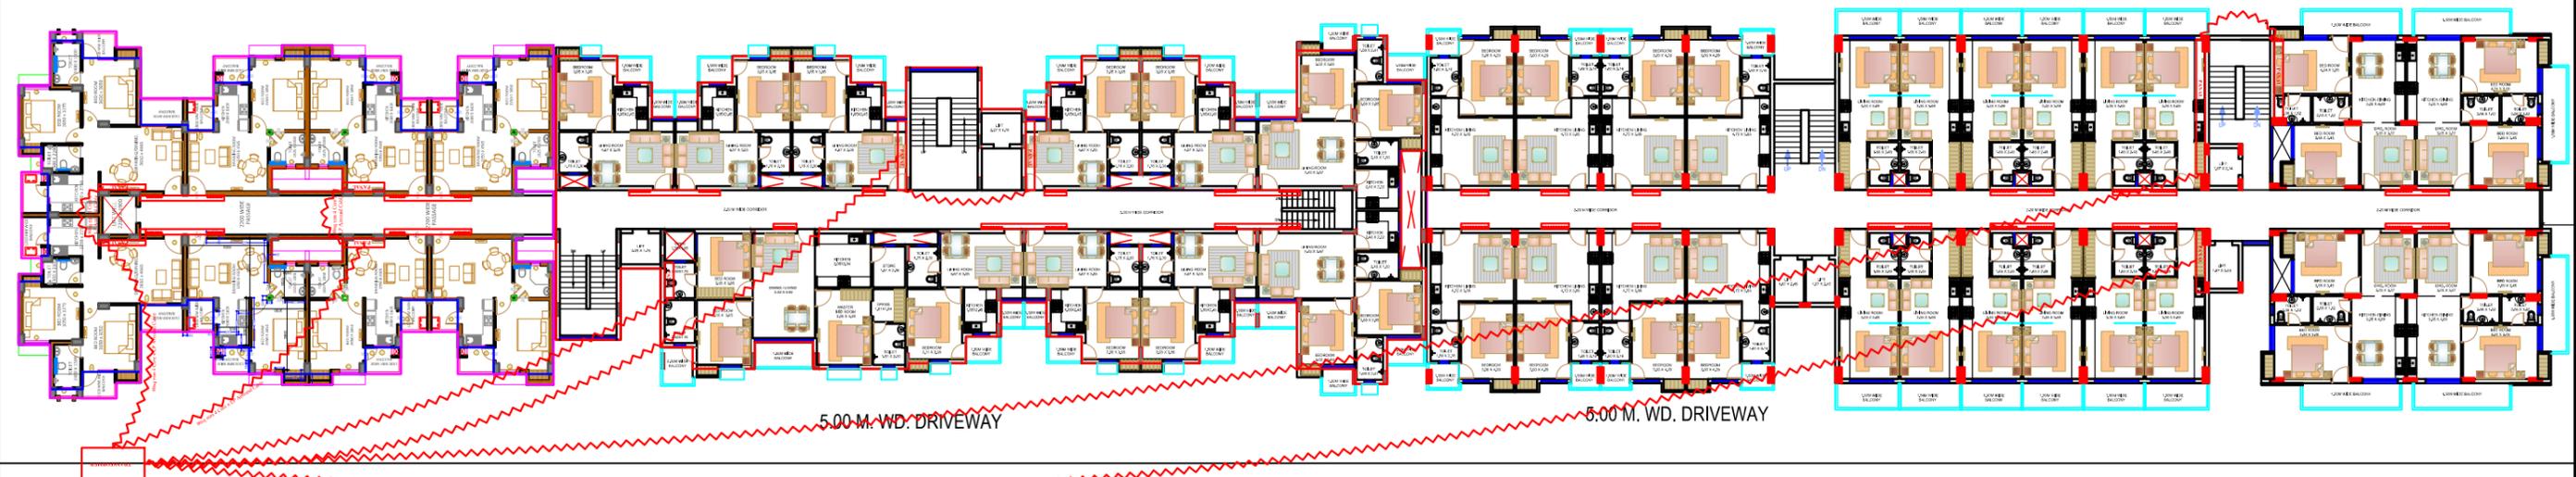

PARKING

188.89

POOL / PARK-4  
302.69 Sq. M.

# ELECTRICAL LAYOUT PLAN

**Project**

**Keshav Majestic**  
Vrindavan, Mathura

DRAWING TITLE : TYPICAL FLOOR PLAN

DRAWING TYPE:

DRAWING NO.: Mod/KM/SERVICES/R0

North

SCALE -

DATE - 20-Nov-23

Designed By: **N P Baghel**

Checked By: **Er. D S Sharma**

This drawing and/or its contents, information, and principles of design are the exclusive property of **Modcon Creative Sketcher Pvt. Ltd.**, Agra and is submitted to you with the agreement that it is not to be reproduced in any manner, copied, or modified, nor is it to be relayed in part or in whole to any other firm or individual for any other project except by written agreement with **Modcon Creative Sketcher Pvt. Ltd.** Agra

we are a creative architecture studio

modconagra@gmail.com  
modcon.in

**Modcon** A GROUP OF ARCHITECTS  
ENGINEERS & VALUERS

Corp. Office: 303, 3rd Floor, Maruti Tower, Sanjay Place, Agra. +91-9837522511  
Regd. Office: G-5 Kaveri Center, Sanjay Place, Agra. +91-562-2522511