


LEGEND FOR ELECTRICAL	
SERVICE CABLE FROM FEEDER PILLAR TO HOUSES	
LT CABLES FROM MAIN LT PANEL TO FEEDER PILLAR.	
COMPACT SUB-STATION.	
FEEDER PILLAR FOR MAINS SUPPLY.	
STREET LIGHT PANEL	
11KV RMU. COMPRISING OF 01 NO. INCOMER ISOLATOR AND 01 NO. OUTGOING ISOLATOR TO OTHER SUBSTATION AND ONE NO. OUTGOING VCB.	
33KV RMU. COMPRISING OF 01 NO. INCOMER ISOLATOR AND 01 NO. OUTGOING ISOLATOR TO OTHER SUBSTATION AND ONE NO. OUTGOING VCB.	
11KV VCB.	

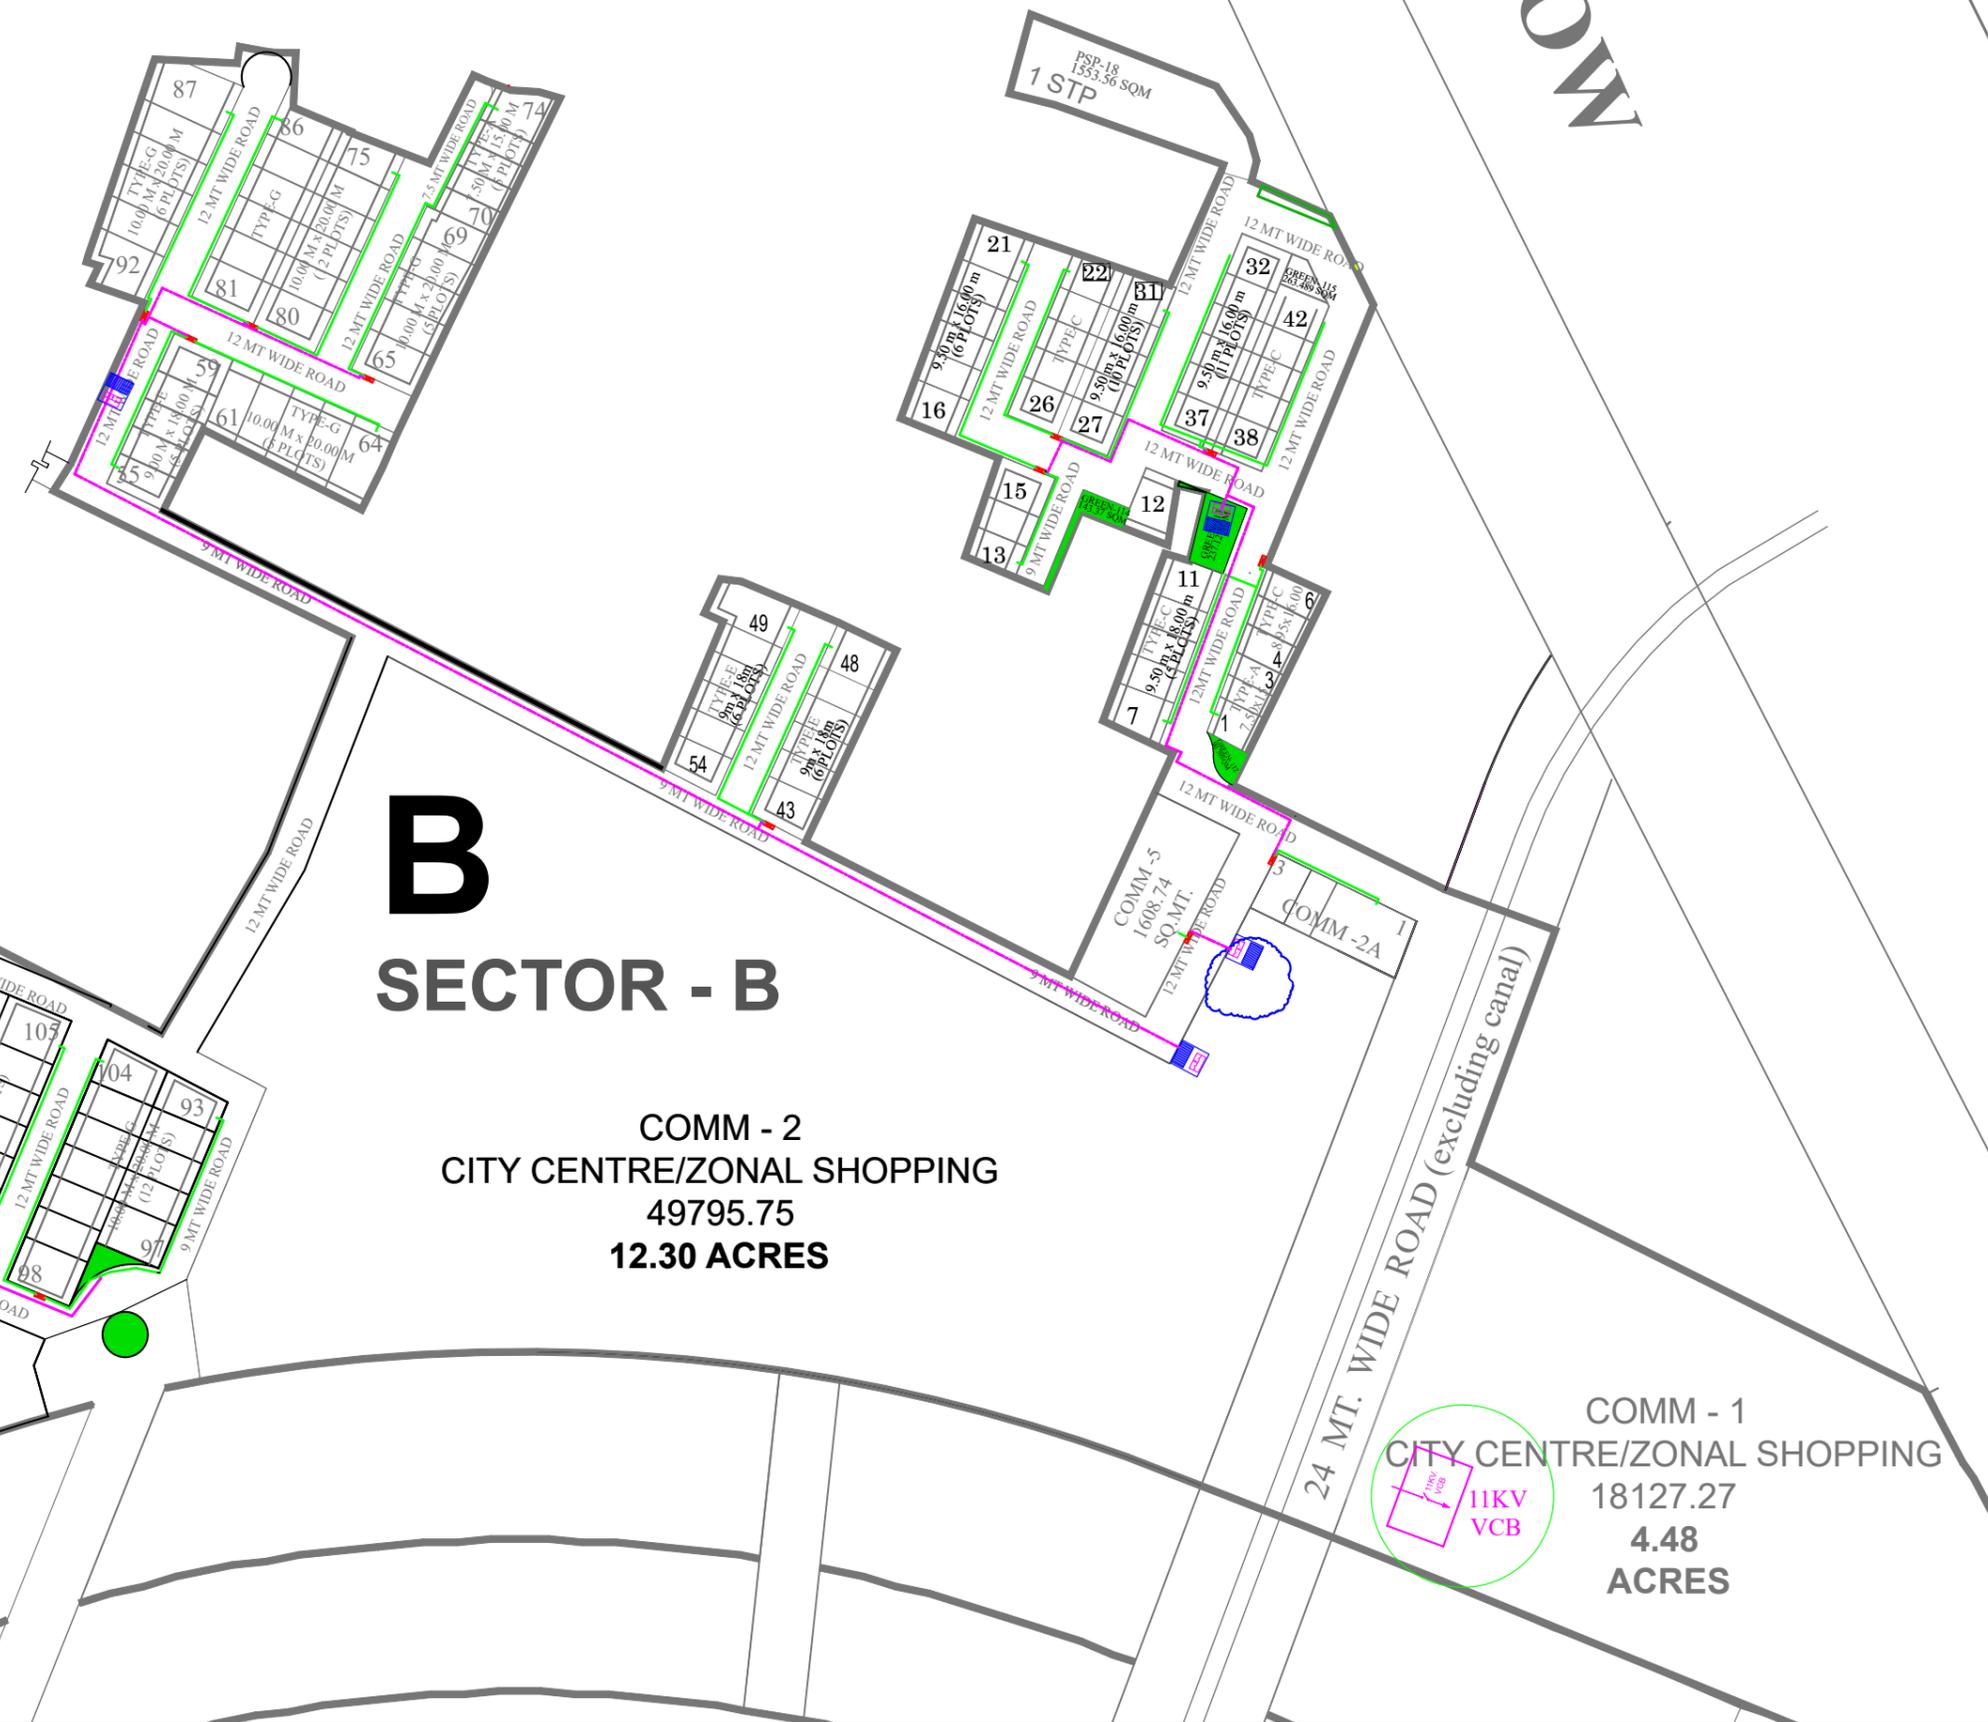

B

SECTOR - B

COMM - 2
CITY CENTRE/ZONAL SHOPPING
 49795.75
12.30 ACRES

COMM - 2B
 5407.95
1.34 ACRES

COMM - 1
CITY CENTRE/ZONAL SHOPPING
 18127.27
4.48 ACRES

NO	DATE	REVISIONS(DRAWING NO)	BY	CHKD	APPE
TOWN LUCKNOW					
TITLE ELECTRICAL LAYOUT					
DRAWING NO.			REV		
			0		
APPROVED	CHECKED	DESIGNED	DRAWN		
SCALE	DATE	STATUS			