

CLIENT

EXPERION DEVELOPERS PRIVATE LIMITED

8th Floor, Wing B, Milestone Experion Centre, Sector 15 Part 2,
Sector 15, Gurugram, Haryana 122001

KEY PLAN



NOTES:-

PROJECT

**EXPERION
RESIDENTIAL**
NOIDA, SECTOR 151

PRINCIPAL ARCHITECT :

DPA CONSULTANTS PVT LTD
MUMBAI
76, FREE PRESS HOUSE, 7TH FLOOR, 215
NARIMAN POINT, MUMBAI 400 021.
TEL: +91 22 6651 0838
FAX: +91 22 6651 0836

EXECUTIVE ARCHITECT :

ACPL ISO 9001:2008
Architecture
Management
Planning
ACPL Design Ltd E-24 South Extension Tr-1+91 11 24622195
New Delhi 110049, India +91 11 24644709
www.aponline.com E: contact@aponline.com IN 11 24634069

STRUCTURAL CONSULTANTS :

DR. KELKAR DESIGNS PRIVATE LIMITED
SHOP NO. 610, KESHAVA BUILDING, BANDRA KURLA COMPLEX RD,
NEAR FAMILY COURT, E BLOCK BKC, BANDRA KURLA COMPLEX,
BANDRA EAST, MUMBAI, MAHARASHTRA 400051
TEL: 022 26592278

MEP CONSULTANTS :

DESIGN CENTRE CONSULTING ENGINEERS PVT. LTD.
4TH FLOOR, ANSAL PLAZA, 4F, CS-44 - 47, MALL, SECTOR-1, VAISHALI,
GHAZIABAD, DELHI, UTTAR PRADESH PIN CODE - 201010

ARCHITECT'S SEAL & SIGNATURE

OWNER'S SEAL & SIGNATURE


[Signature]
KULMEET SHANGARI
ARCHITECT
CA/97/21741

[Signature]
Experion Developers Private Limited
Authorised Signatory

SCALE :- 1: 300

DRG. TITLE :

SEWAGE DRAINAGE LAYOUT
GROUND FLOOR PLAN DCCE/PL/01

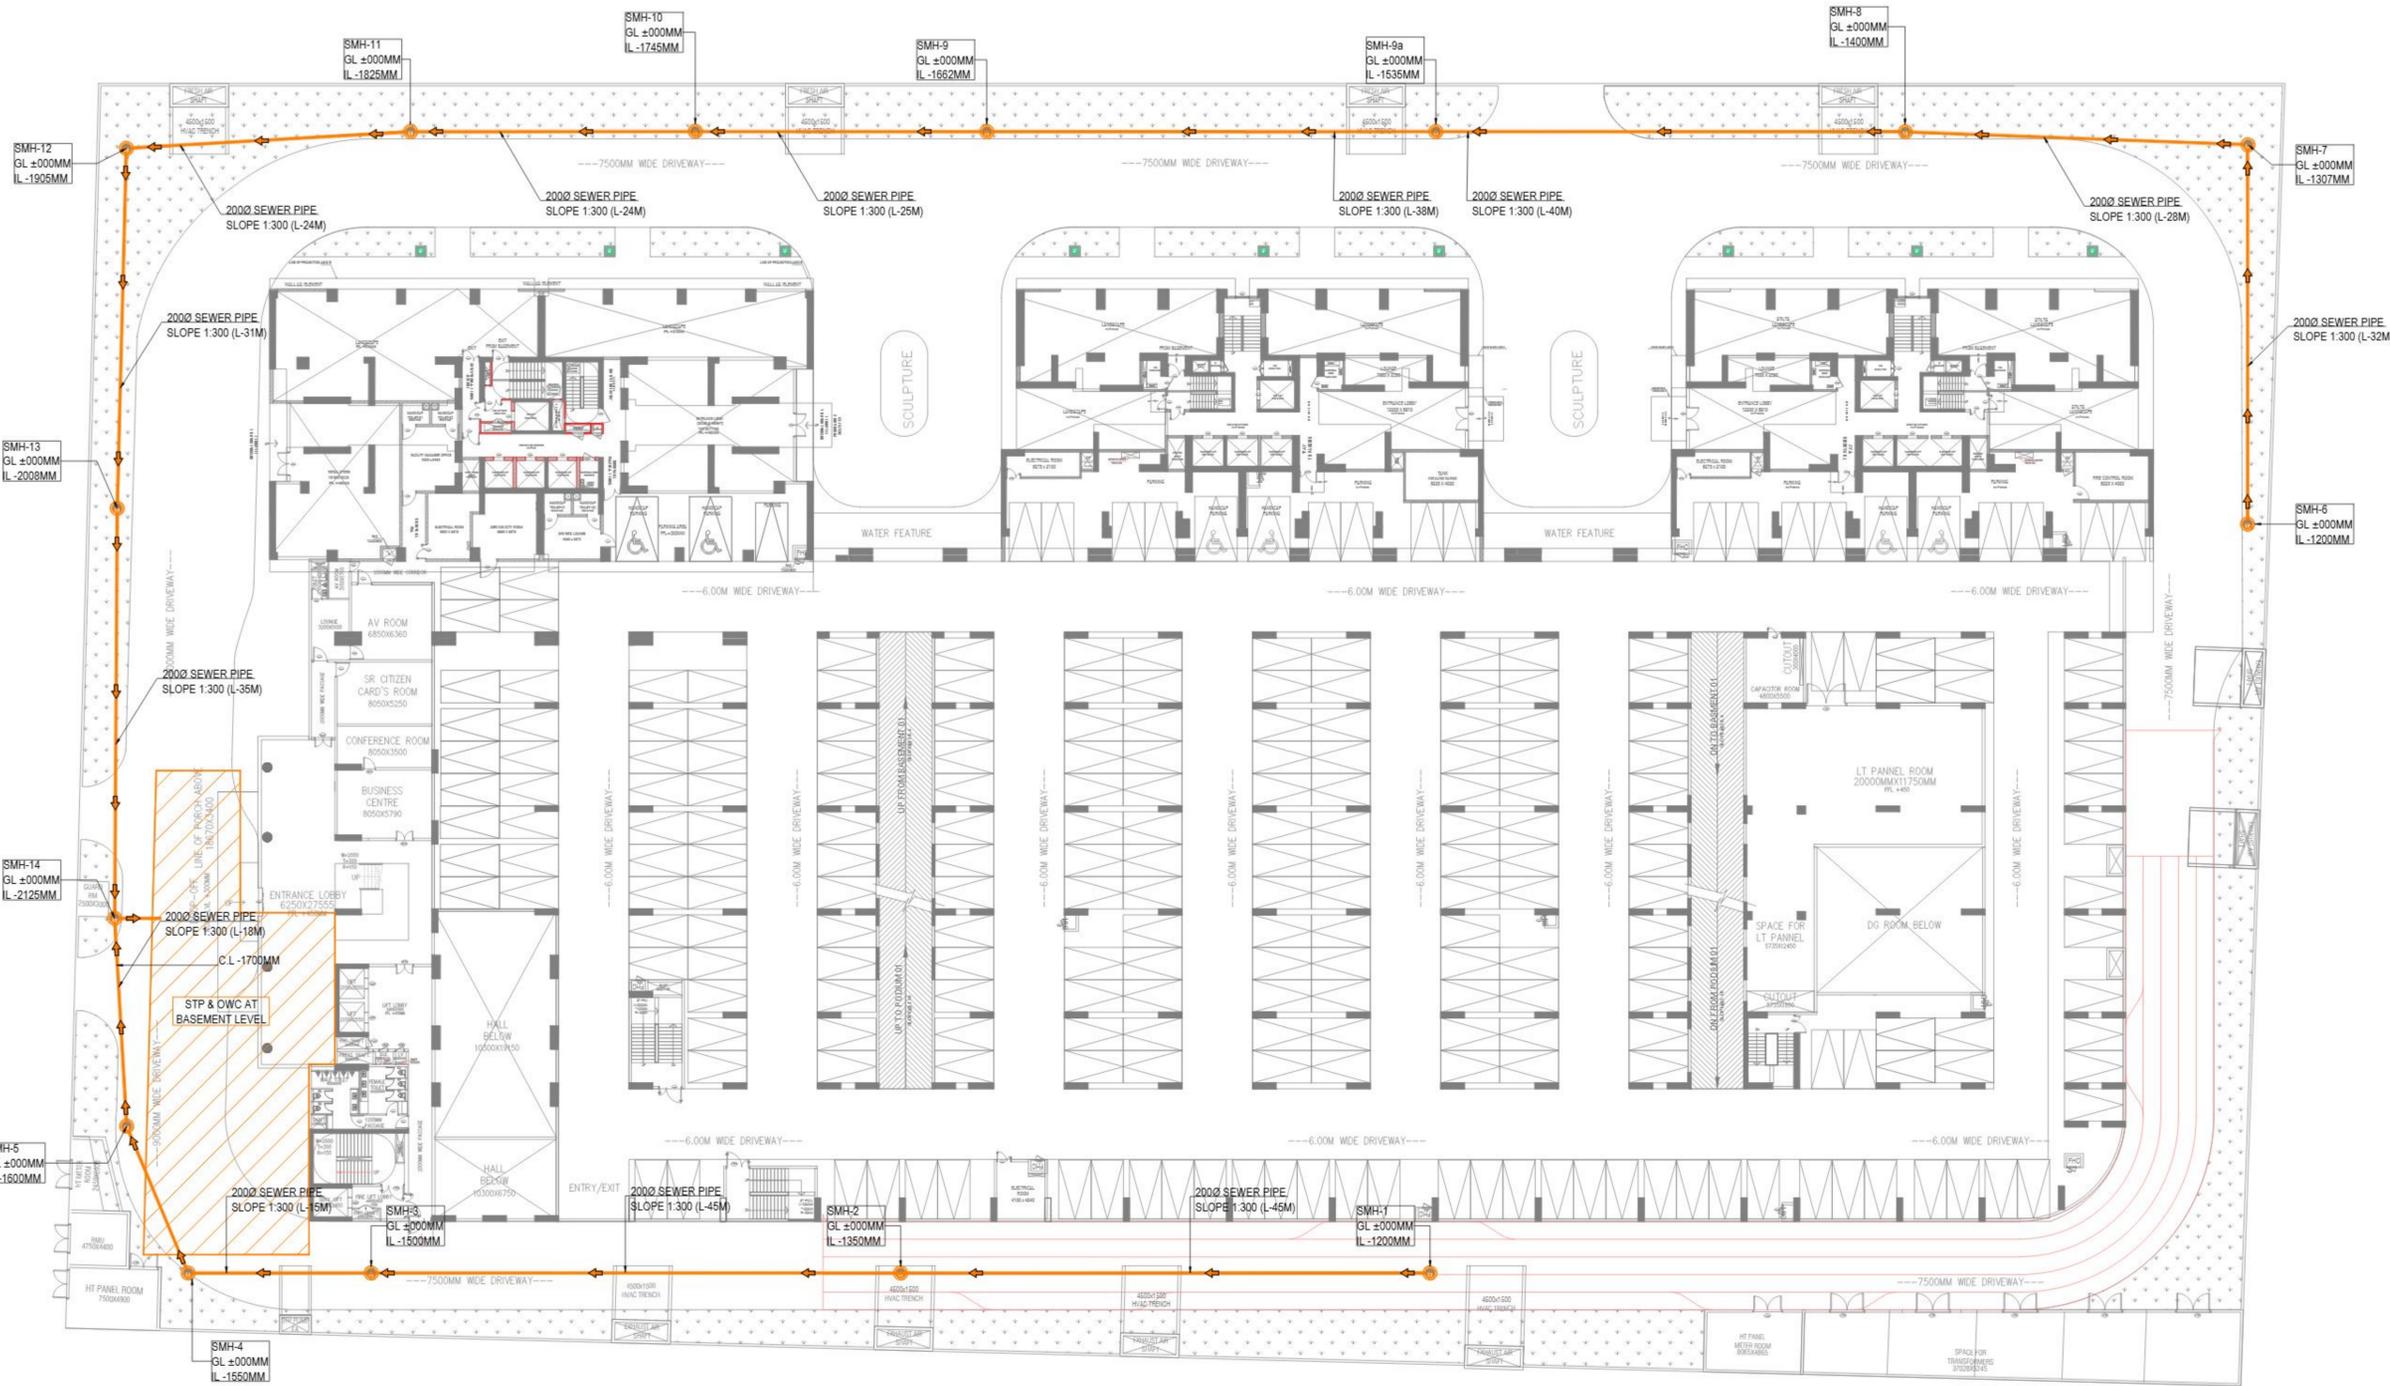

GROUND / PODIUM-1 / STILT-1 FLOOR PLAN

PLUMBING LEGEND: DRAINAGE

	SEWAGE MANHOLE
	STORM MANHOLE
	SEWAGE PIPE
	STORM PIPE

CLIENT

EXPERION DEVELOPERS PRIVATE LIMITED

8th Floor, Wing B, Milestone Experion Centre, Sector 15 Part 2,
Sector 15, Gurugram, Haryana 122001

KEY PLAN



NOTES:-

PROJECT

**EXPERION
RESIDENTIAL**
NOIDA, SECTOR 151

PRINCIPAL ARCHITECT :

DPA CONSULTANTS PVT LTD
MUMBAI
76, FREE PRESS HOUSE, 7TH FLOOR, 215
NARIMAN POINT, MUMBAI 400 021.
TEL: +91 22 6651 0838
FAX: +91 22 6651 0836

EXECUTIVE ARCHITECT :

ACPL ISO 9001:2008
Architecture
Management
Planning
ACPL Design Ltd E-24 South Extension Tr-1+91 11 24622195
New Delhi 110049, India +91 11 24644709
www.aponline.com E: contact@aponline.com IN 11 24634069

STRUCTURAL CONSULTANTS :

DR. KELKAR DESIGNS PRIVATE LIMITED
SHOP NO. 610, KESHAVA BUILDING, BANDRA KURLA COMPLEX RD,
NEAR FAMILY COURT, E BLOCK BKC, BANDRA KURLA COMPLEX,
BANDRA EAST, MUMBAI, MAHARASHTRA 400051
TEL: 022 26592278

MEP CONSULTANTS :

DESIGN CENTRE CONSULTING ENGINEERS PVT. LTD.
4TH FLOOR, ANSAL PLAZA, 4F, CS-44 - 47, MALL, SECTOR-1, VAISHALI,
GHAZIABAD, DELHI, UTTAR PRADESH PIN CODE - 201010

ARCHITECT'S SEAL & SIGNATURE

OWNER'S SEAL & SIGNATURE

Kulmeet Shargari
KULMEET SHARGARI
ARCHITECT
CA/97/21741

Experion Developers Private Limited
Authorised Signatory


SCALE :- 1: 300

NORTH

DRG. TITLE :

SEWAGE DRAINAGE LAYOUT
GROUND FLOOR PLAN

DCCE/PL/01

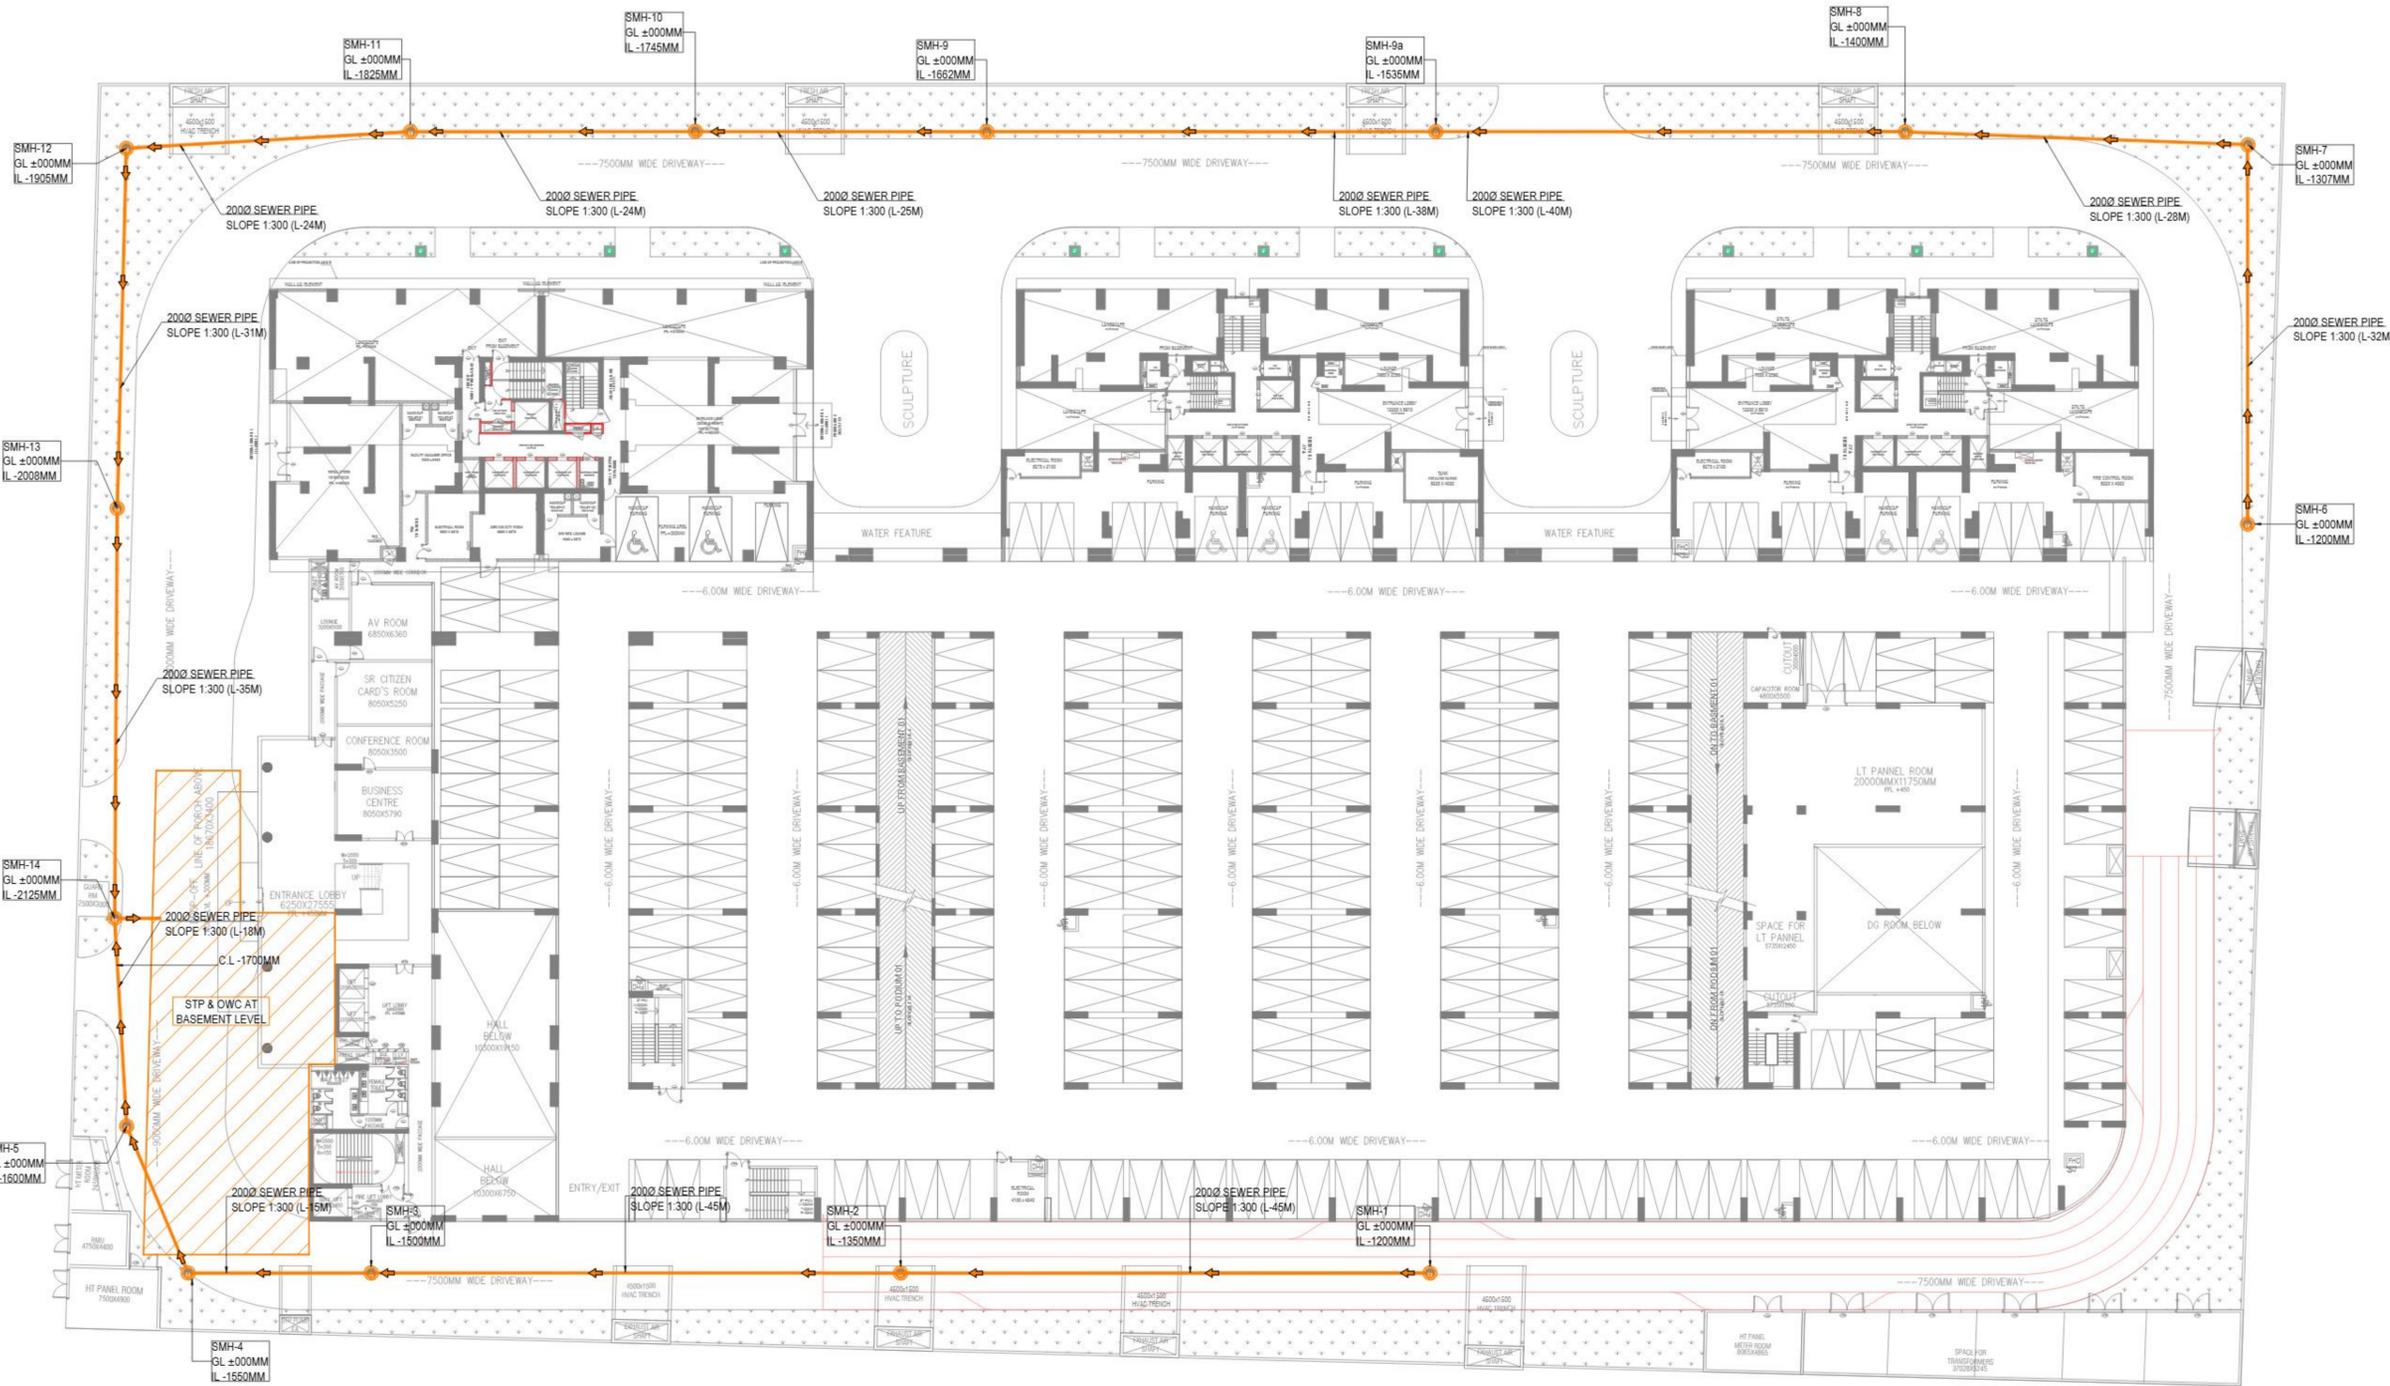

GROUND / PODIUM-1 / STILT-1 FLOOR PLAN

PLUMBING LEGEND: DRAINAGE

	SEWAGE MANHOLE
	STORM MANHOLE
	SEWAGE PIPE
	STORM PIPE

KEY PLAN



NOTES:-


PROJECT
EXPERION RESIDENTIAL
 NOIDA, SECTOR 151

PRINCIPAL ARCHITECT :
DPA CONSULTANTS PVT LTD
 MUMBAI
 76, FREE PRESS HOUSE, 7TH FLOOR, 215
 NARIMAN POINT, MUMBAI 400 021.
 TEL: +91 22 6651 0838
 FAX: +91 22 6651 0836


EXECUTIVE ARCHITECT :
ACPL ISO 9001:2008
 Architecture Management Planning
 ACPL Design Ltd E-24 South Extension 1-14-91 11 24622195
 New Delhi 110049, India +91 11 24646709
 C. contact@acplonline.com 11 24634069

STRUCTURAL CONSULTANTS :
DR. KELKAR DESIGNS PRIVATE LIMITED
 SHOP NO. 610, KESHAVA BUILDING, BANDRA KURLA COMPLEX RD,
 NEAR FAMILY COURT, E BLOCK BKG, BANDRA KURLA COMPLEX,
 BANDRA EAST, MUMBAI, MAHARASHTRA 400051
 TEL: 022 26592278

MEP CONSULTANTS :
DESIGN CENTRE CONSULTING ENGINEERS PVT. LTD.
 4TH FLOOR, ANSAL PLAZA, 4F, CS-44-47, MALL, SECTOR-1, VAISHALI,
 GHAZIABAD, DELHI, UTTAR PRADESH PIN CODE - 201010

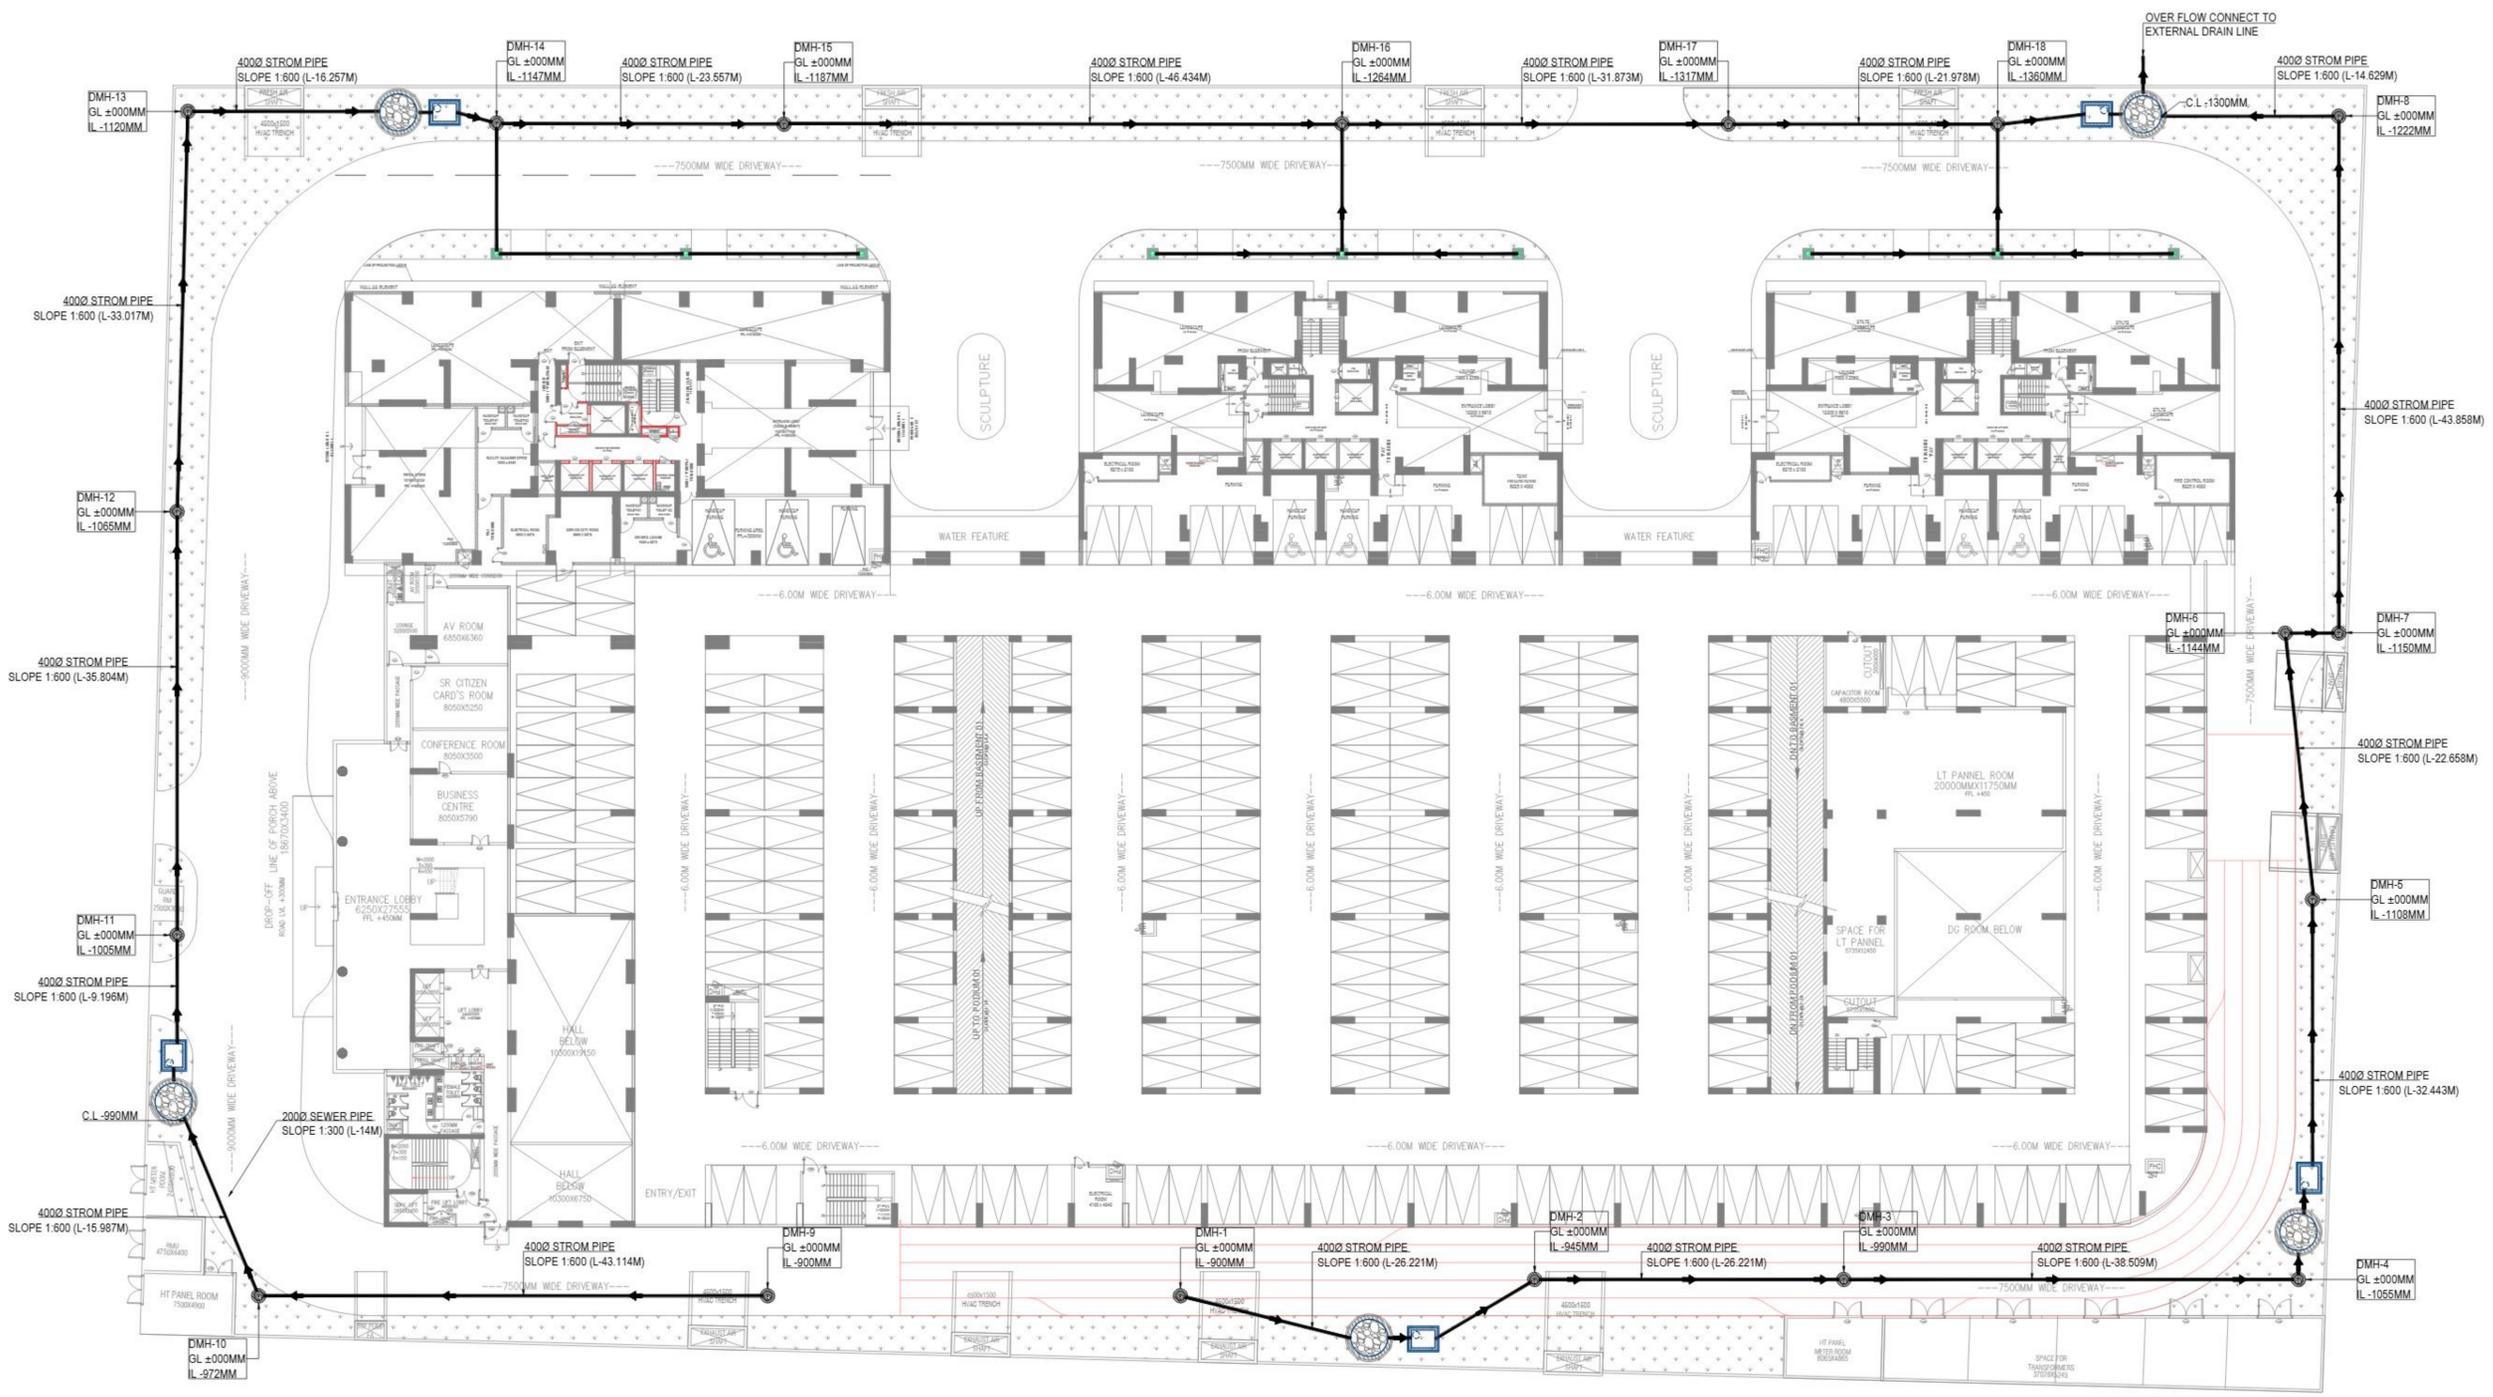

GROUND / PODIUM-1 / STILT-1 FLOOR PLAN

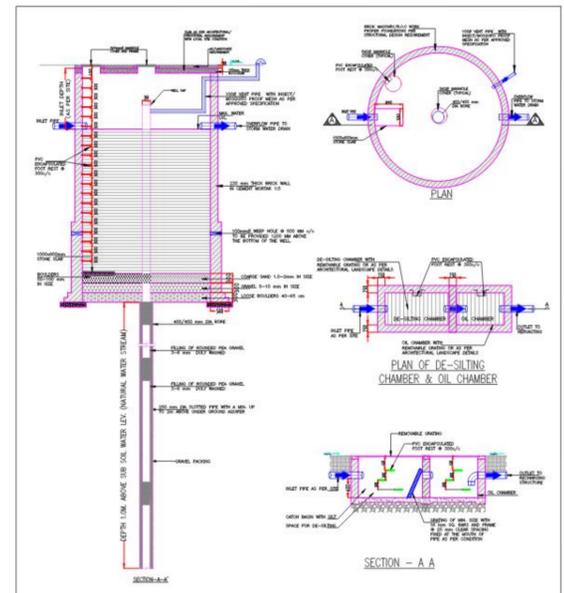

PLUMBING LEGEND: DRAINAGE

	SEWAGE MANHOLE
	STORM MANHOLE
	SEWAGE PIPE
	STORM PIPE

ARCHITECT'S SEAL & SIGNATURE OWNER'S SEAL & SIGNATURE

KULMEET SHANGARI
 ARCHITECT
 CA/97/21741

Authorised Signatory

SCALE :- 1: 300
 DRG. TITLE :
STORM DRAINAGE LAYOUT
 GROUND FLOOR PLAN

DCCE/PL/02

KEY PLAN



NOTES:-


PROJECT
EXPERION RESIDENTIAL
 NOIDA, SECTOR 151

PRINCIPAL ARCHITECT :
DPA CONSULTANTS PVT LTD
 MUMBAI
 76, FREE PRESS HOUSE, 7TH FLOOR, 215
 NARIMAN POINT, MUMBAI 400 021.
 TEL: +91 22 6651 0838
 FAX: +91 22 6651 0836


EXECUTIVE ARCHITECT :
ACPL ISO 9001:2008
 Architecture Management Planning
 ACPL Design Ltd E-24 South Extension 1-14-91 11 24622195
 New Delhi 110049, India +91 11 24646709
 C: contact@acplonline.com 91 11 24634069

STRUCTURAL CONSULTANTS :
DR. KELKAR DESIGNS PRIVATE LIMITED
 SHOP NO. 610, KESHAVA BUILDING, BANDRA KURLA COMPLEX RD,
 NEAR FAMILY COURT, E BLOCK BKG, BANDRA KURLA COMPLEX,
 BANDRA EAST, MUMBAI, MAHARASHTRA 400051
 TEL: 022 26592278

MEP CONSULTANTS :
DESIGN CENTRE CONSULTING ENGINEERS PVT. LTD.
 4TH FLOOR, ANSAL PLAZA, 4F, CS-44-47, MALL, SECTOR-1, VAISHALI,
 GHAZIABAD, DELHI, UTTAR PRADESH PIN CODE - 201010

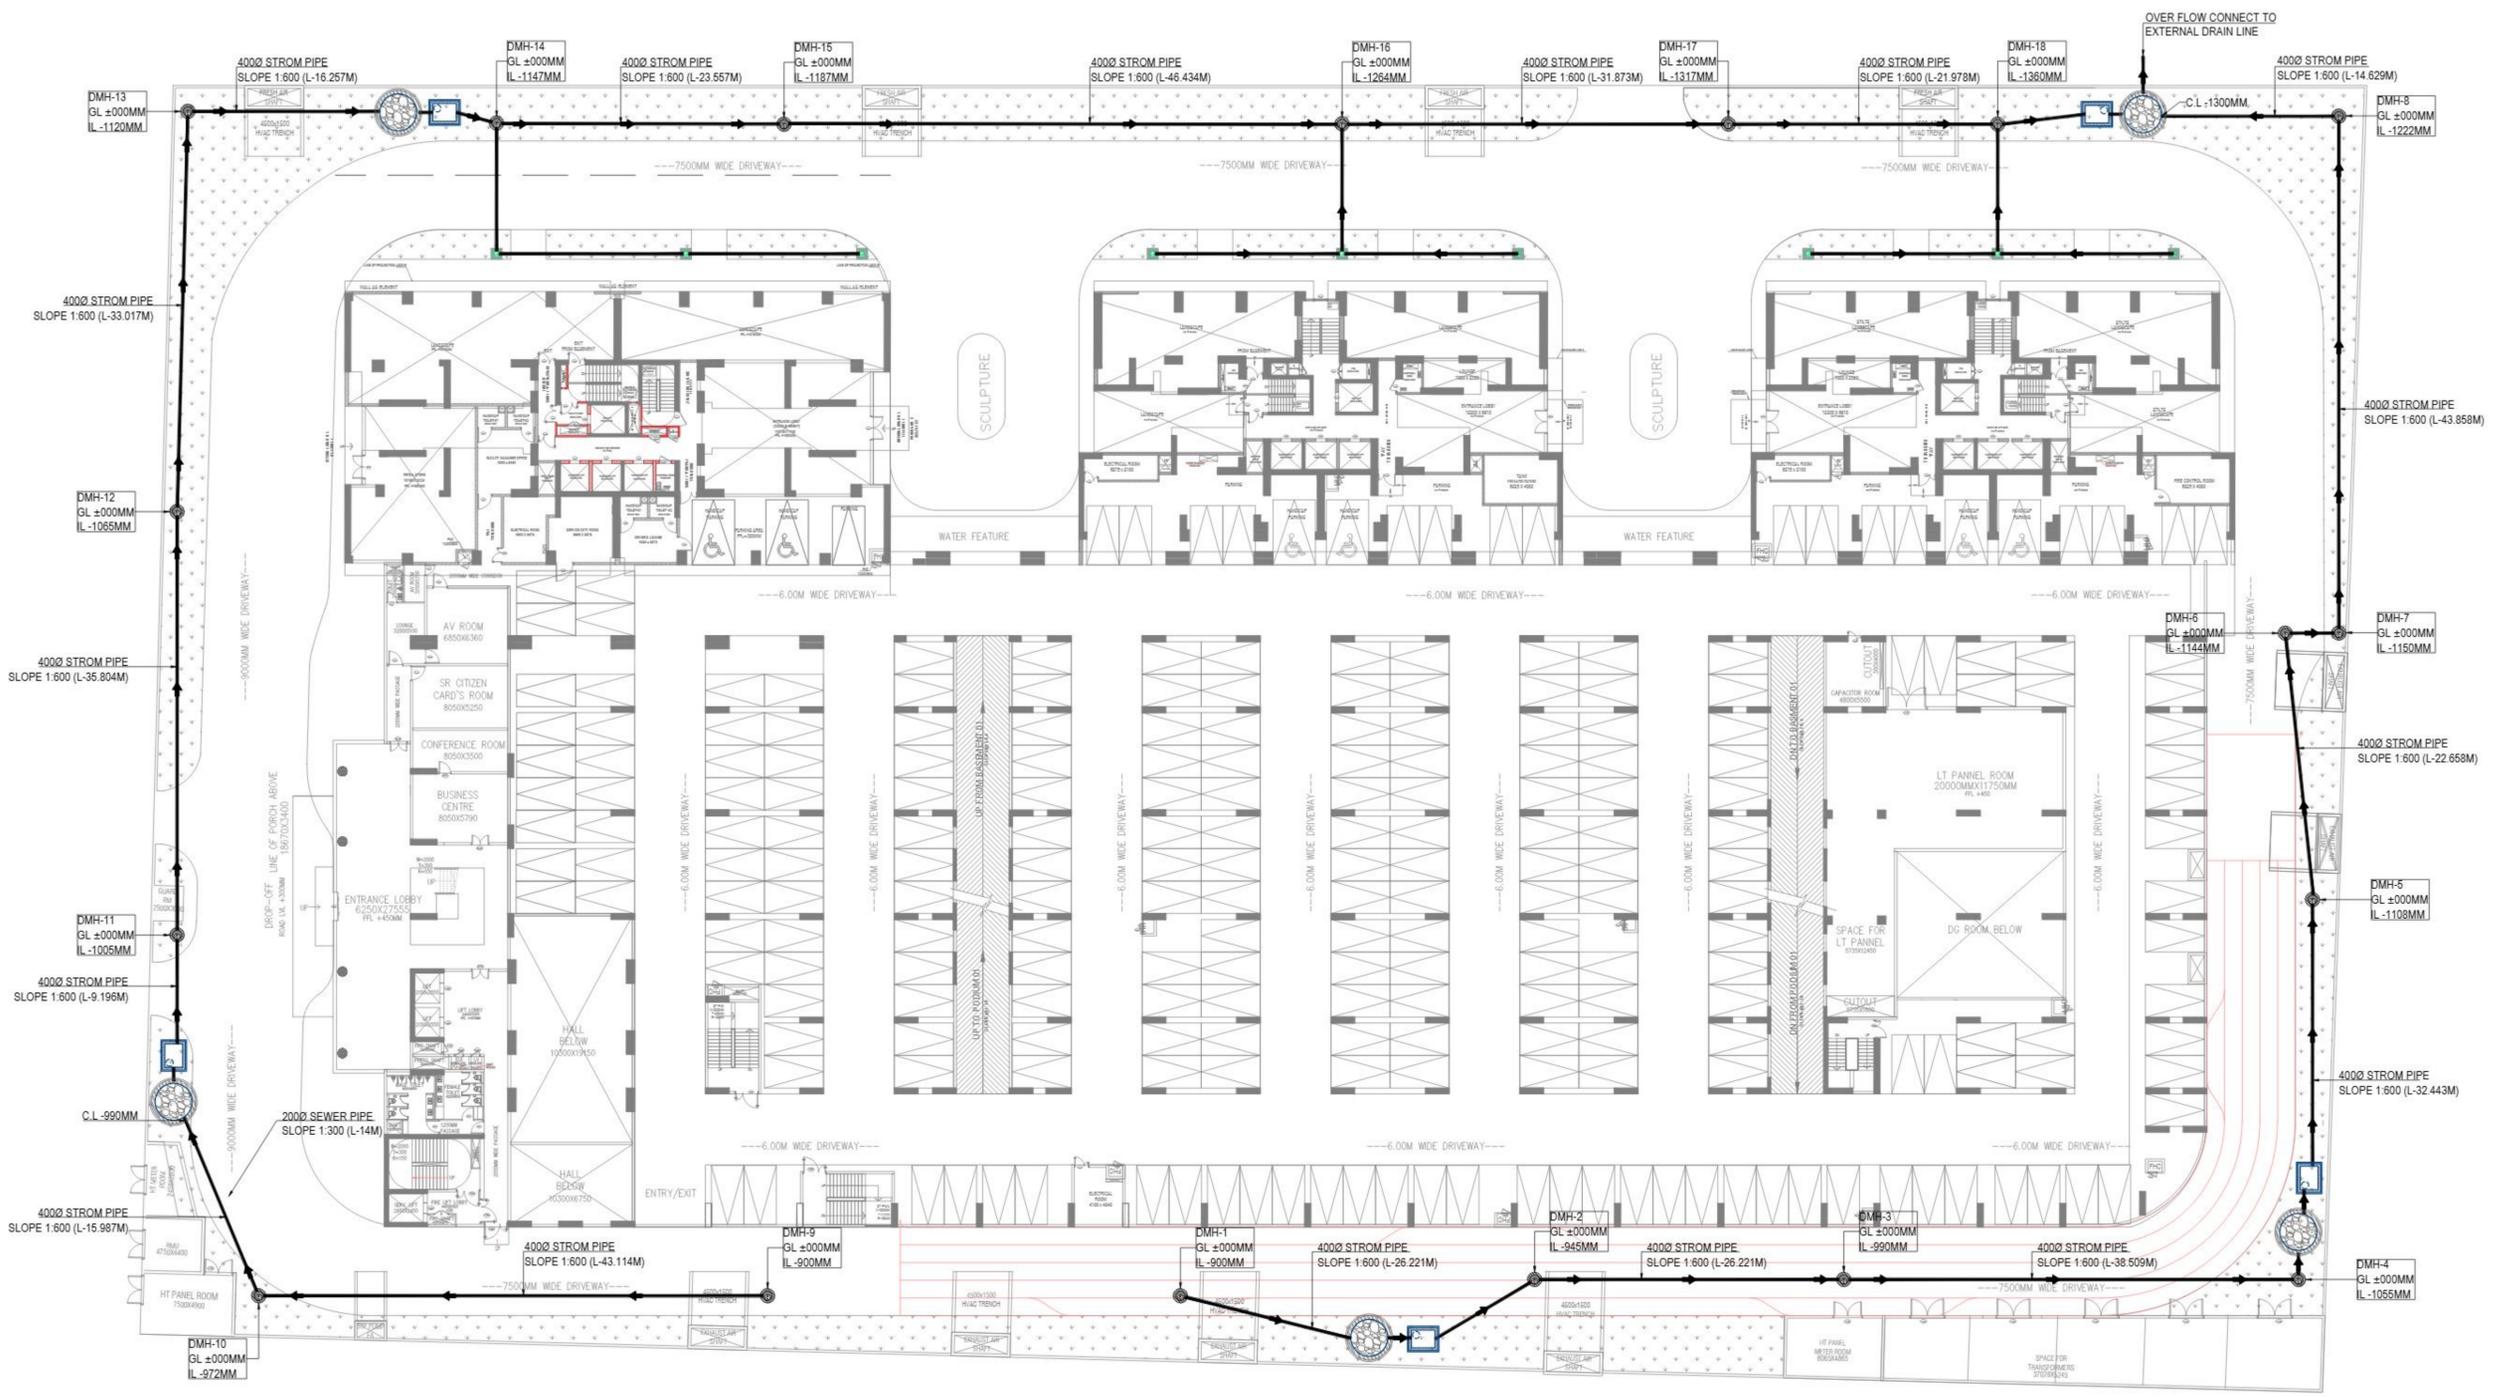

GROUND / PODIUM-1 / STILT-1 FLOOR PLAN

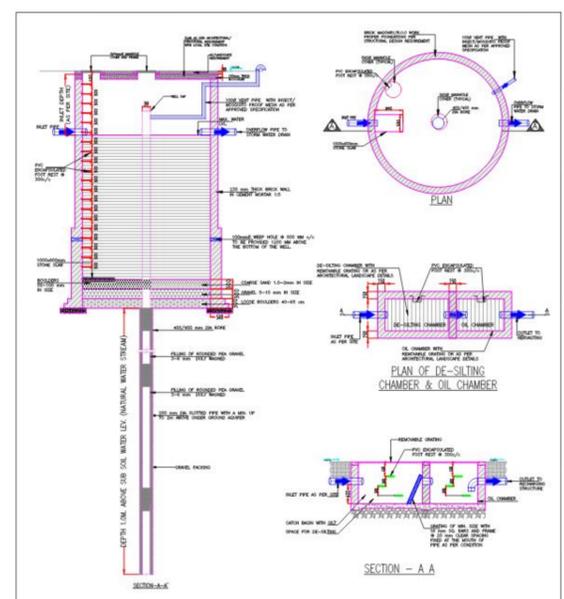

PLUMBING LEGEND: DRAINAGE

	SEWAGE MANHOLE
	STORM MANHOLE
	SEWAGE PIPE
	STORM PIPE

ARCHITECT'S SEAL & SIGNATURE OWNER'S SEAL & SIGNATURE

KULMEET SHANGARI
 ARCHITECT
 CA/97/21741

For Experion Developers Private Limited
 Authorised Signatory

SCALE :- 1: 300

DRG. TITLE : STORM DRAINAGE LAYOUT GROUND FLOOR PLAN

DCCE/PL/02