

PROPOSED EWS LIG FOR PINTAIL REALTY DEVELOPERS PVT LTD at PINTAIL REALTY DEVELOPERS PVT LTD, PARK CITY, INTEGRATED TOWNSHIP, BAKKAS, MOHANLAL GANJ, LUCKNOW

### WATER SUPPLY AND WASTE DISPOSAL SITE PLAN


DATE	SCALE	REVISION	SHEET NO.
05/09/22		R0	01
DRAWING NO.		SHEET SIZE	
		A1	

#### NOTE

- 1) ALL DIMENSIONS ARE IN MILLIMETERS
- 2) NO DIMENSION TO BE SCALED FROM THE DRAWINGS WRITTEN DIMENSIONS TO BE FOLLOWED
- 3) IN CASE OF DISCREPANCY LARGE SCALE DETAILED DRAWINGS SHALL SUPERSEDE SMALLER SCALE DRAWINGS AND DISCREPANCIES IN THE DRAWINGS ARE TO BE BROUGHT OUT TO THE NOTICE OF THE ARCHITECT. IT IS GOT TO BE RECTIFIED BEFORE TENDERING.
- 4) ALL SERVICES OWNS TO BE REFERRED ONLY FOR THE TECHNICAL CONTENTS OF THE PROJECT WORKING DRAWINGS TO BE FOLLOWED FOR ALL WORK AT SITE.
- 5) ALL STRUCTURAL SIZES AND STRUCTURAL DETAILS TO BE REFERRED FROM DRAWINGS OF STRUCTURAL CONSULTANTS.

#### LEGEND:- (Plumbing)

S.NO.	SYMBOL	DESCRIPTION
1.		ELECTRIC SUBSTATION
2.		ELECTRIC POLE

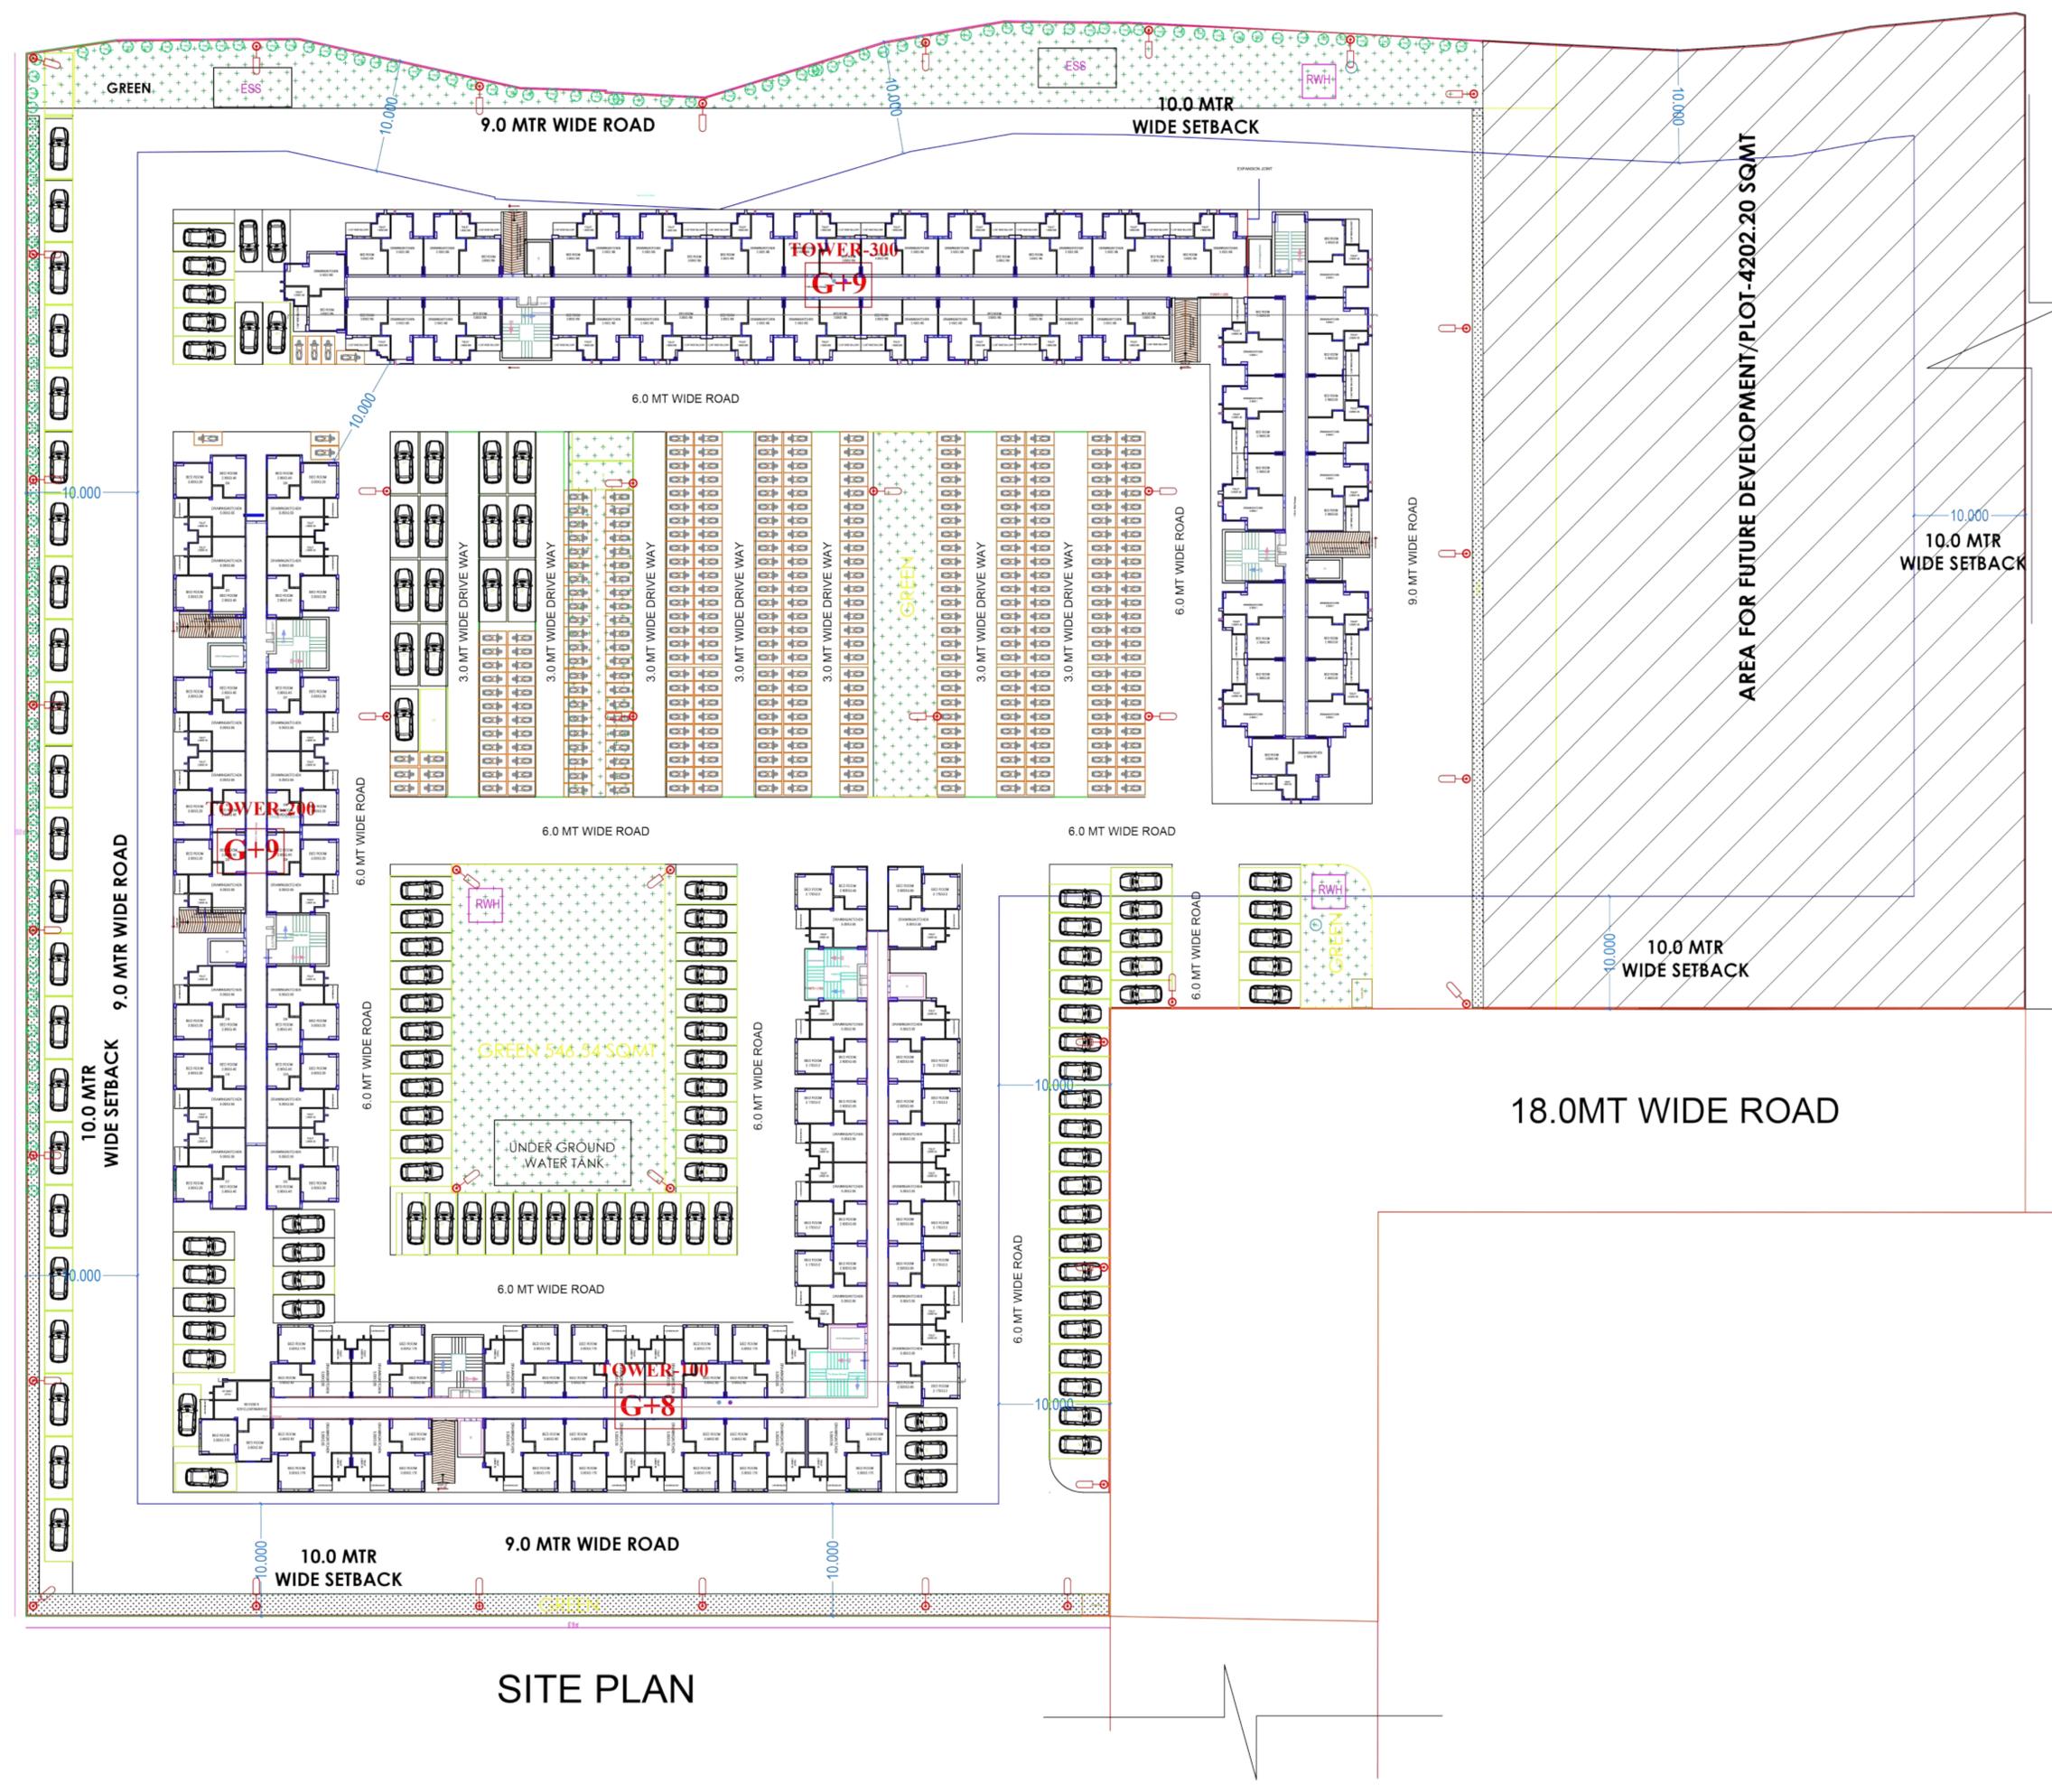

## SITE PLAN

**architect's avenue**  
 D-2/122, Sambhav Tower, Vibhuti  
 Khand Gombi Nagar, Lucknow, U.P.

ARCHITECT



OWNER