


UNDERGROUND
WATER TANK

PLUMBING LEGEND- EXTERNAL	
SEWER MANHOLE	
STORM MANHOLE	
CATCH BASIN SIZE 450X500 MM	
SEWER LINE	
STORM LINE	
IRREGION LINE	
VALVE WITH CHAMBER 500X500MM	
HARVESTING PIT- 4M DIA., 2M W.D	
DESELTING CHAMBER- 1.5 X1 M	
NON RETURN VALVE	
VALVE	
GARDEN HYDRANT.	

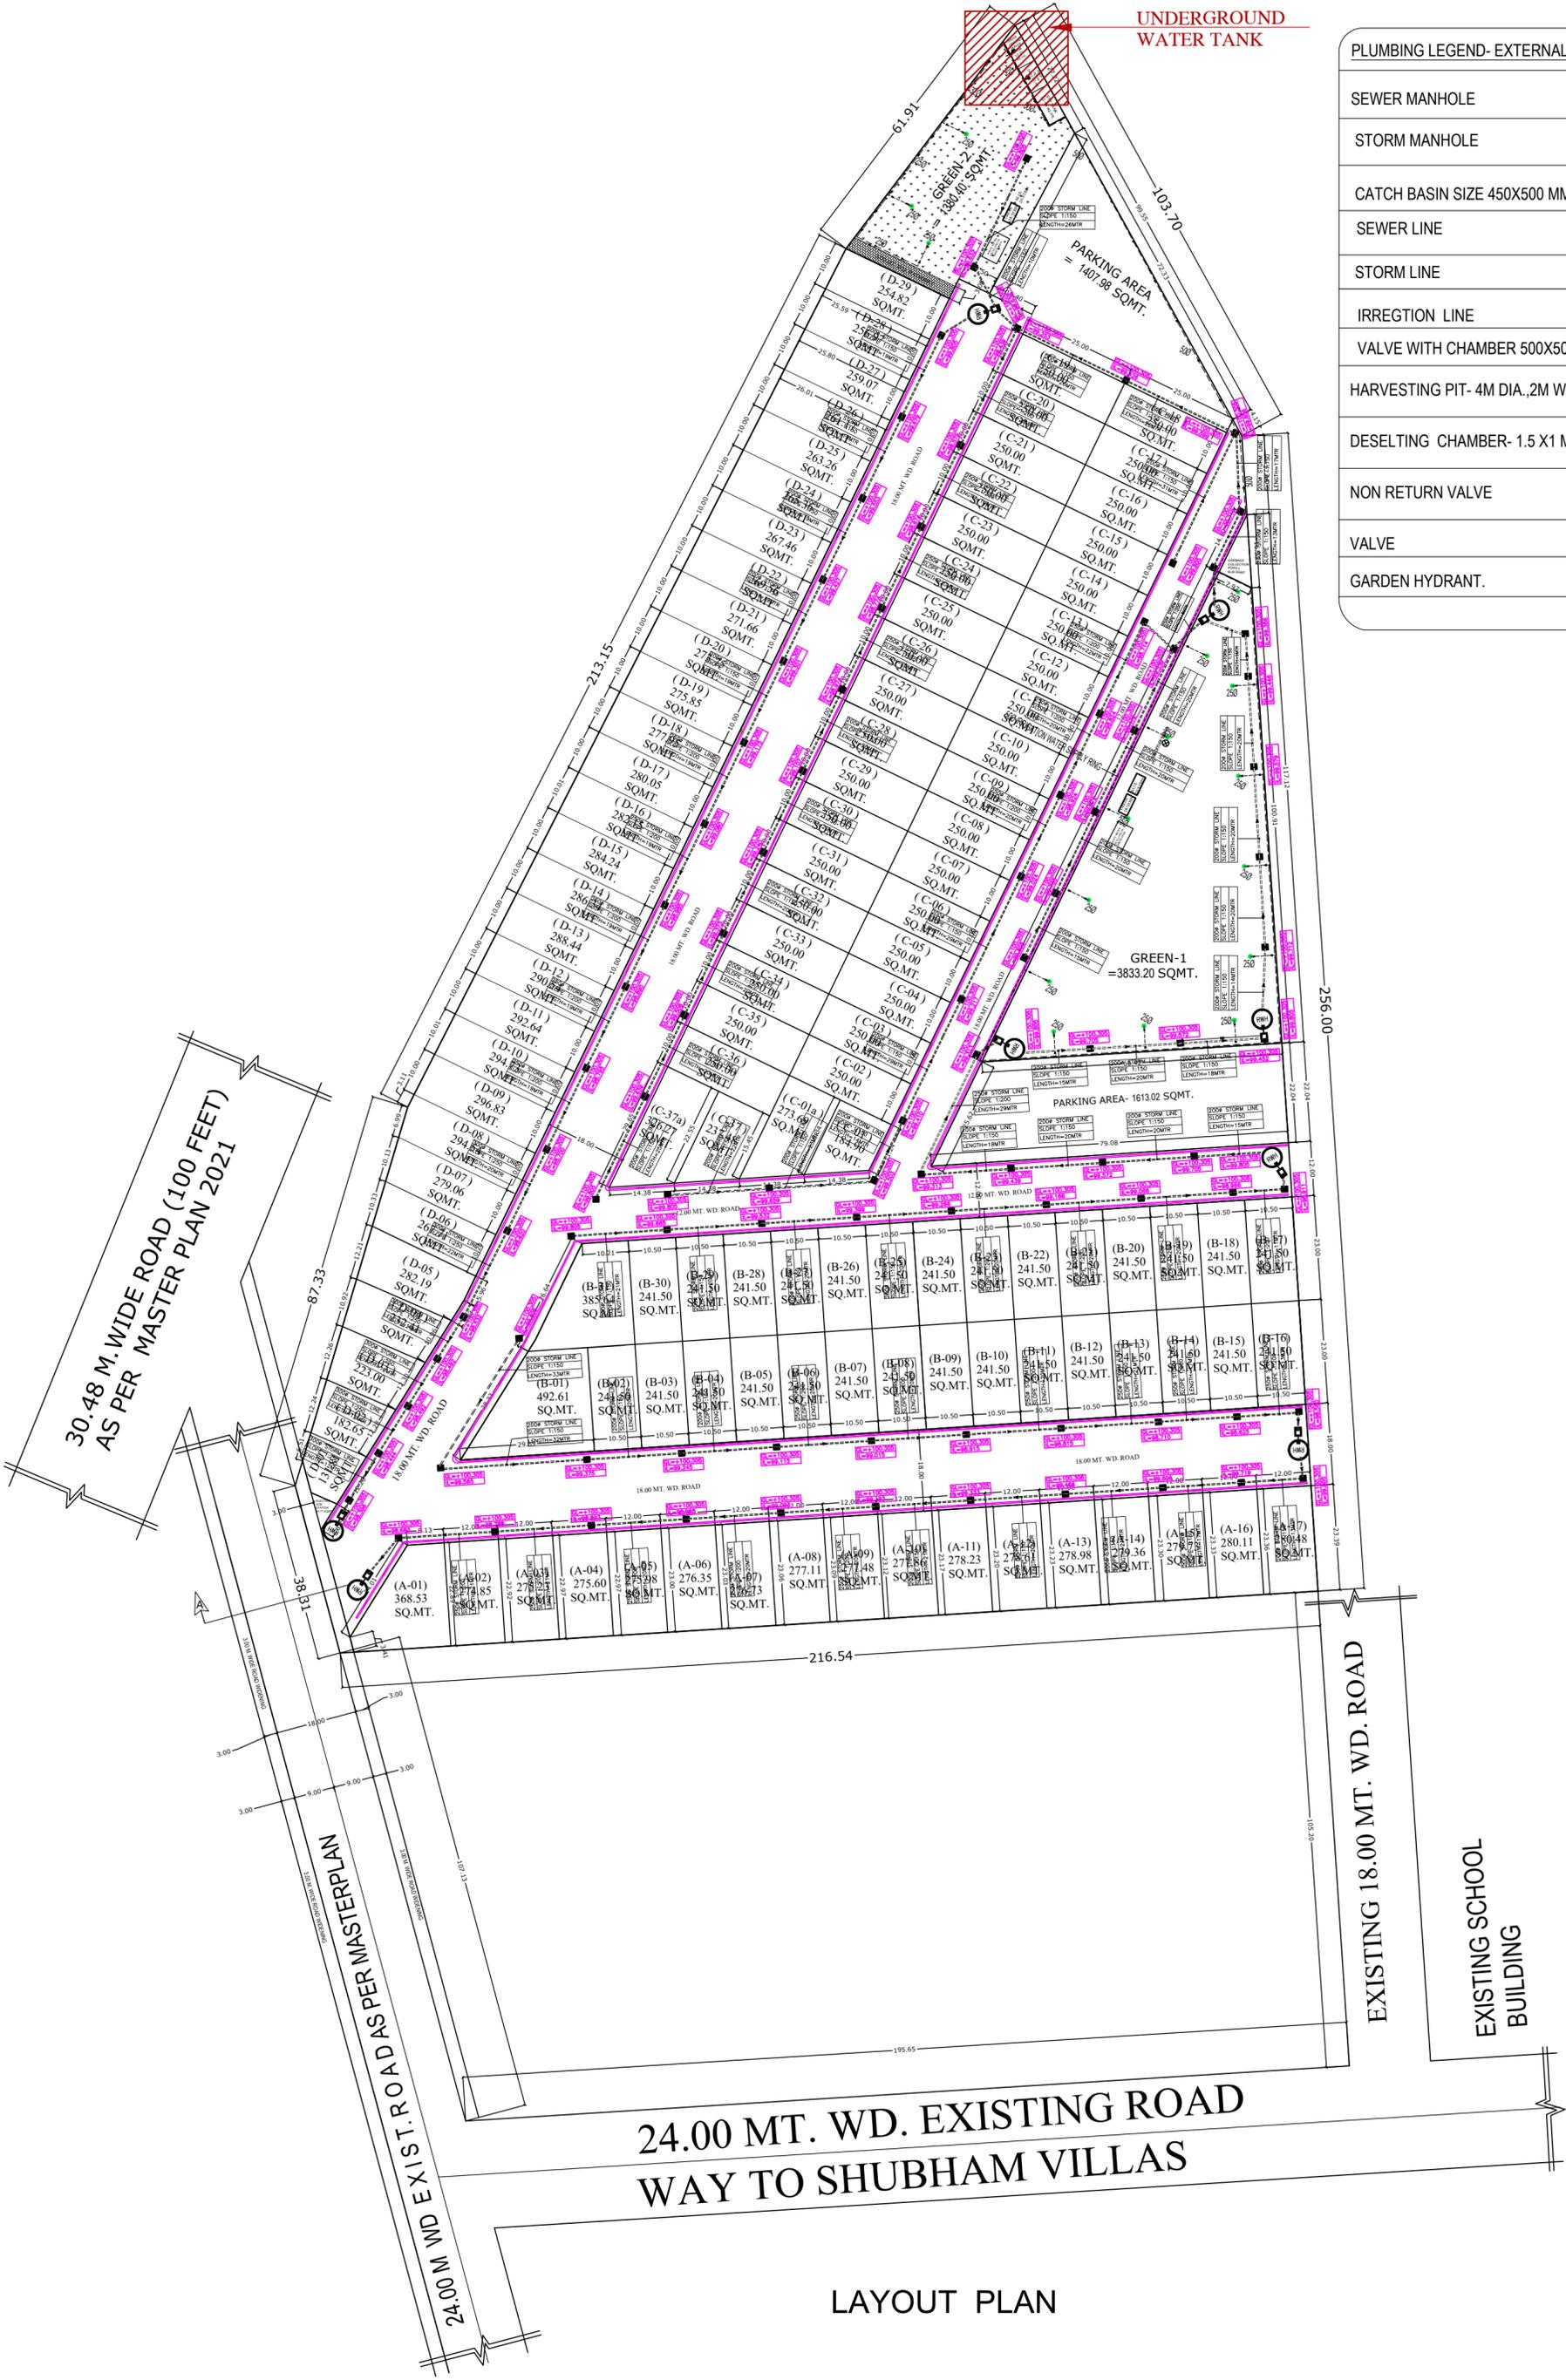

24.00 MT. WD. EXISTING ROAD
WAY TO SHUBHAM VILLAS

LAYOUT PLAN

CLIENT:	ANANDAM HIGHSTREET	PROJECT:	AT MORADABAD	DATE OF ISSUE:	28-08-23	DEALT BY:	AMIT	ARCHITECT:	VINAYAK GUPTA B.ARCH.,MARCH(LONDON)
SHEET TITLE:	STORM LINE PLAN								

PANDIT SHANKAR DUTT SHARMA MARG, OPP. CIVIL LINES POLICE STATION, MORADABAD
MOB. +91 959438890 E-MAIL: arpa@outlook.com, vinayak_gupta2002@yahoo.com