



PROJECT:
 ELDECO 7 PEAKS RESIDENCES AT
 PLOT NO. GH-1 RAGHOLA BLOCK -A,
 SECTOR -14, GATEWAY INDIA,
 GREATER Noida

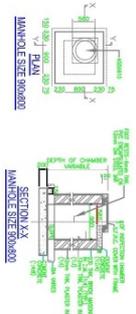

LEGEND FOR PLUMBING	
	SEWERAGE MANHOLE
	SEWERAGE LINE

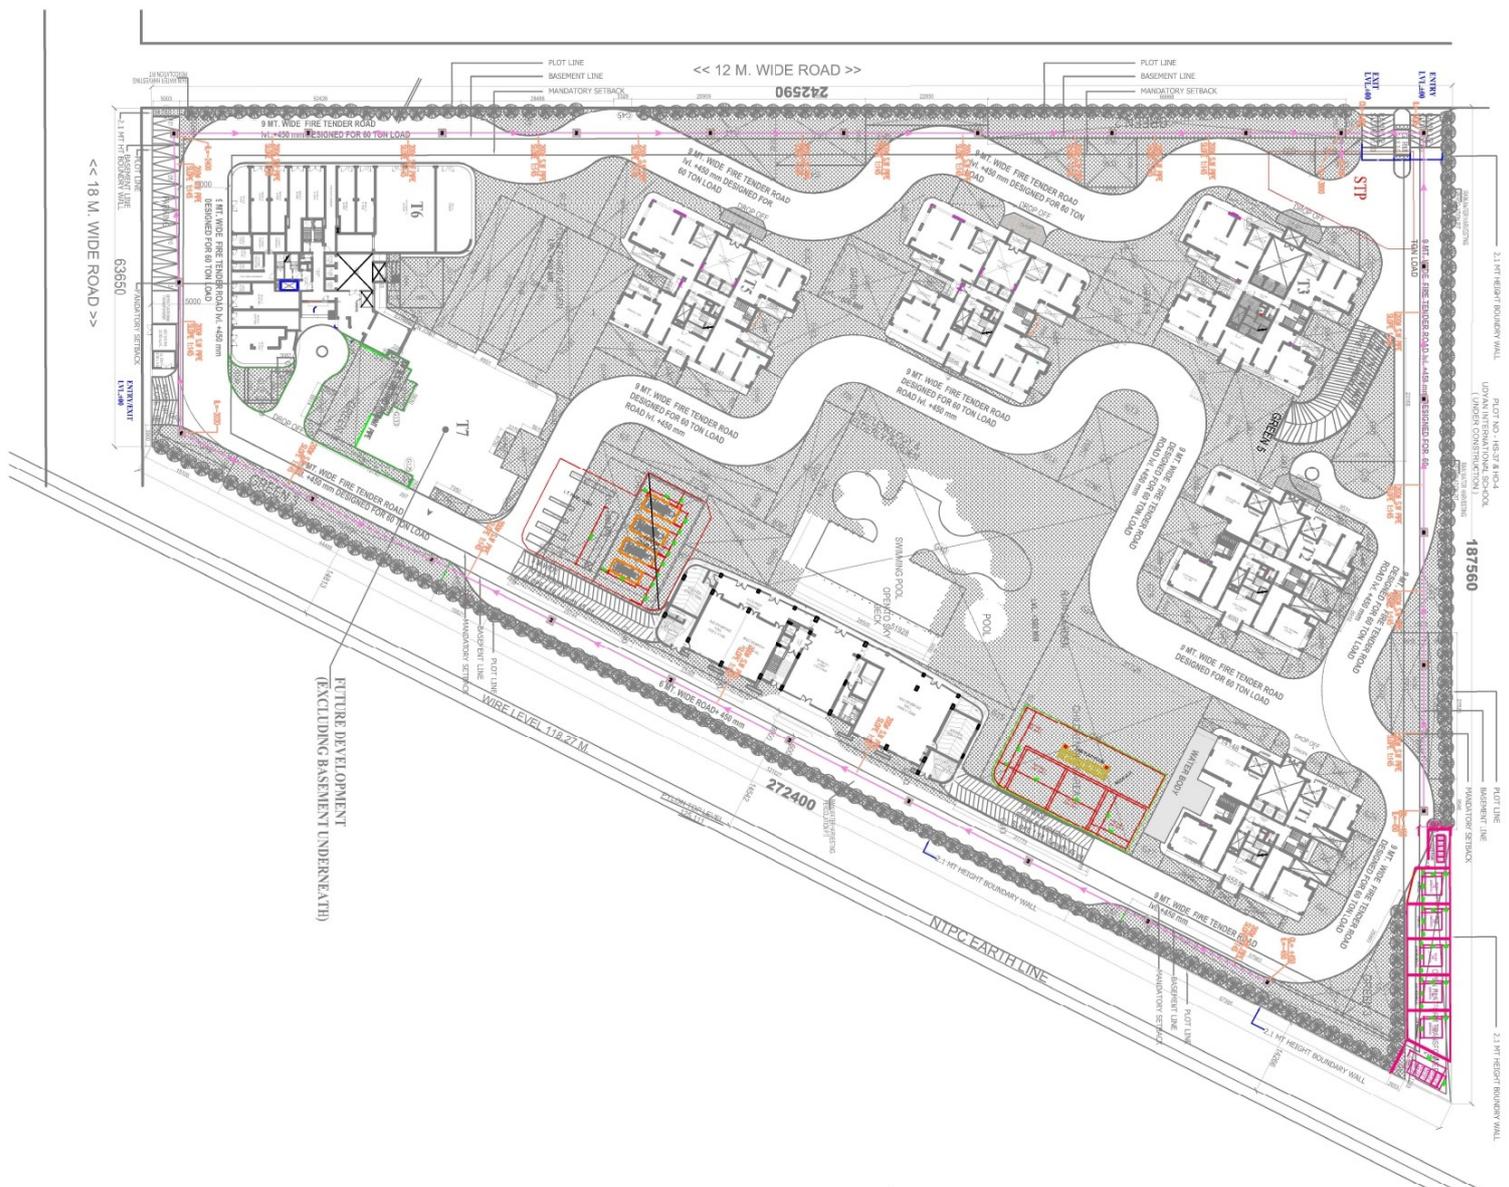

SUBMISSION DRAWING

NOTES:
 1. BUILDING IS DESIGNER'S STRUCTURES)
 AS PER RELEVANT IS CODES FOR
 2. MECHANICAL VENTILATION SYSTEM
 PROVIDED IN BASEMENT AS PER N.B.C.

ARCHITECT:



DESIGNED BY:
 ARCHITECT'S SIGNATURE:
Vidhan Chand Jha
 1234567890
 1234567890
 1234567890

OWNER'S SIGNATURE:
 ARCHITECT'S SIGNATURE:
Avanish srivastav
 1234567890
 1234567890
 1234567890

CLIENT:
 ELDECO HOMES DEVELOPERS LIMITED

DRAWING TITLE:
 SITE PLAN

(SEQUENCE LAYOUT)

SCALE: 1:100

DATE: 12.08.2025

DWG NO: S.P.-03