


ELECTRICAL SUPPLY PLAN

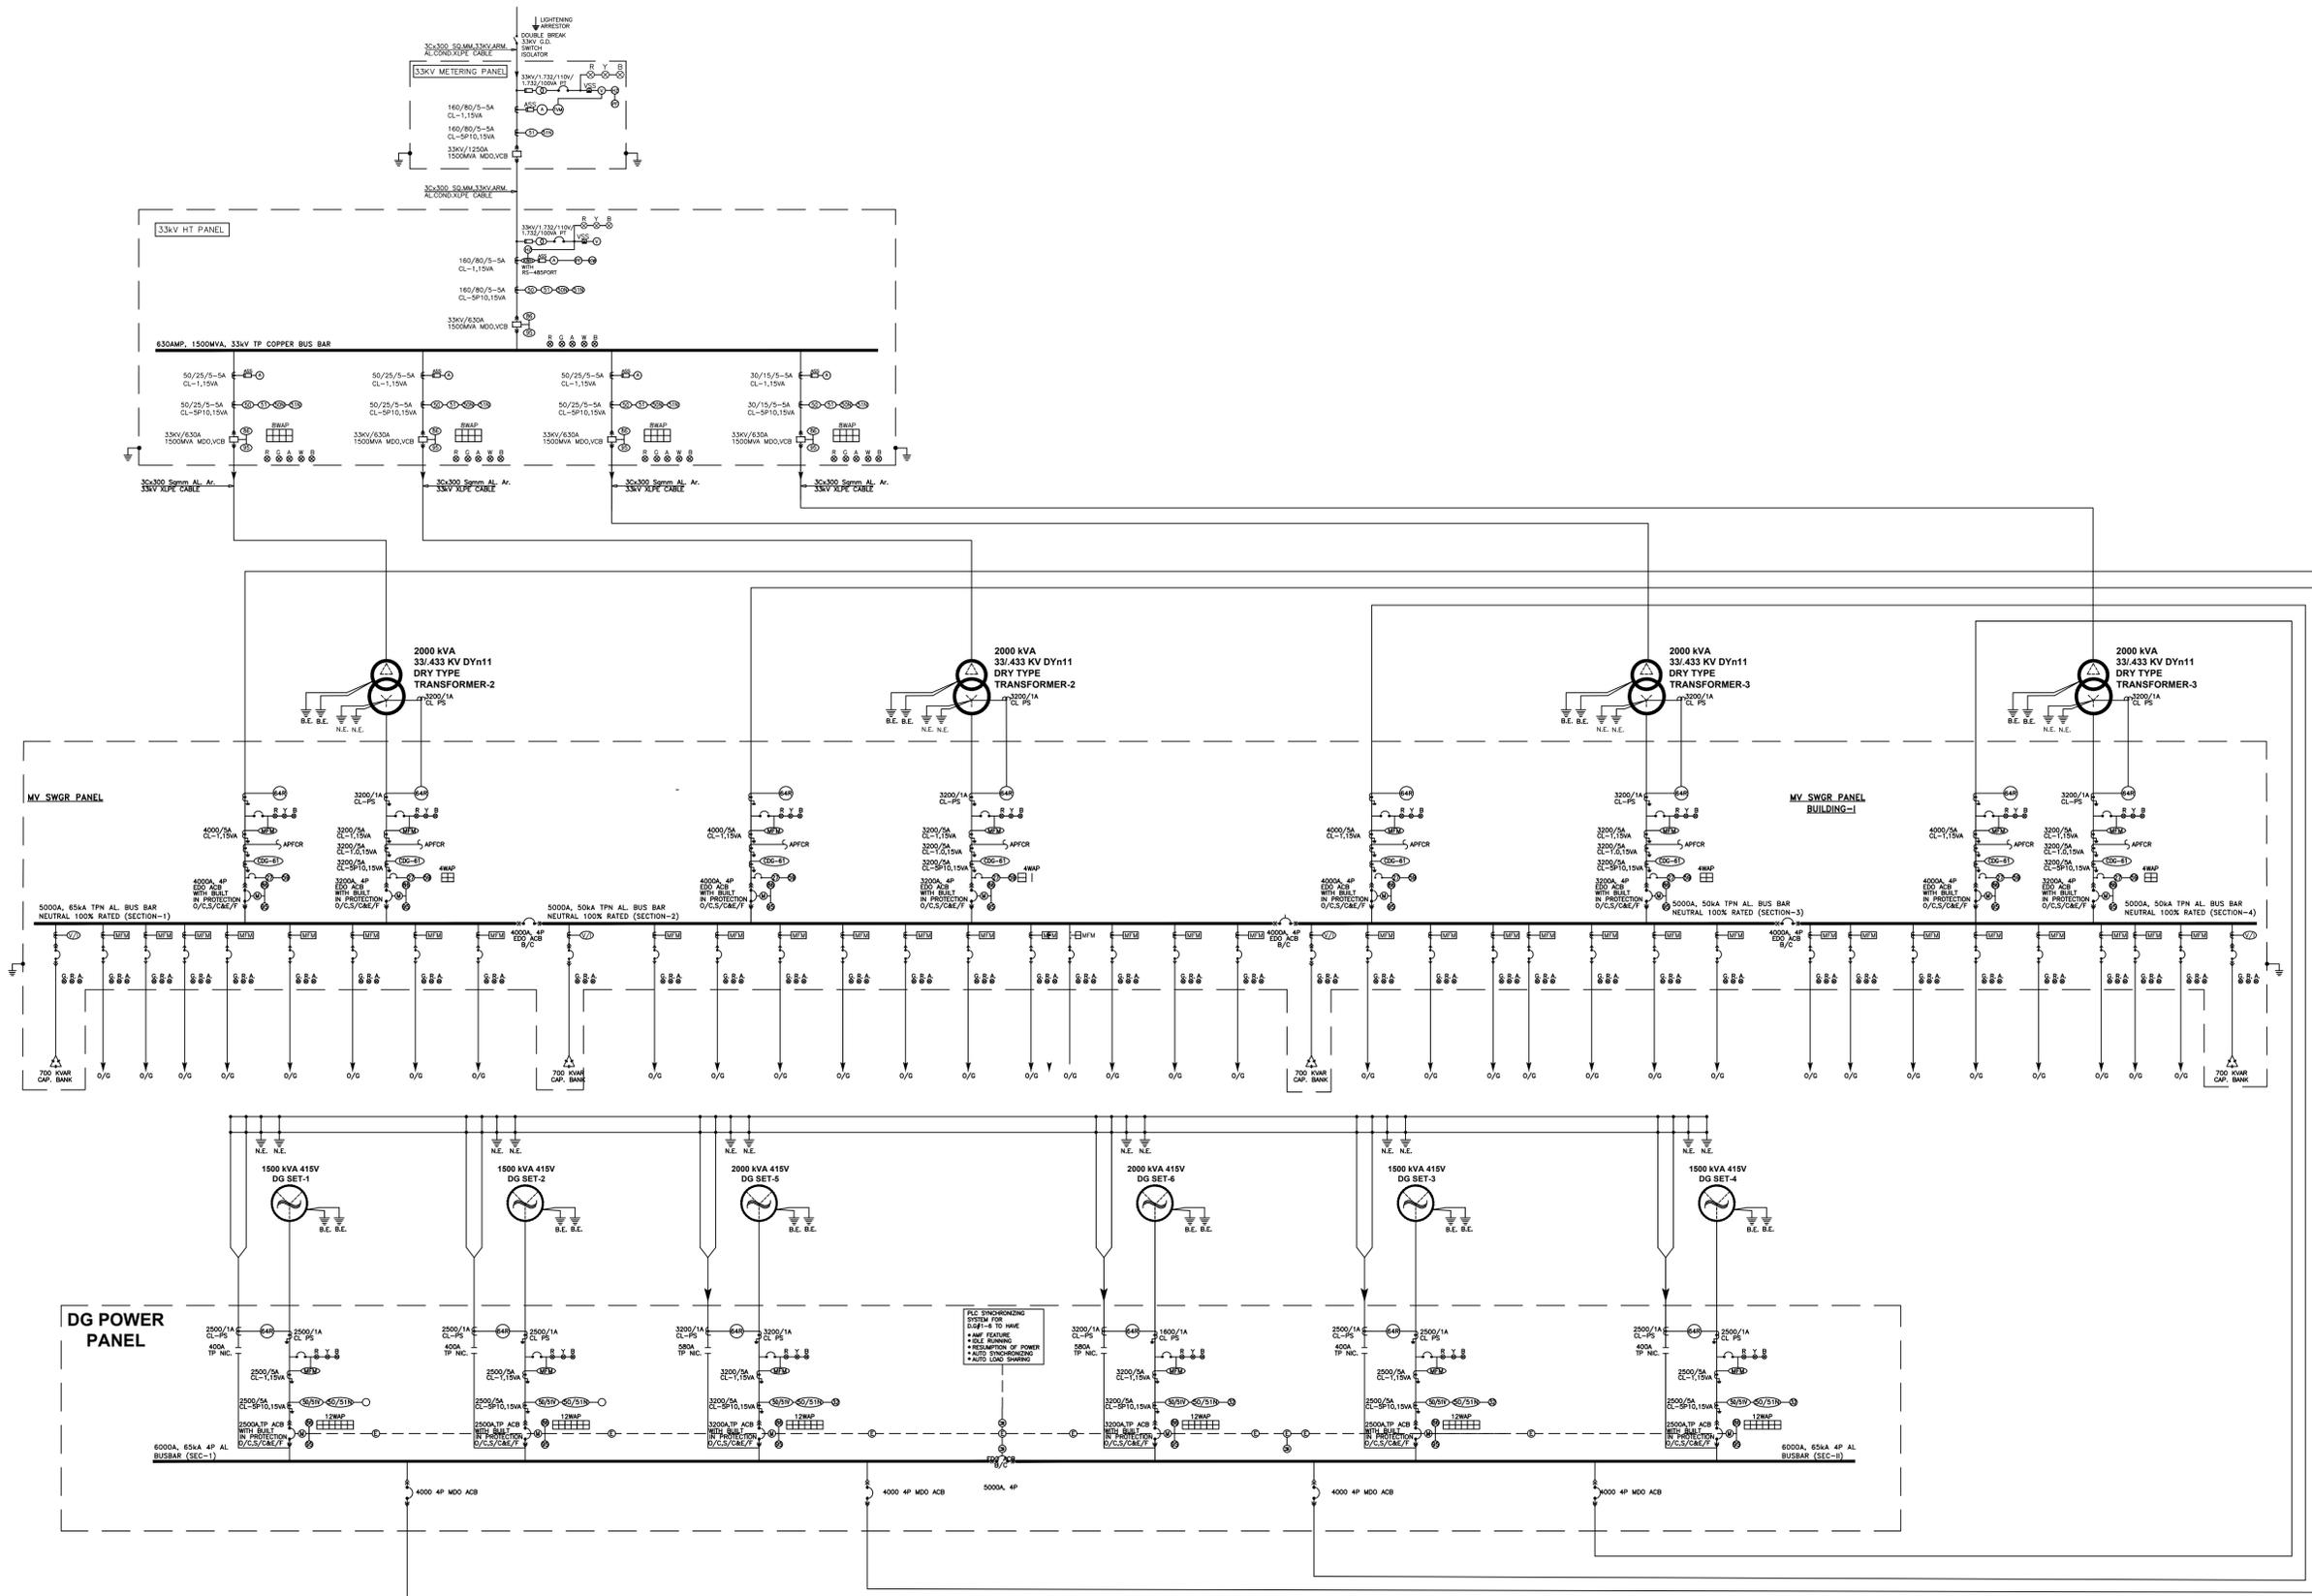

PROPOSED PROJECT PHASE (BLOCK-A) OF 17440 SQ.MET LAND

DATE	R.NO	REVISION	BY

DATE	NO	PRINT ISSUED TO	BY

ARCHITECT:-
 GIAN P. MATHUR AND ASSOCIATES (P) LTD.
 C - 55, East Of Kailash, New Delhi-110065
 ARCHITECTS T : 465995991 F 465995112
 & PLANNERS E : info@gpmindia.com I W : www.gpmindia.com

SERVICES CONSULTANTS:-

SANELAC
 CONSULTANTS PVT LTD.
 CORPORATE OFFICE:
 C - 64 / 2, OKHLA INDUSTRIAL AREA, PHASE-II,
 NEW DELHI-110020.
 TEL: 26385310, 40503959,
 E-mail: sanelac.consultants@gmail.com

PROJECT:-
**PROPOSED COMMERCIAL AT PLOT NO-21 AT
 SECTOR TECHZONE-IV, GREATER NOIDA WEST
 EXTENSION**
 BEING DEVELOPED BY M/S ARTHA INFRA TECH PVT. LTD.

TITLE:			
ELECTRICAL MAIN SINGLE LINE DIAGRAM			
SCALE	DATE	DESIGN	DRAWN
N.T.S@A1	14.08.19	I.D.JAIN	SAHIL
DRAWING NO.	REV.	REV. DATE	APPROVED
A/EL-MISC-01			I.D.JAIN
SUBMISSION DWG.			