

NOTE: ALL DIMENSION & LEVELS ARE IN MM

ARCHITECTS:


GRANT MATHEW AND ASSOCIATES PVT. LTD.
 C-10, 1st Floor, Main Road, Opp. SBI, K. J. Somaiya Institute of Engineering & Information Technology, V. V. Narayan
 ARCHITECT SIGNATURE:

CLIENT:
 ARMY WELFARE HOUSING ORGANISATION
 SOUTH INDIA WELFARE HOUSING ORGANISATION
 RAJAJI MANGALAYAM DSH-1 (D01)
 OWNER SIGNATURE:
 (Signature)
 For (Signature)
 ANHO

JOB TITLE:
 SUBMISSION DRAWING
 PROJECT:
 A WHO-VINDAVAN YOJNA
 SECTOR- 6A PLOT NO- GH-2, GH-3 & GH-4
 VINDAVAN AMAS YOJNA, LUCKNOW (UP)
 DRAWING TITLE:
 FLOOR PLANS, ELEVATIONS & SECTIONS
 GUARD ROOM, METER ROOM & COMMUNITY SHOPPING




JOB NO.
 DRAWING NO.
 SCALE: 1:100
 DATE: 25-08-2015
 DRAWN BY: (Signature)
 CHECKED BY: (Signature)
 U.P. HOUSING AND DEVELOPMENT BOARD -

ASSOCIATE ARCHITECT: (Signature)

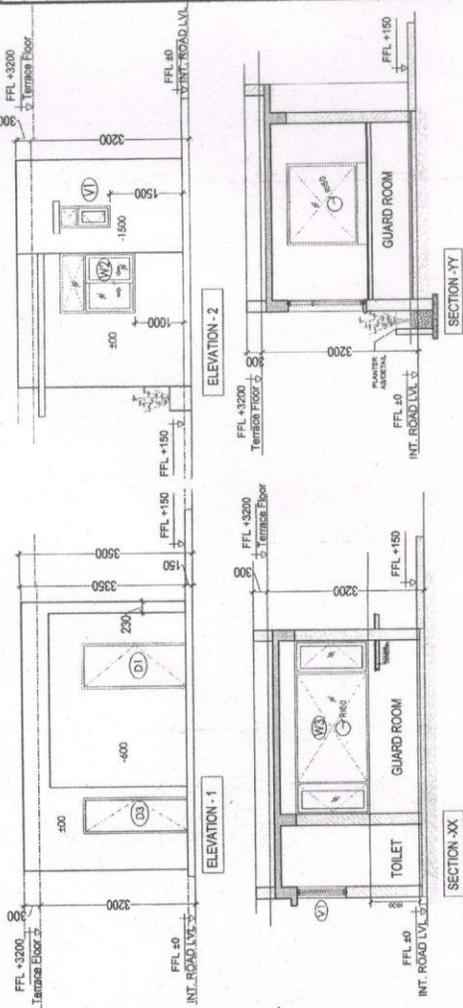

NO	WIDTH (B) (mm)	HEIGHT (H) (mm)	GLL (mm)	LEVEL (m)
D1	900	2100	-	2140
D2	1000	2100	-	2140
D3	1000	2100	-	2140
D4	1000	2100	-	2140
D5	1000	2100	-	2140
D6	1000	2100	-	2140
D7	1000	2100	-	2140
D8	1000	2100	-	2140
D9	1000	2100	-	2140
D10	1000	2100	-	2140
D11	1000	2100	-	2140
D12	1000	2100	-	2140
D13	1000	2100	-	2140
D14	1000	2100	-	2140
D15	1000	2100	-	2140
D16	1000	2100	-	2140
D17	1000	2100	-	2140
D18	1000	2100	-	2140
D19	1000	2100	-	2140
D20	1000	2100	-	2140


NO	WIDTH (B) (mm)	HEIGHT (H) (mm)	GLL (mm)	LEVEL (m)	REMARK
SHOP-1	600	1800	600	2700	
SHOP-2	600	1800	600	2700	
SHOP-3	600	1800	600	2700	
SHOP-4	600	1800	600	2700	
SHOP-5	600	1800	600	2700	
SHOP-6	600	1800	600	2700	
SHOP-7	600	1800	600	2700	
SHOP-8	600	1800	600	2700	
SHOP-9	600	1800	600	2700	
SHOP-10	600	1800	600	2700	
SHOP-11	600	1800	600	2700	
SHOP-12	600	1800	600	2700	
SHOP-13	600	1800	600	2700	
SHOP-14	600	1800	600	2700	
SHOP-15	600	1800	600	2700	
SHOP-16	600	1800	600	2700	
SHOP-17	600	1800	600 </td <td>2700</td> <td></td>	2700	
SHOP-18	600	1800	600	2700	
SHOP-19	600	1800	600	2700	
SHOP-20	600	1800	600	2700	

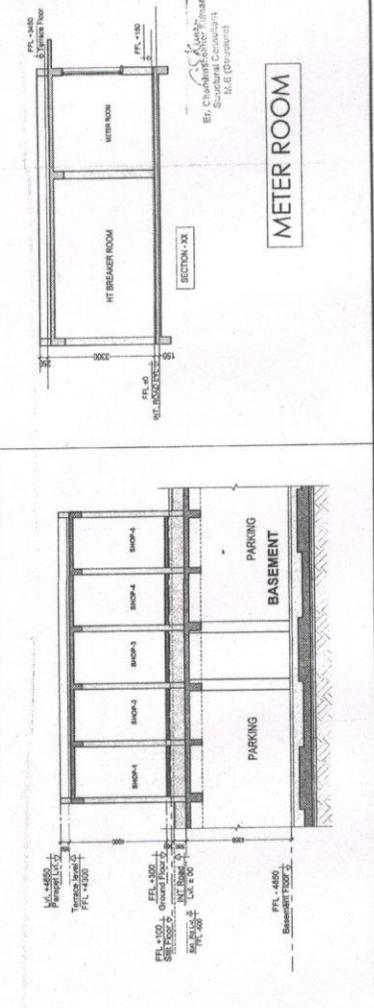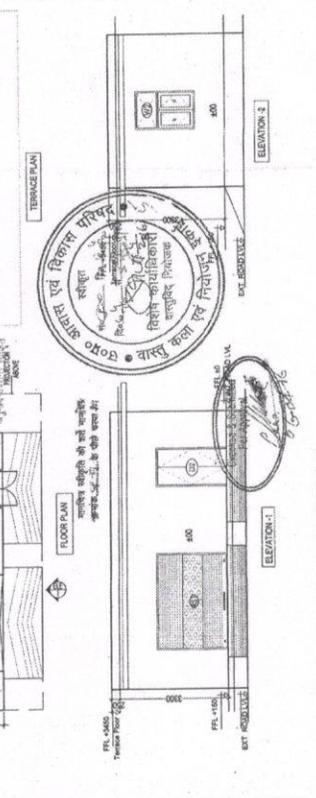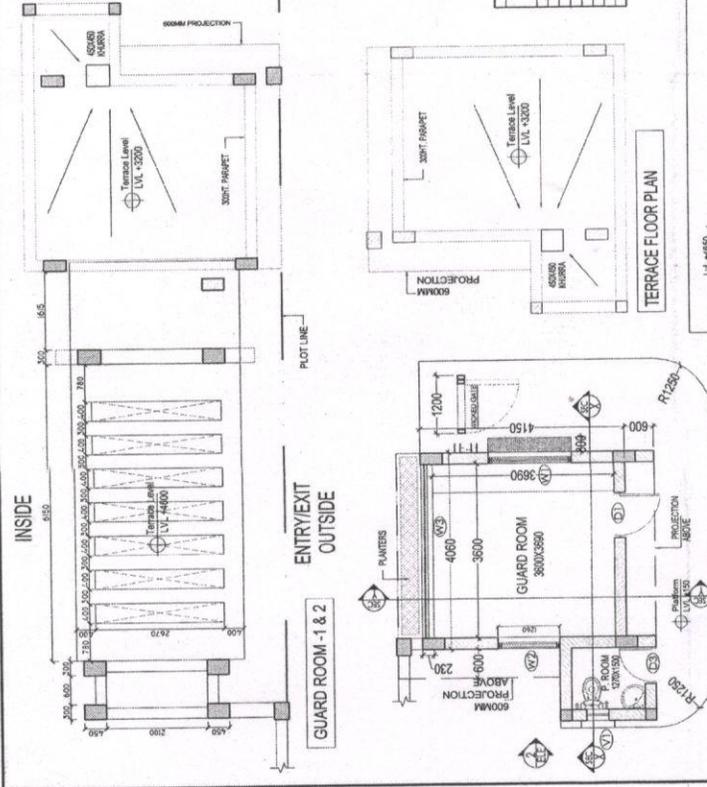

NO	WIDTH (B) (mm)	HEIGHT (H) (mm)	GLL (mm)	LEVEL (m)	REMARK
SHOP-1	600	1800	600	2700	
SHOP-2	600	1800	600	2700	
SHOP-3	600	1800	600	2700	
SHOP-4	600	1800	600	2700	
SHOP-5	600	1800	600	2700	
SHOP-6	600	1800	600	2700	
SHOP-7	600	1800	600	2700	
SHOP-8	600	1800	600	2700	
SHOP-9	600	1800	600	2700	
SHOP-10	600	1800	600	2700	
SHOP-11	600	1800	600	2700	
SHOP-12	600	1800	600	2700	
SHOP-13	600	1800	600	2700	
SHOP-14	600	1800	600	2700	
SHOP-15	600	1800	600	2700	
SHOP-16	600	1800	600	2700	
SHOP-17	600	1800	600	2700	
SHOP-18	600	1800	600	2700	
SHOP-19	600	1800	600	2700	
SHOP-20	600	1800	600	2700	

COMMUNITY SHOPPING

METER ROOM

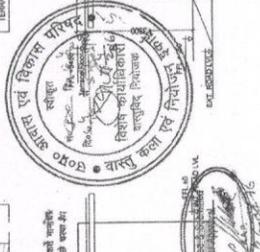

Dr. Chandrajit Kumar
 Structural Consultant
 S.E. (Structure)