

PRODUCED BY AN AUTODESK EDUCATIONAL PRODUCT

PRODUCED BY AN AUTODESK EDUCATIONAL PRODUCT

FIRST FLOOR
SANITARY PLAN

ISSUE:

drawn by:

Checked by:
A.KHADSE

Sheet No:

FileName:
D:/PROJECT/NEW IND.

Date:
06-04-2019


Scale:
NTS

PROJECT:
CONVENIENT SHOPPING CENTER C2-N5
JAYPEE GREENS, SECTOR 128,
NOIDA, U.P.



ARCHITECT:
ANIL KHADSE AND ASSOCIATES
ARCHITECTS,ENGINEERS,INTERIOR-DESIGNER
C-46, SECTOR-10, NOIDA, U.P-201301
PH: 4314396 TELEFAX : 4314396



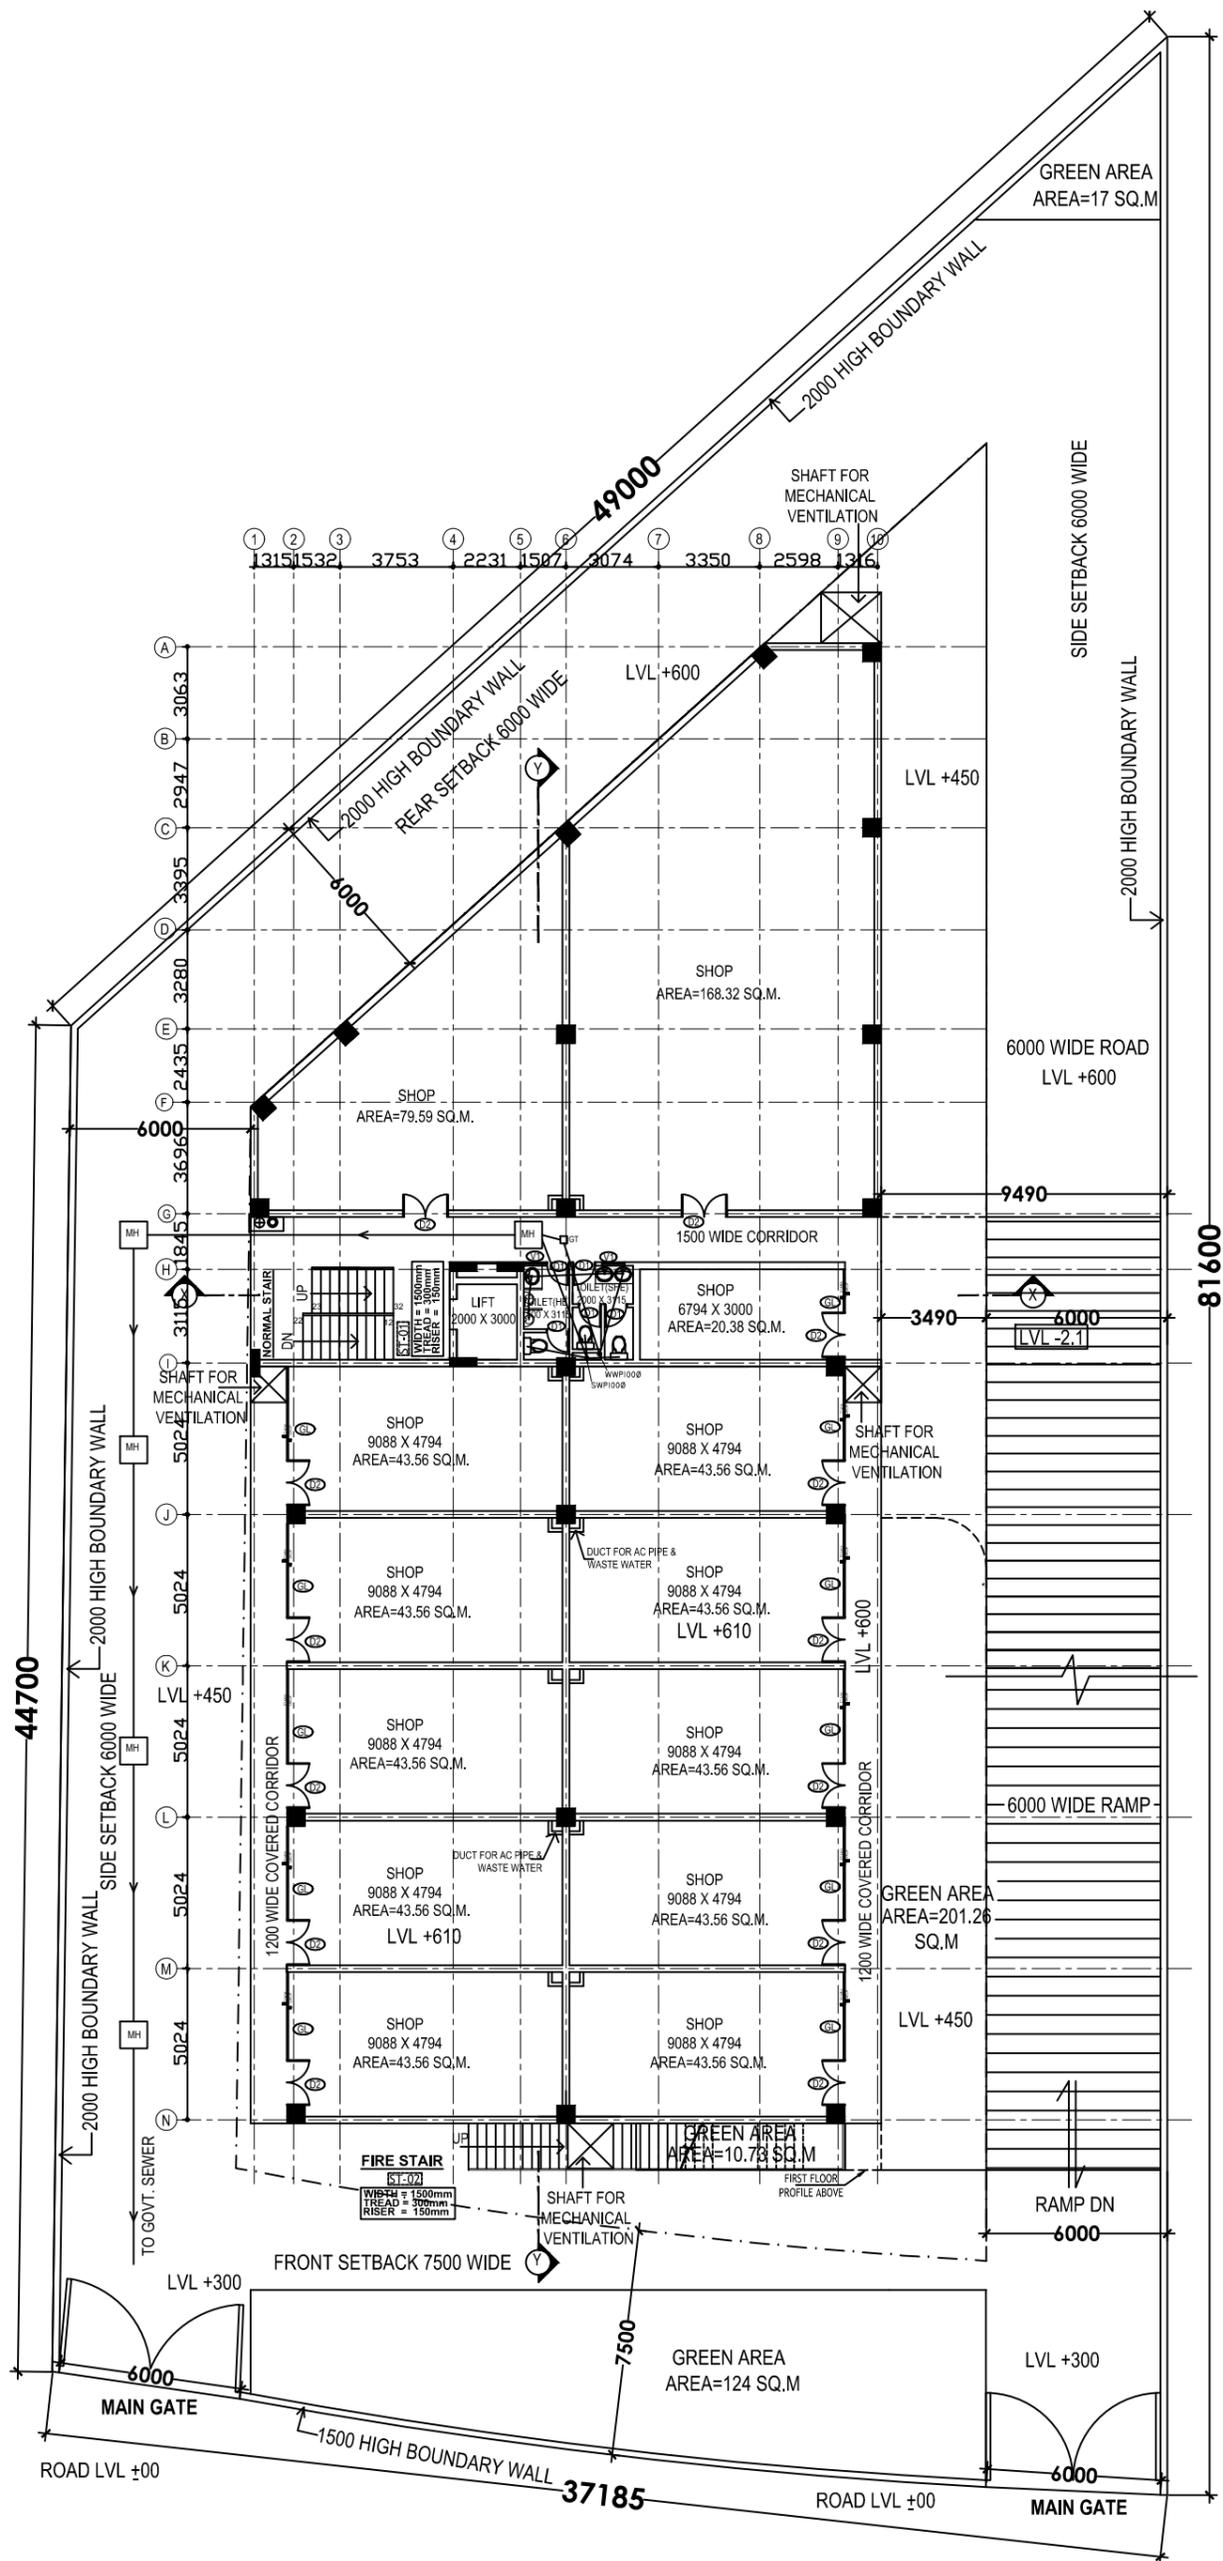

GROUND FLOOR
SANITARY PLAN

ISSUE:

drawn by:

Checked by:
A.KHADSE

Sheet No:

FileName:
D:/PROJECT/NEW IND.

Date:
06-04-2019

Scale:
NTS

PROJECT:
CONVENIENT SHOPPING CENTER C2-N5
JAYPEE GREENS, SECTOR 128,
NOIDA, U.P.

North



ARCHITECT:
ANIL KHADSE AND ASSOCIATES
ARCHITECTS, ENGINEERS, INTERIOR-DESIGNER
C-46, SECTOR-10, NOIDA, U.P.-201301
PH: 4314396 TELEFAX: 4314396

