


802229/14/18/5022 18/10/2014
 Final Sign. Date: 05/05/2014
 10m
 J. DONI
 (Dir. & Arch.)
 Planning, Design & Drawing By
 H.S. S. S. S.
 No. 17/1000 No. 10/07/08



LEGEND	
SYMBOL	DESCRIPTION
—●—	EXTERNAL SEWER LINE
- - -	EXTERNAL STORM LINE
.....	COLD WATER SUPPLY LINE
- - - -	FLUSHING WATER SUPPLY LINE
—●— (Red)	EXTERNAL FIRE HYDRANT RING
- - - (Red)	GARDEN HYDRANT RING
⊙ (MH)	EXTERNAL SEWER LINE MANHOLE
⊙ (SMH)	EXTERNAL STORM LINE MANHOLE
⊙ (EFH)	EXTERNAL FIRE HYDRANT (80# TO EFH)
⊙ (GH)	GARDEN HYDRANT (25# TO GH)

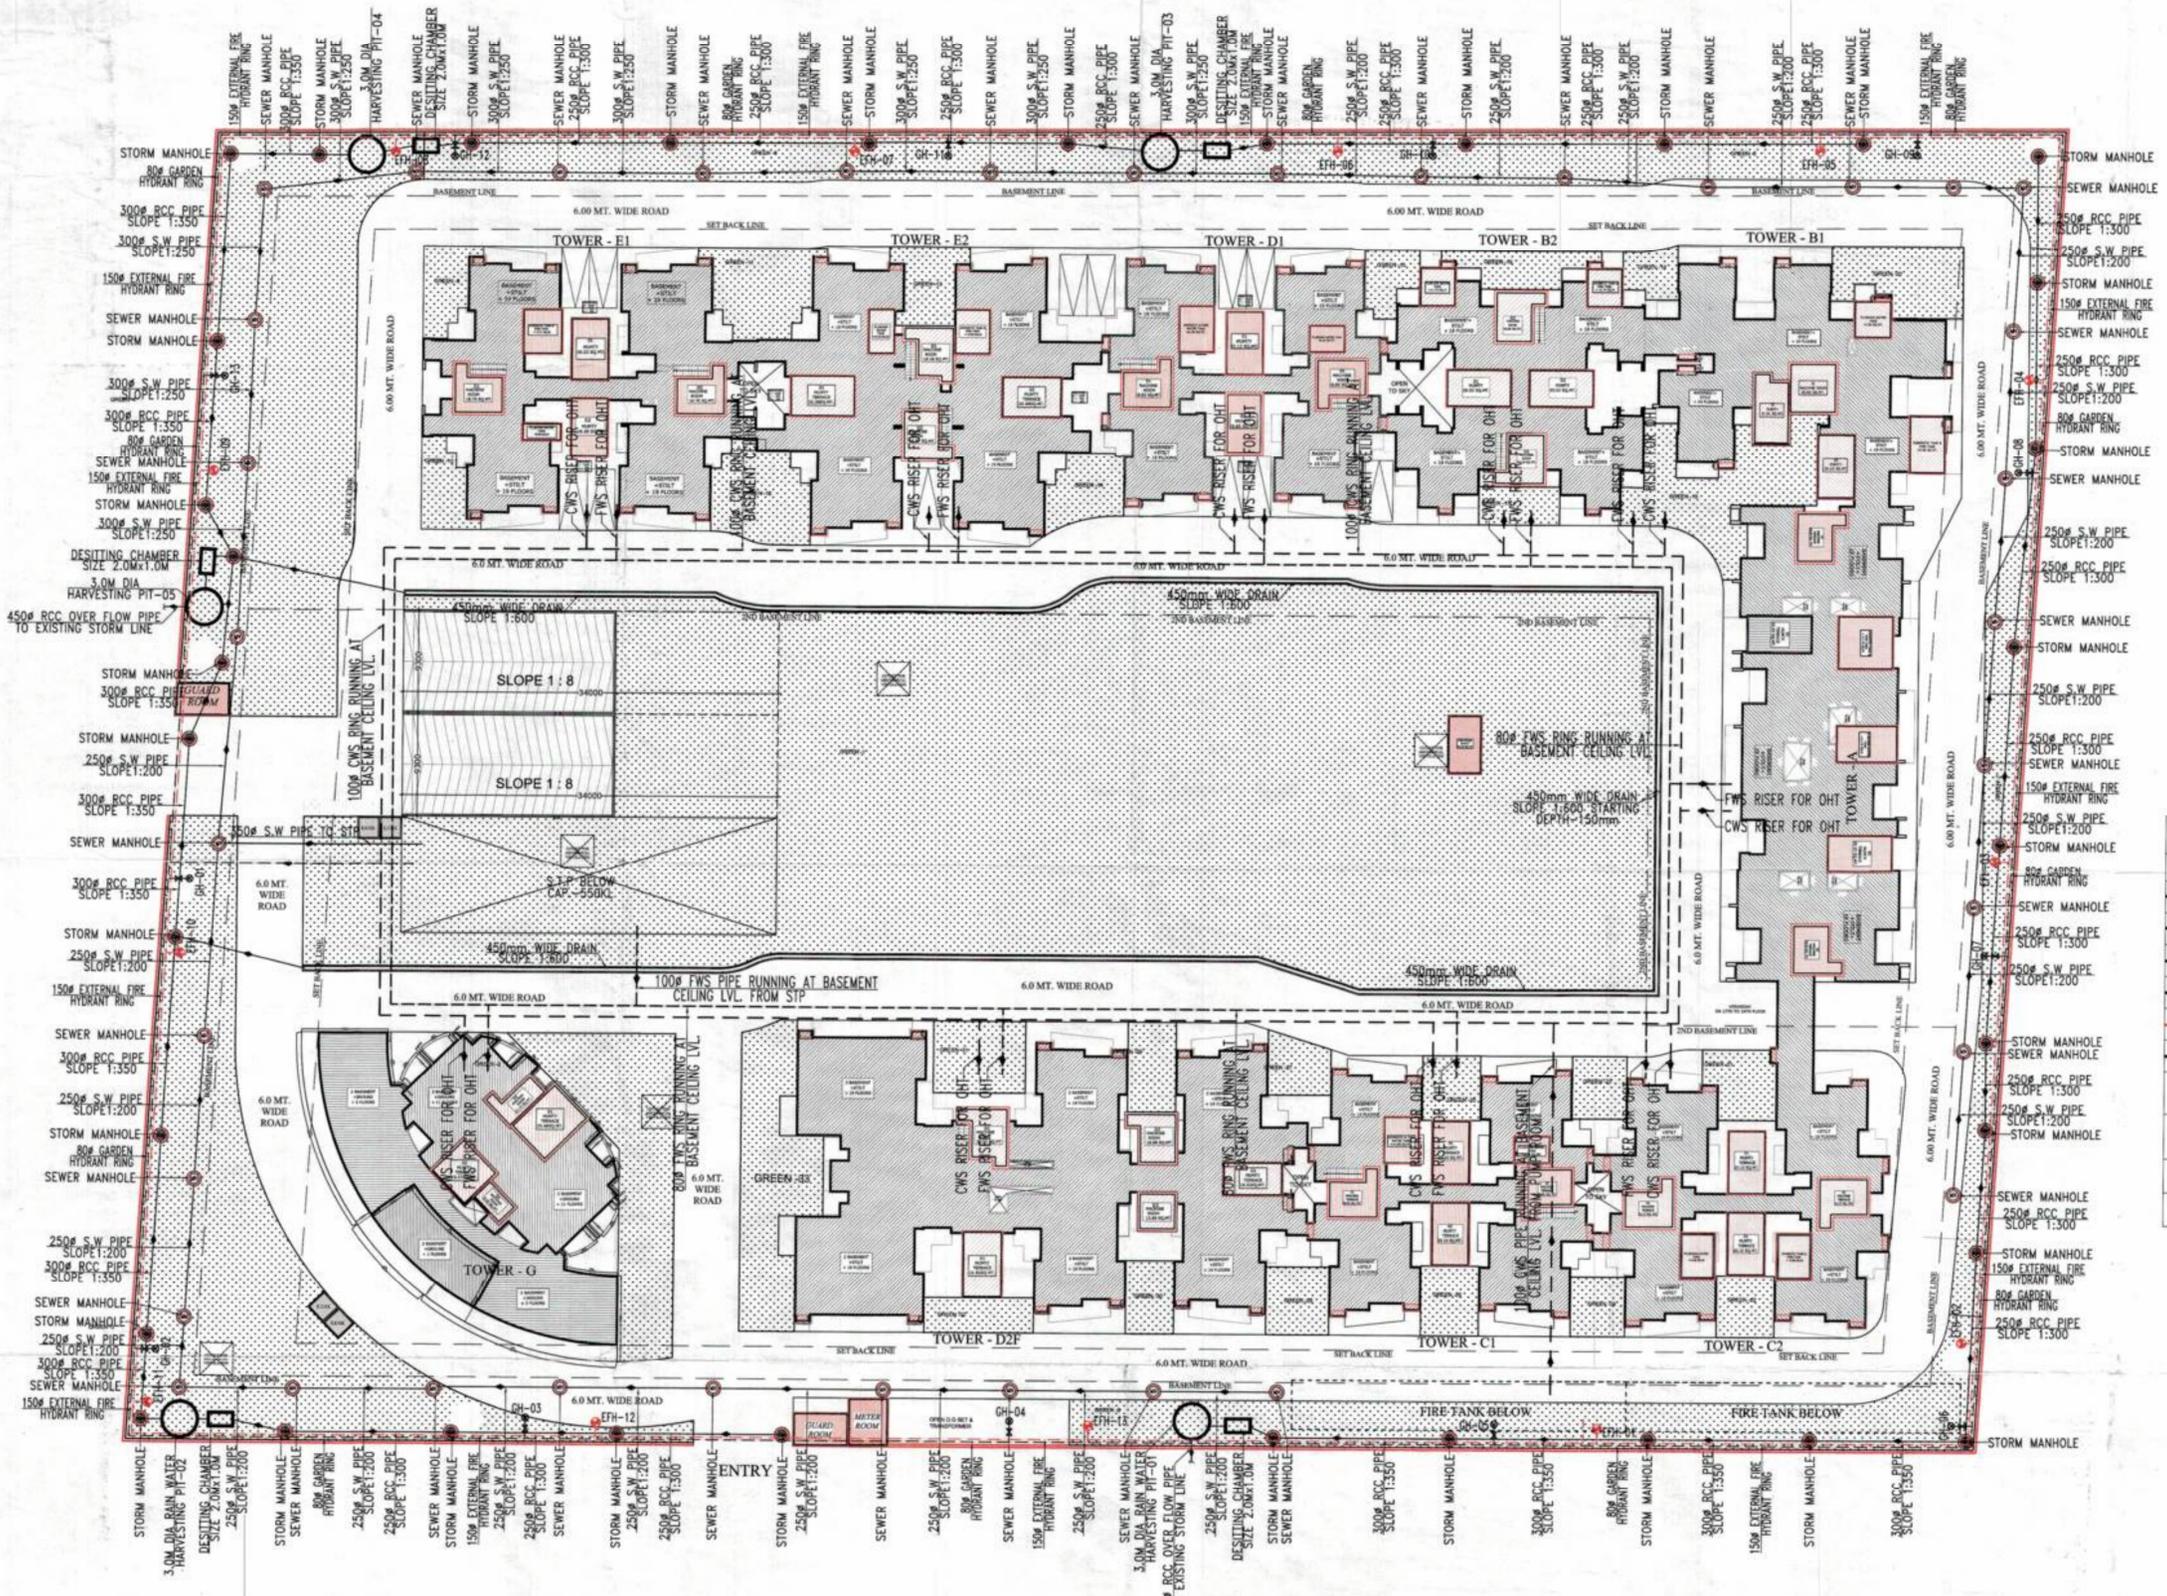

60 MT. WIDE ROAD

SITE PLAN WITH SERVICES

PROJECT -
'VEDANTAM'
 PROPOSED RESIDENTIAL COMPLEX
 AT PLOT NO - 01B, SEC-16C,
 GREATER NOIDA (U.P.)
 BUILDERS & PROMOTER -
 M/s JYOTIRMA INFRACON PVT. LTD.
 (AN SPC OF M/s RADICON
 INFRASTRUCTURE & HOUSING PVT. LTD.)

DRAWING TITLE :-
SITE PLAN WITH SERVICES

For JYOTIRMA INFRACON (P) LTD.
 DIRECTOR
OWNER SIGN ARCHITECT SIGN

APR 2014
 ARCHITECTS:
APS GREEN ARCHITECTS & ASSOCIATES
 (ARCHITECTS, ENGINEERS & INTERIOR DESIGNERS)
 OFFICE: NO. 06, FIRST FLOOR, METRO MALL, MAIN PLAZA
 SECTOR - 4, VAISHALI, GHAZIABAD, (U.P.)
 PH. NO. - 9819827734, (0120) 4108277
 E-MAIL: apsgreenarchitects@gmail.com
 DRAWN BY: KAMAL CHECKED BY: ASEEM SCALE: 1:300 DATE: _____ DRC. NO.: _____