


LEGEND

①	1100 SOIL PIPE
②	1100 WASTE PIPE
③	750 VENT PIPE
④	COLD WATER SUPPLY PIPE
⑤	FLUSHING WATER SUPPLY PIPE
⑥	FLUSHING RISER TO FILL O/H TANK
⑦	DOMESTIC RISER TO FILL O/H TANK
Ⓡ	160mm DIA RAIN WATER PIPE

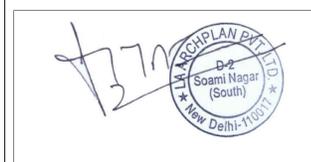

SUBMISSION DRAWING

REV. NO.	DATE	DESCRIPTION
REVISIONS		

ARCHITECT:  

**LA ARCH PLAN PVT.LTD.**  
 D-2, SOAMI NAGAR (SOUTH)  
 NEW DELHI-130017,INDIA.  
 TEL. 42593900

SERVICES CONSULTANTS:  

**UDAYAN CHAUDHARI & ASSOCIATES PVT.LTD.**  
 40/60, 2nd. FLOOR, CHITTARANJAN PARK  
 NEW DELHI - 110 019  
 TEL. : 26418363, 26471312  
 FAX. : 26283342  
 E-MAIL: udayanchaudhari@gmail.com

Project:  
**IMPERIAL SQUARE AT  
 KANPUR**


DRAWING TITLE:  
**TYP. TOILET DETAILED  
 DRAINAGE & WATER SUPPLY  
 LAYOUT**

DATE	DEALT	CHECKED	STATUS
17.08.2019	HK	AB	
DRG. NO.	REV.	SCALE	
PL-15	RO	NTS	

THIS DRAWING IS THE PROPERTY AND COPY RIGHT OF UDAYAN CHAUDHARI & ASSOCIATES PVT. LTD. AND THE SAME SHALL NOT BE COPIED OR USED IN ANY WAY WITHOUT THEIR WRITTEN PERMISSION.

**LEGEND**

①	1100 SOIL PIPE
②	1100 WASTE PIPE
③	750 VENT PIPE
④	COLD WATER SUPPLY PIPE
⑤	FLUSHING WATER SUPPLY PIPE
⑥	FLUSHING RISER TO FILL O/H TANK
⑦	DOMESTIC RISER TO FILL O/H TANK
Ⓡ	160mm DIA RAIN WATER PIPE

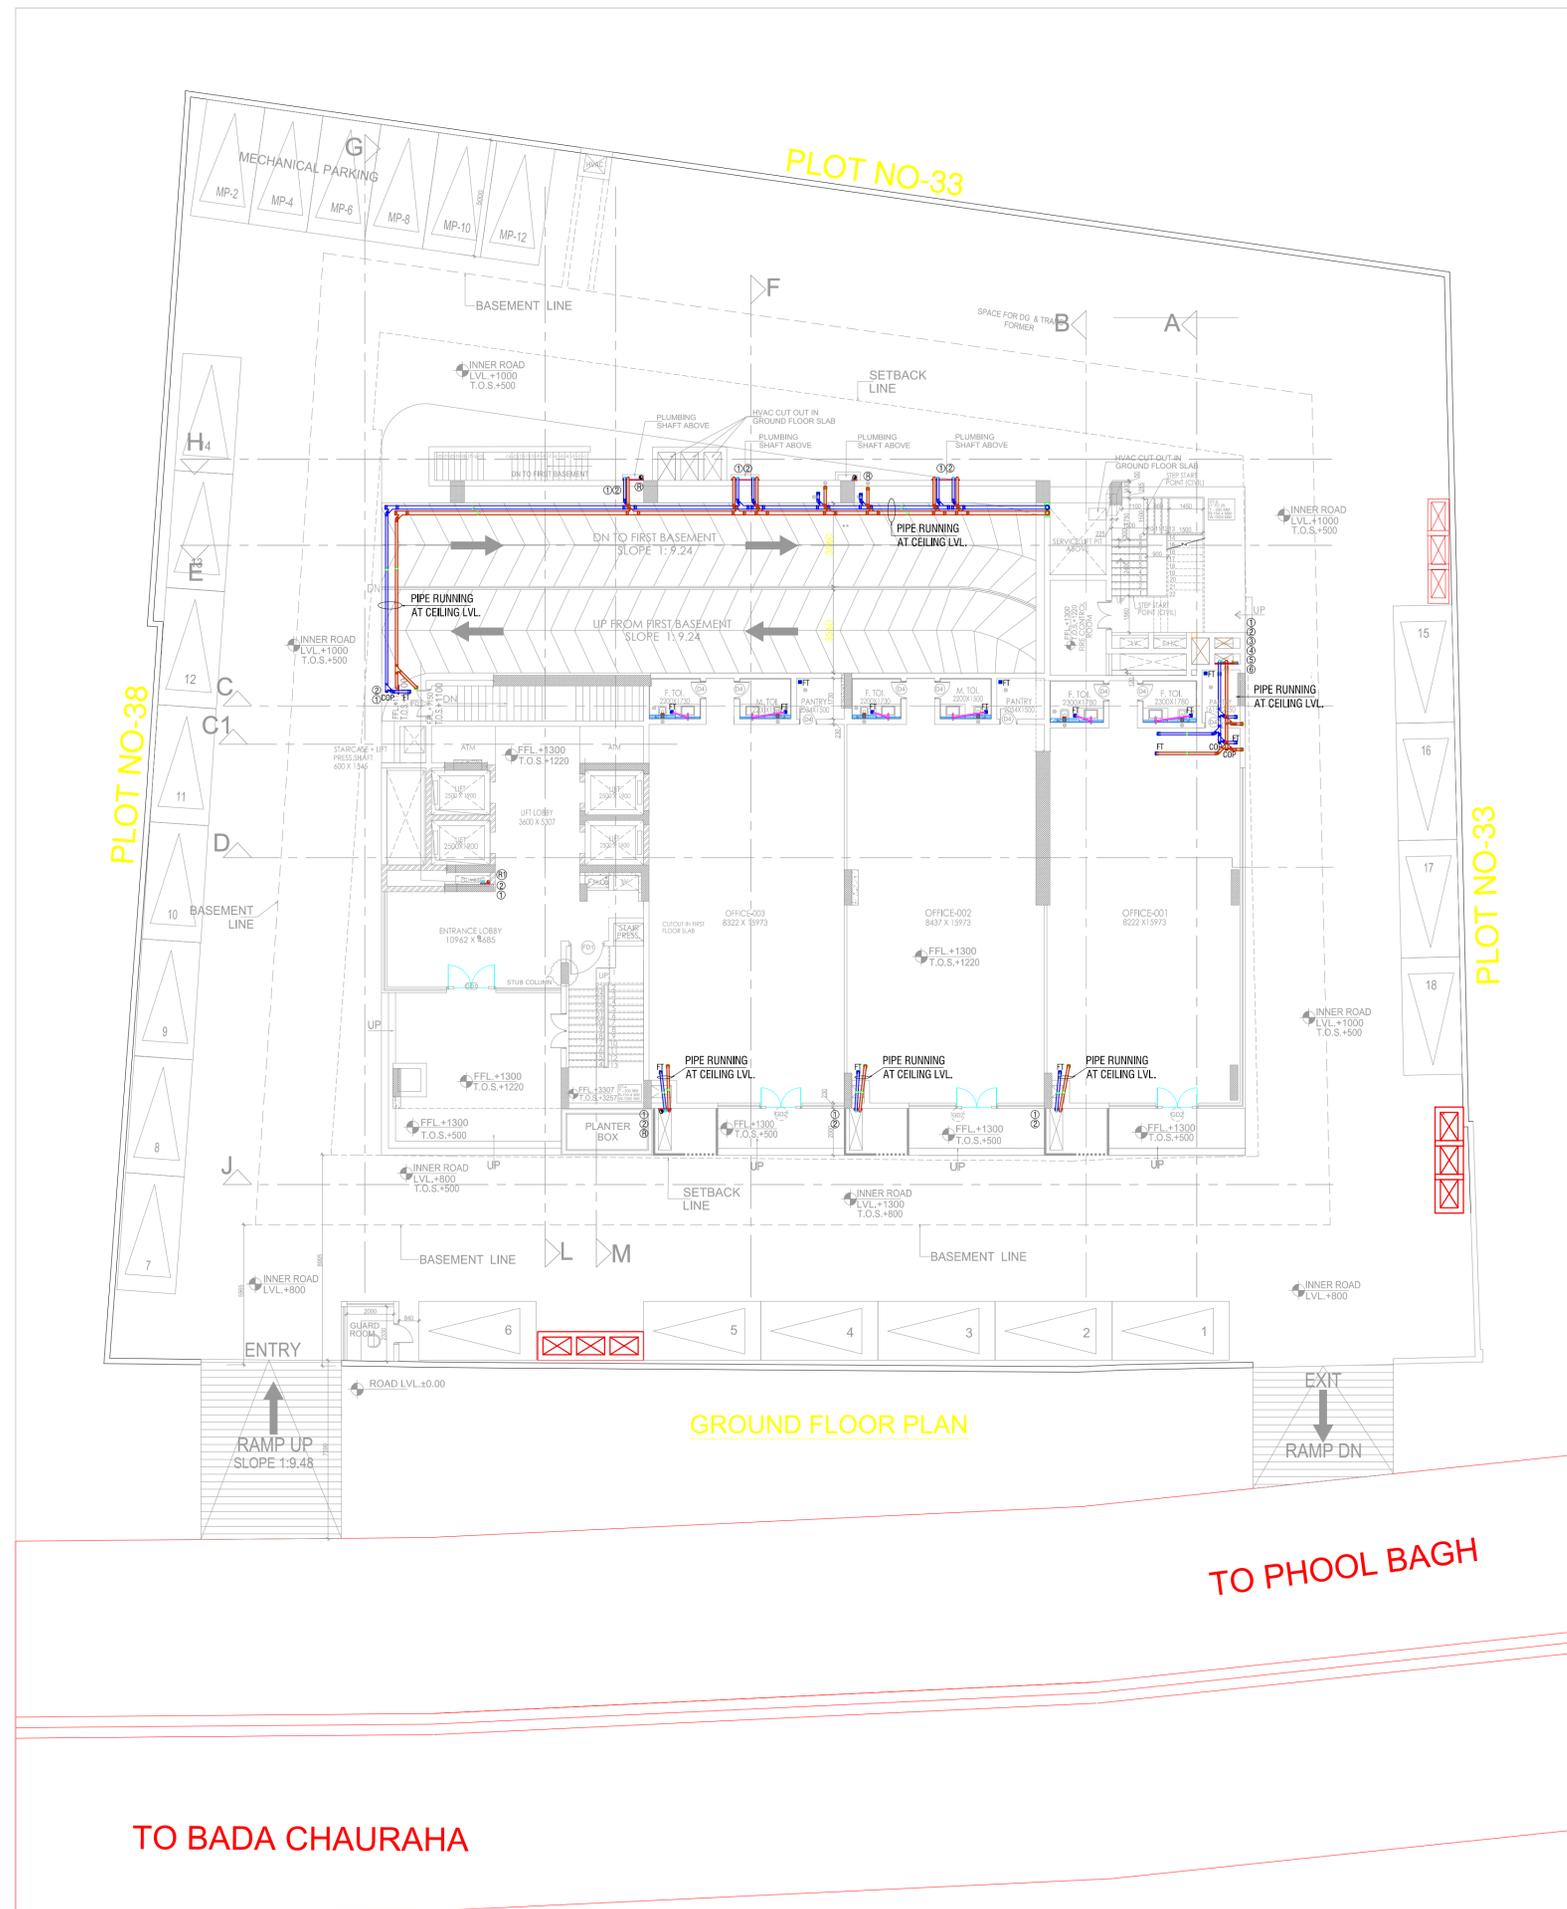

**SUBMISSION DRAWING**

REV. NO.	DATE	DESCRIPTION
<b>REVISIONS</b>		

**ARCHITECT:**  

**LA ARCH PLAN PVT. LTD.**  
 D-2, SOAMI NAGAR (SOUTH)  
 NEW DELHI-130017, INDIA.  
 TEL. 42593900

**SERVICES CONSULTANTS:**  
**UDAYAN CHAUDHARI & ASSOCIATES PVT. LTD.**  

 40/60, 2nd. FLOOR, CHITTARANJAN PARK  
 NEW DELHI - 110 019  
 TEL. : 26418363, 26471312  
 FAX. : 26283942  
 E-MAIL: udayanchoudhari@gmail.com

**Project:**  
**IMPERIAL SQUARE AT KANPUR**  
**DRAWING TITLE:**  
**GROUND FLOOR PLAN**

DATE	DEALT	CHECKED	STATUS
17.08.2019	HK	AB	
DRG. NO.		REV.	SCALE
PL-04A		RO	NTS

**TO PHOOL BAGH**

**TO BADA CHAURAHA**

**GROUND FLOOR PLAN**