





GRANDTHUM PHASE-III

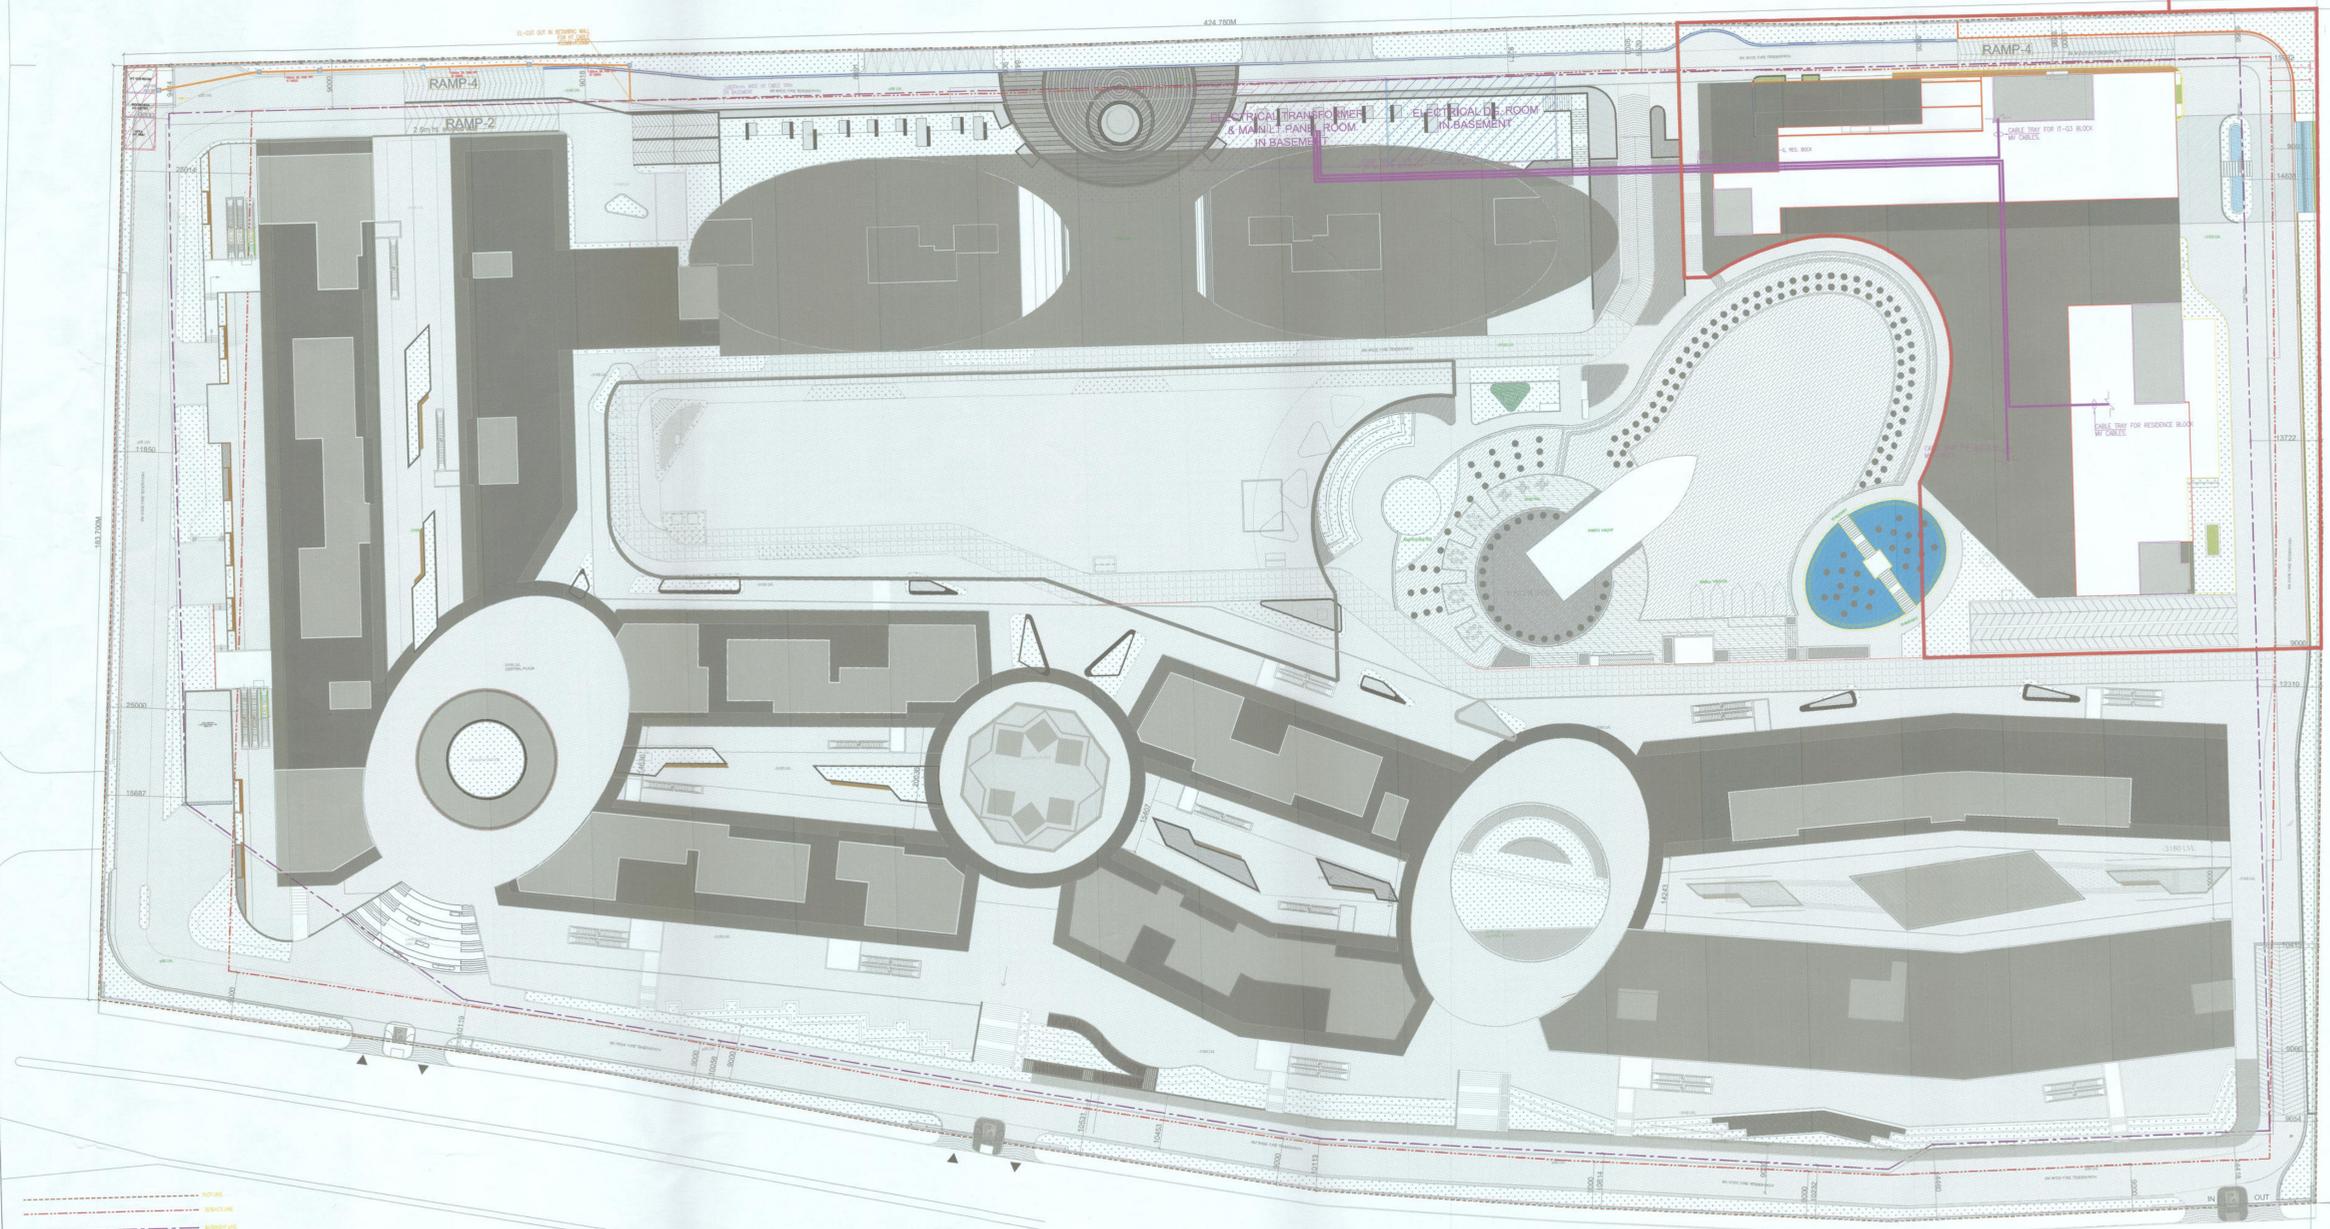

SUBMISSION
 PROJECT:
 PROPOSED INSTITUTIONAL BUILDING
 AT SECTOR TECH ZONE-4, PLOT-7,
 GREATER NOIDA
 M/S A.L. SOFTWEB PVT.LTD.

DRAWING TITLE:
SITE ELECTRICAL PLAN

OWNER'S SIGN: *[Signature]*
 ARCHITECT'S SIGN: *[Signature]*
Dr. AMISH BHUTANI
 Managing Director
KULMEET SHANGARI
 ARCHITECT
 CA/97/21741

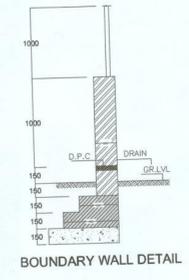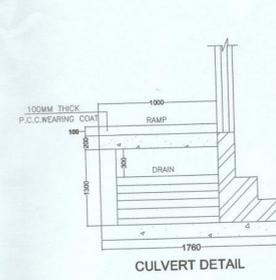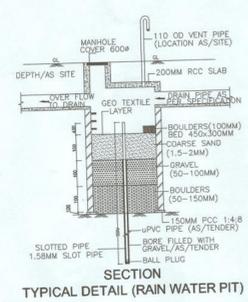

ARCHITECT:	ISO 9001:2008	NORTH
ACPL	Architecture Management Planning	
ACPL Design Ltd	11-1111, 11-1111, 11-1111	
SCALE: 1:500	DEALT BY: G.K.	DATE: 29/01/2026
DESIGN BY: G.K.	CHECKED BY: A.G.	DRG. No. BASE/EL-01