

LEGEND



SYMBOL	DESCRIPTION
	SEWER LINE
	SEWER MANHOLE

SCHEDULE OF MANHOLE

DIA (in mm)	DEPTH
900Ø	900mm-1650mm
1200Ø	1650mm-2300mm
1500Ø	2300mm-9000mm
1800Ø	9000mm-14000mm

LEGEND:	SIZE & AREA	NOS.	%
	(9.00 x 19.70=177.30 sq.m.) 212 SQYD	10	21 %
	(7.50 x 16.70=125.25 sq.m.) 150 SQYD	16	34 %
	(7.00 x 14.25=99.75 sq.m.) 120 SQYD	21	45 %
	TOTAL NOS. OF PLOTS	47	

 MORTGAGED PLOTS
TOTAL AREA = 1308.23 SQM

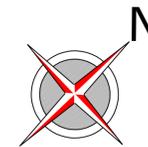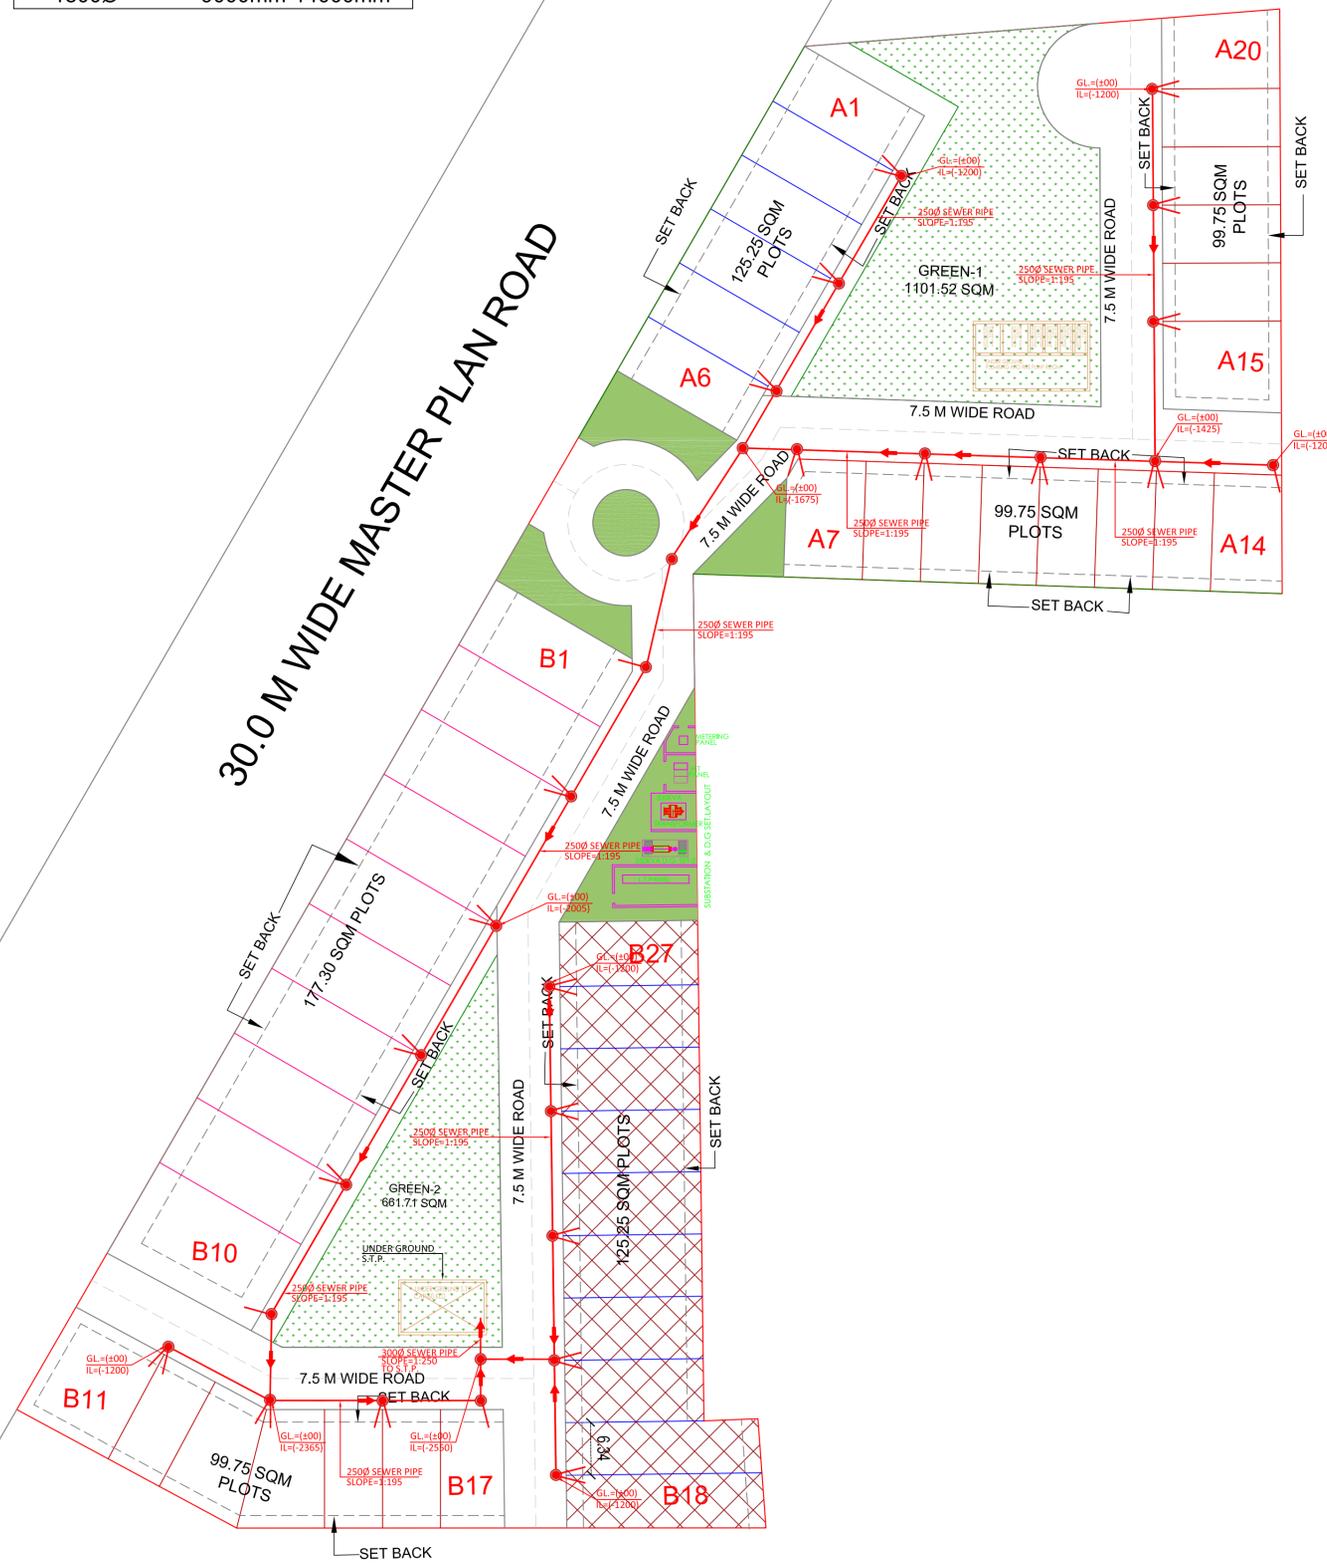

SUBMISSION DRAWING

DATE	NO.	ISSUED TO	FOR
13.01.25	-	ARCHITECT	SUBMISSION
06.01.25	-	ARCHITECT	SUBMISSION

ISSUES

DATE	REV. NO.	DESCRIPTION
13.01.25	R1	U.G.T. & S.T.P. LOCATION CHANGE AS PER ARCHITECT COMMENTS.

CLIENT

PROJECT

PLOTTING AT NIZAMPUR, PILAKHUA

ARCHITECTS:  **Space Designers International**
B-34, SECTOR-67, NOIDA
PH: +91 971923777, 98, 98 & 20
MOB: 9910709999, 9911330231
email: spaceid@gmail.com, www.spaceid.com

MEP Consultants
 **MAVERICK ENGG. CONSULTANT (P) LTD.**
Electro-Mechanical Consulting engineers
A-440, 4TH FLOOR
LOGIXTECHNOVA, SECTOR-132, NOIDA-201304
P: +91-01203141581, 9911933696
E-mail: mavrickenggmep@gmail.com, mavrickengg23@gmail.com

PLUMBING DRAWING

TITLE: **EXTERNAL SITE PLAN
SEWERAGE DRAINAGE LAYOUT
(RESIDENTIAL BUILDING)**

DEALT BY: P.K	APPROVED BY:
CHKD BY: D.SINGH	PROJECT NO.
SCALE: 1:400	DATE: 06.01.2025
SIGN:	DRAWING NO. NORTH
<input checked="" type="checkbox"/> FOR SUBMISSION	DR-SW-R-01
<input type="checkbox"/> FOR INFORMATION	REVISION:
<input type="checkbox"/> FOR EXECUTION	R0 R1
<input type="checkbox"/> FOR APPROVAL	
<input type="checkbox"/> FOR GFC	

THIS DRAWING IS THE SOLE PROPERTY OF MAVERICK ENGINEERING PVT. LTD. AND IS NOT TO BE COPIED OR REPRODUCED WITHOUT THEIR PERMISSION

SIZE
A1