



**SITE PLAN**

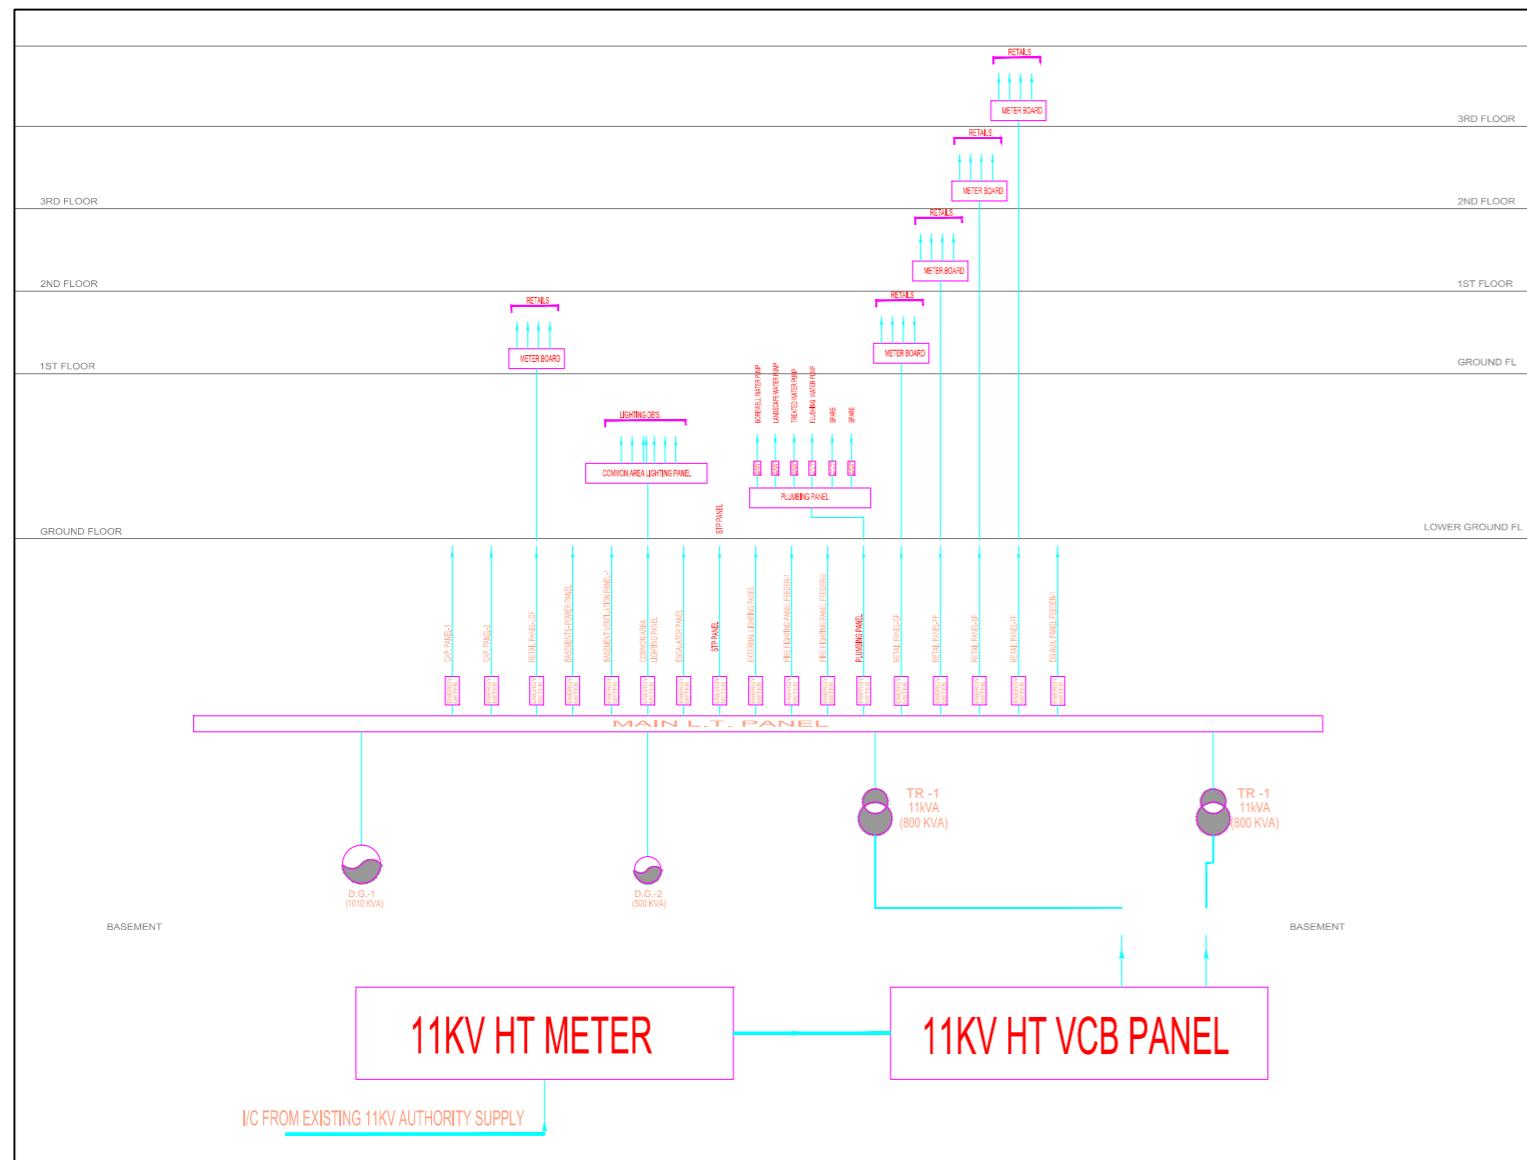

**SINGLE LINE DIAGRAM**

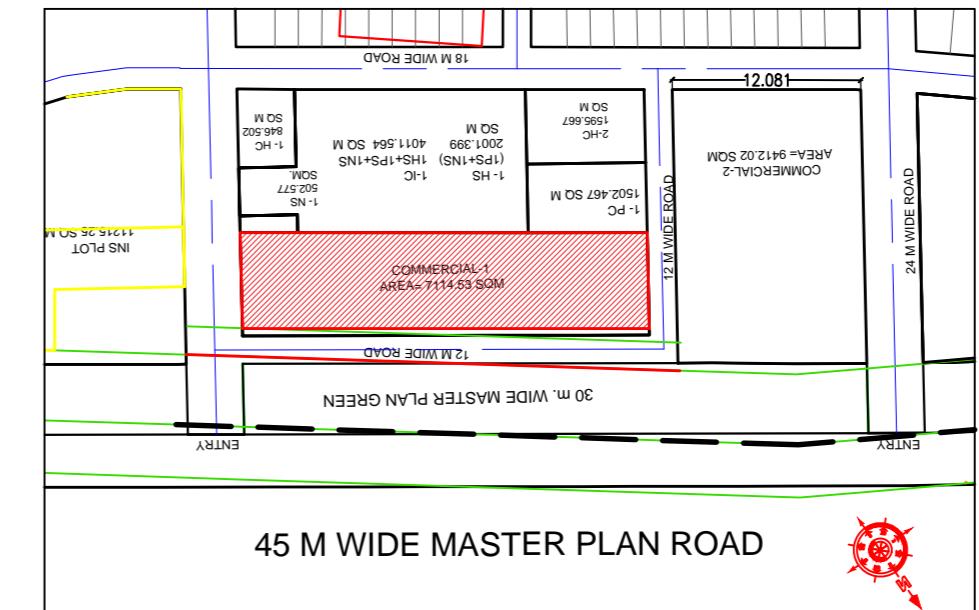

**KEY PLAN**

**PROJECT**  
PROPOSED COMMERCIAL COMPLEX "FAMILY HUB" AT PLOT NO.-COMMERCIAL-1, ADITYA WORLD CITY, INTEGRATED TOWNSHIP AT KHASRA NO. 1761, 1762, 1764, 1832 & 1833 VILLAGE - SHAHPUR BAMBHETA, PARGANA DASNA, TEHSIL & DISTRICT GHAZIABAD, UTTAR PRADESH-201002

**OWNER**  
M/S AU REAL ESTATE SERVICES PRIVATE LIMITED,  
10, NEW RAJDHANI ENCLAVE, VIKAS MARG, DELHI-110092

**ARCHITECT'S SEAL** **OWNER'S SEAL**

**ARCHITECT**

**modarchindia**  
architects interior designers & planners  
studio: 1st floor, b-99, sector-63, noida -201301, u.p.  
phone: 0120-4206253, email: amitgang4@hotmail.com  
website: www.modarchindia.com

Drawing Title	North
ELECTRICAL LAYOUT	
Checked by <input type="text"/> MANISH TIWARI	Date <input type="text"/>
Drawn by <input type="text"/> LOKESH SHARMA	Scale <input type="text"/> 1:200
Drawing No. <input type="text"/> MA - AGH - SANCTION	01