



# LEGENDS :-

S. NO.	SYMBOL	SPECIFICATION	Nos.
1.		70W LED STREET LIGHT (POLE HT.-6 MTR.)	22
2.		TRANSFORMER	01
3.		ELECTRICAL PANEL ROOM	01
4.		DISTRIBUTED GENERATION	01

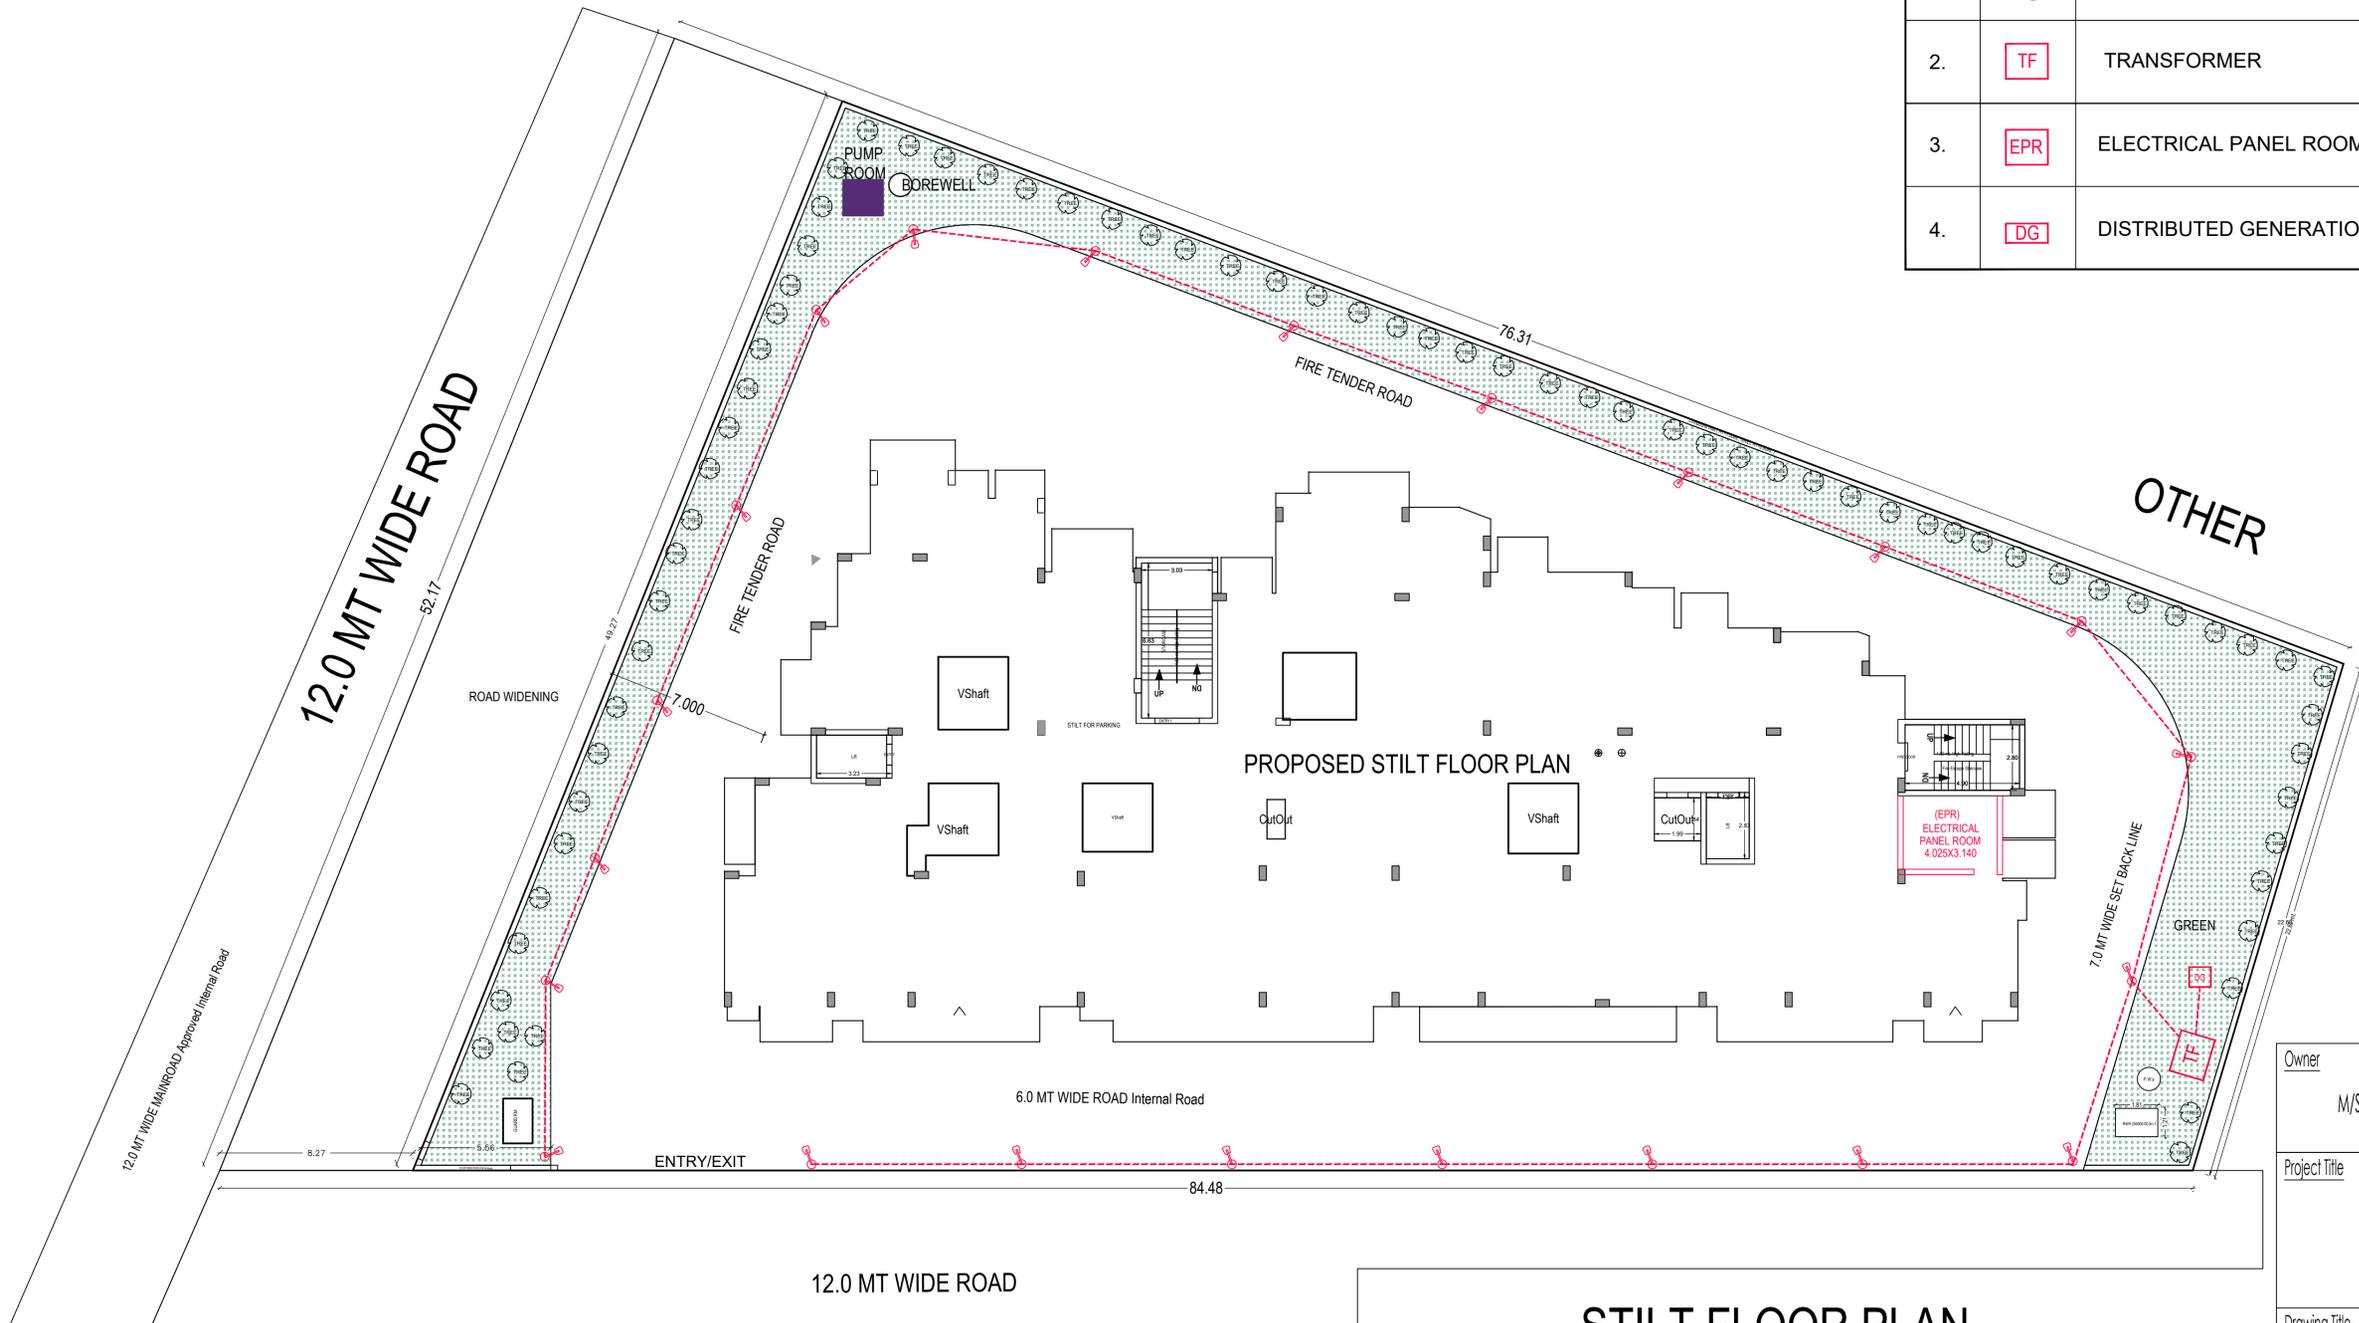

## STILT FLOOR PLAN

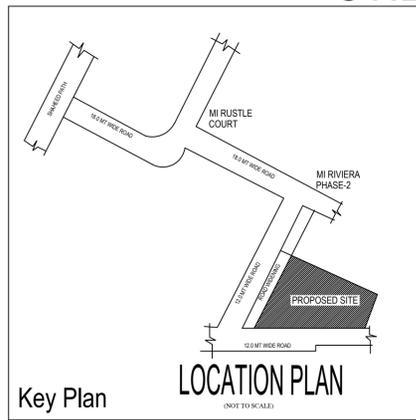

Owner		
M/S. OPPORTUNE ASSOCIATES PVT LTD & OTHERS		
Project Title		
RESIDENTIAL GROUP HOUSING BUILDING PLAN FOR AT KHASRA NO- 404 & 406 AT VILLAGE - BAGHAMAU, TEHSIL-SADAR, LUCKNOW [U.P.]		
Drawing Title		
ELECTRICAL PLAN		
Status: COMPLETION DRAWING		
OWNER'S SIGN		ARCHITECT'S SIGN
Date:	Scale:	Drawing No.
	1:500	
CONSULTANTS :-		
<b>RAGHAVA ARCHITECTS</b> (Architecture-Structure- Interiors -Values-Vastu)		
PLOT NO - CS-9, SECOND FLOOR, COMMERCIAL MARKET GYAN KHAND-II, INDIRAPURAM, GHAZIABAD (UP) INDIA (NEAR ST. THOMAS SCHOOL)		
OFFICE NO - 717, PARSYNATH PLANET PLAZA, PLOT NO-TCG-8/8 & 9/9, VIBHUTI KHAND, GOMTI NAGAR, LUCKNOW [U.P.]		
E mail - raghavaarchitects@gmail.com, Website- www.raghavaarchitects.com Mob - 9810379715, 9891515961, 9891146128		