


**EARTHING CHART**

S.NO.	TYPE OF EARTH STATION	QTY.	STRIP SIZE IN MM	PURPOSE
1)	CU. PLATE ELECTRODE EARTH PIT	3	50 X 6 C.U.	TRANSFORMER NEUTRAL (2500 KVA)
2)	G.I. PLATE ELECTRODE EARTH PIT	3	50 X 6 G.I.	TRANSFORMER BODY (2500 KVA)
3)	CU. PLATE ELECTRODE EARTH PIT	2	40 X 3 C.U.	DG-1 NEUTRAL
4)	CU. PLATE ELECTRODE EARTH PIT	2	40 X 3 C.U.	DG-2 NEUTRAL
5)	CU. PLATE ELECTRODE EARTH PIT	2	25 X 6 C.U.	DG-3 NEUTRAL
6)	G.I. PLATE ELECTRODE EARTH PIT	2	25 X 6 G.I.	DG-1 BODY (630 KVA)
7)	G.I. PLATE ELECTRODE EARTH PIT	2	25 X 6 G.I.	DG-2 & 3 BODY
8)	G.I. PLATE ELECTRODE EARTH PIT	2	50 X 6 G.I.	L.T. PANEL BODY
9)	G.I. PLATE ELECTRODE EARTH PIT	2	50 X 6 G.I.	ALL METERING PANELS
10)	G.I. PLATE ELECTRODE EARTH PIT	2	50 X 6 G.I.	H.T. PANEL BODY
11)	CU. PLATE ELECTRODE EARTH PIT	2	8 SWG C.U. WIRE	EACH LIFT (18NOS)
12)	CU. PLATE ELECTRODE EARTH PIT	2	8 SWG C.U. WIRE	UPS/INVERTOR NEUTRAL
13)	CU. PLATE ELECTRODE EARTH PIT	3	40 X 3 C.U.	SOLAR
14)	CU. PLATE ELECTRODE EARTH PIT	2	40 X 3 C.U.	LIGHTNING ARRESTER

**LEGEND SHEET**

SYMBOL	TYPE
[Symbol]	NEUTRAL EARTH Cu
[Symbol]	BODY EARTH Cu
[Symbol]	BODY EARTH GI
[Symbol]	ELECTRICAL M.H. SIZE 1200X900MM
[Symbol]	ELECTRICAL M.H. SIZE 1500X900MM
[Symbol]	ELECTRICAL M.H. SIZE 1500X1500MM
[Symbol]	E.M.H. SIZE 1800X1800MM
[Symbol]	ELEC HUME PIPE 300 MM DIA
[Symbol]	DWC HOPE PIPE 100MM DIA
[Symbol]	6 MTR. 1/2" Y - STREET LIGHT POLE SINGLE BRACKET
[Symbol]	6MTR Y - STREET LIGHT POLE DOUBLE BRACKET

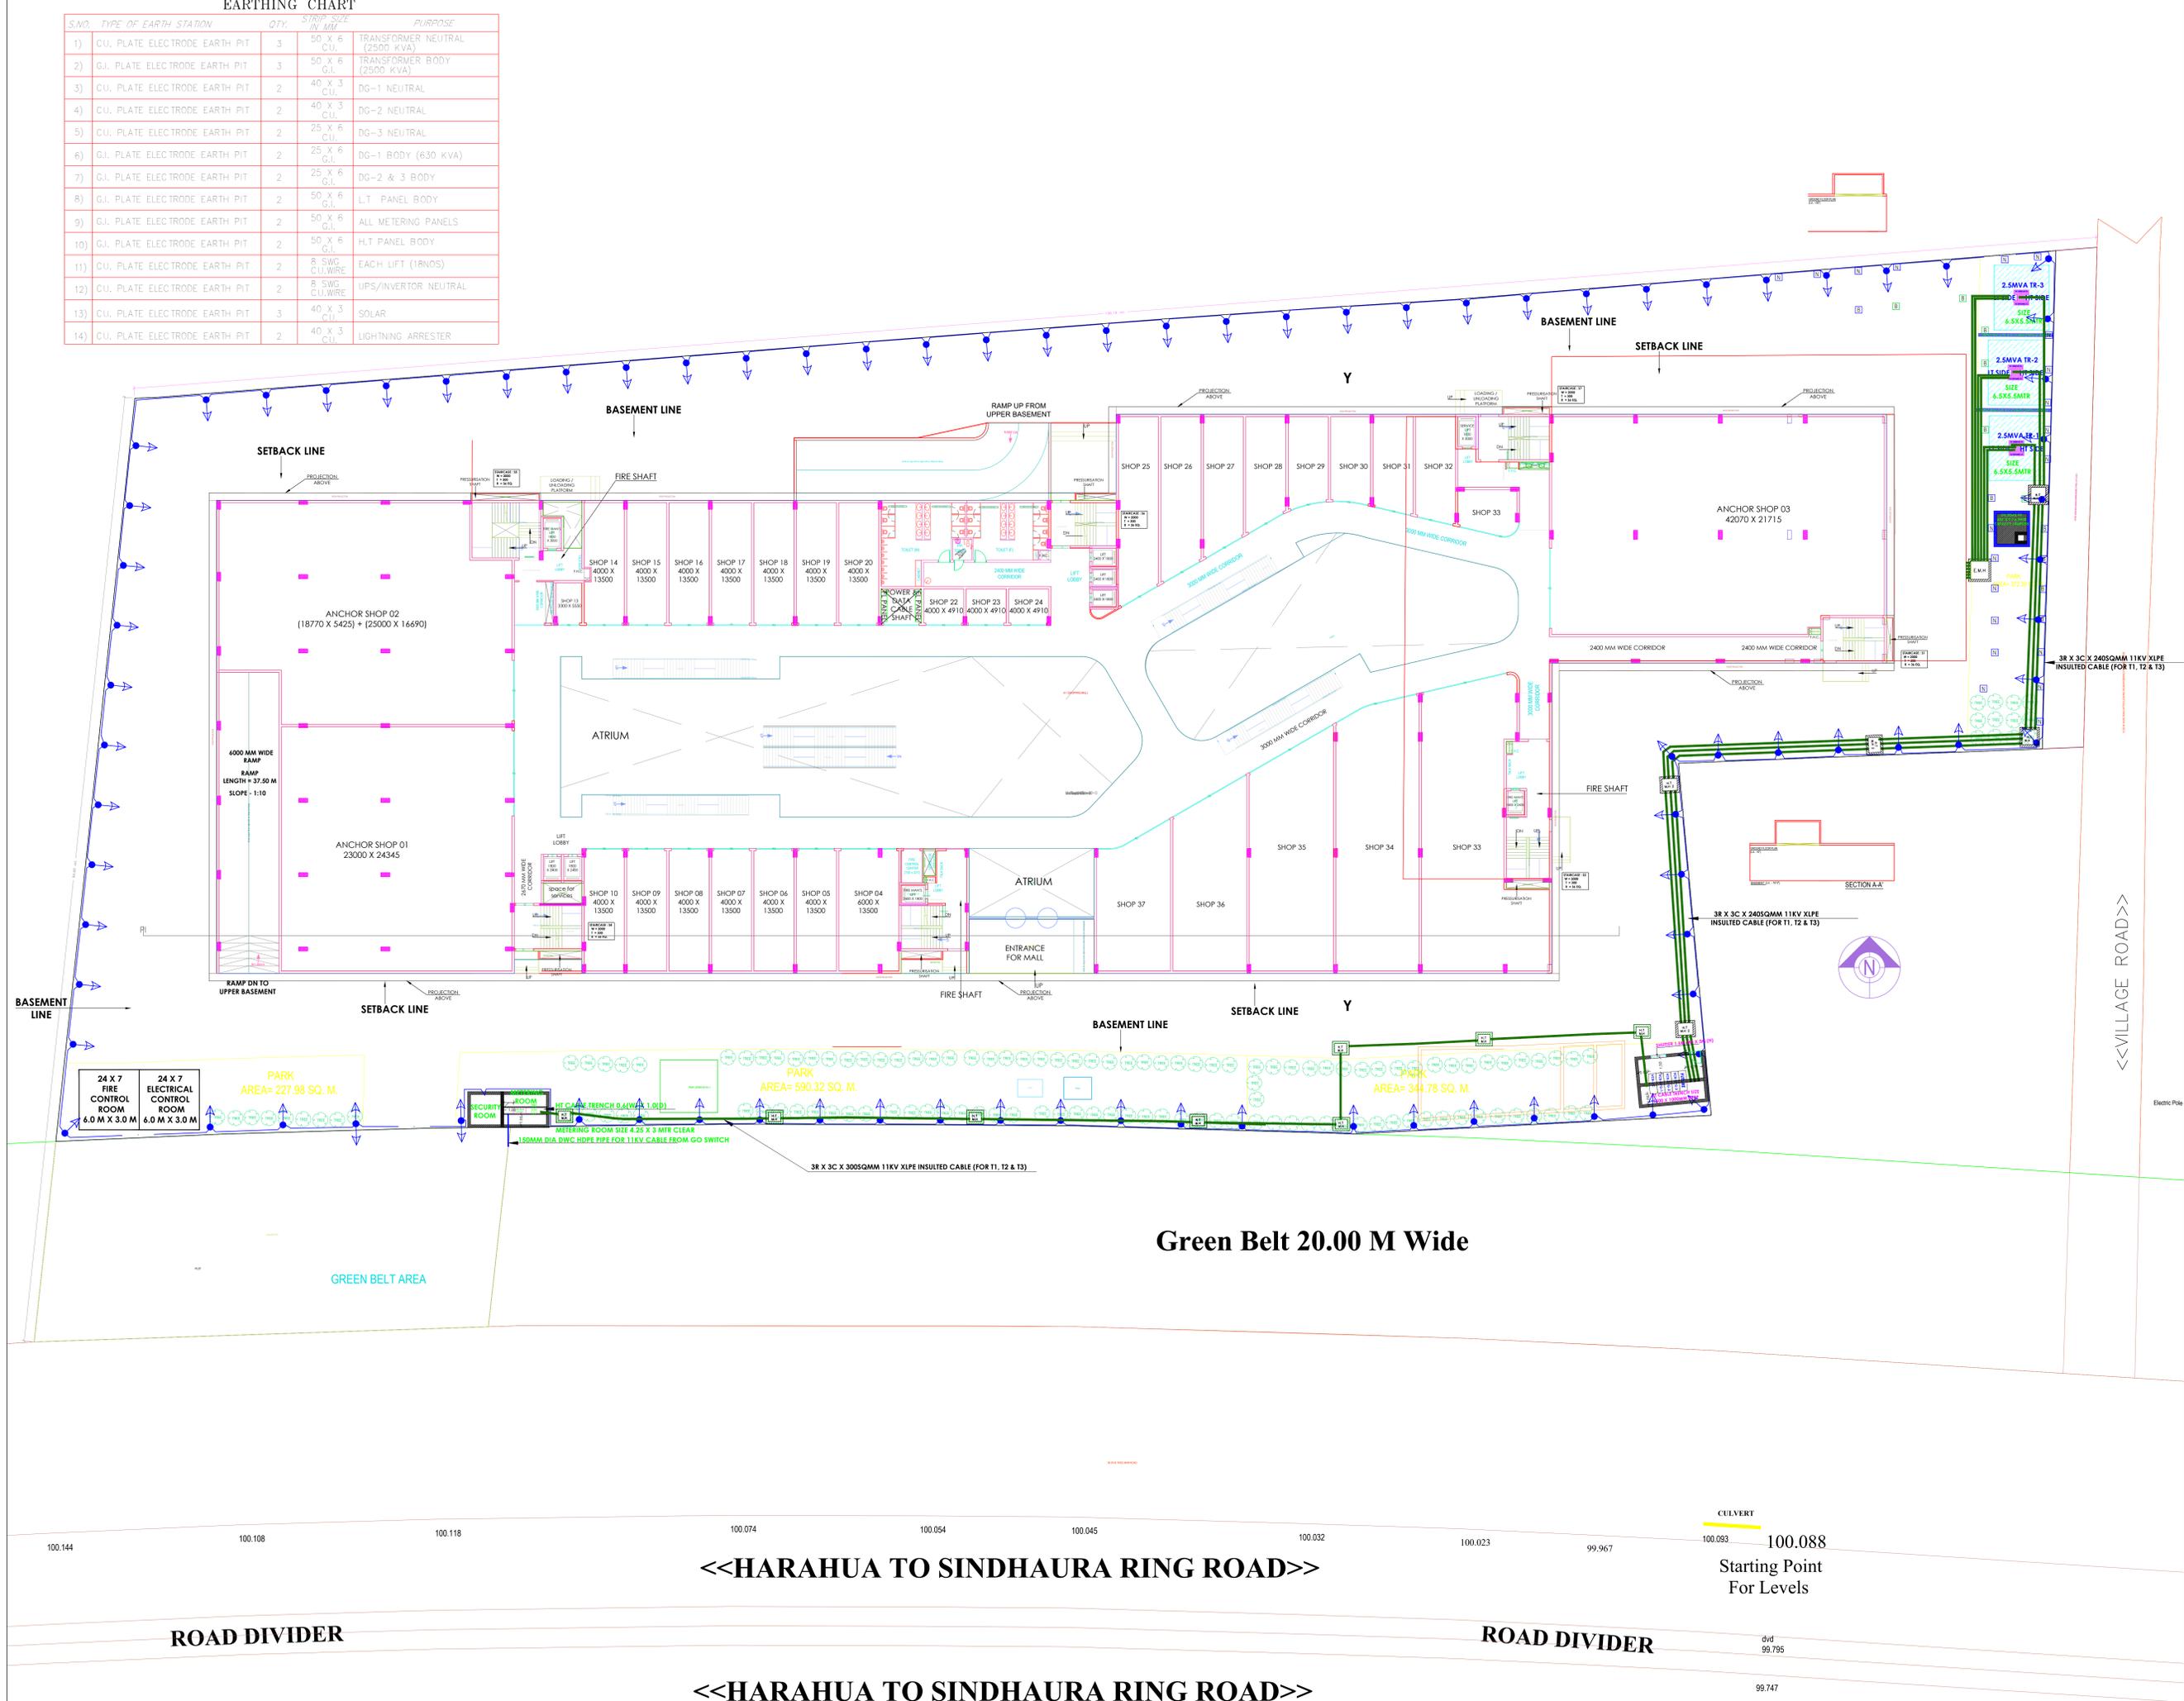

**SIGNATURE**

**DATE** 07-03-2025 (BASE DRAWING)

**DRAWN BY** BALDEEP SINGH

**SHEET-A1** SCALE - NTS

**CHECKED BY** ANUJ

**REVISION** R0

**DWG NO** AMB/642/EL-03

**NAME OF THE WORK** PROPOSED SHOPPING MALL AT BABATPUR

**PURPOSE OF DRAWING** SITE FLOOR ELECTRICAL LAYOUT PLAN


**PLUM/FIRE CONSULTANT:** PDS CONSULTANTS  
 NEW DELHI-110017  
 PLUM/FIRE - D.P.S.Rawal/9810328084/916028084

**ARCHITECT:** DCA  
 DHIRAJ KAPOOR & ASSOCIATES  
 MOB. # 9935687000 & 9935532800  
 OFFICE PH NO. 0542-2220498

**HVAC & ELECTRICAL CONSULTANT:** Ambience

#204, 2ND FLOOR, S.C.O. 7, SECTOR-7C  
 MADHYA MARG, CHANDIGARH - 160019  
 CONTACT: 0172-4812238, 9915144443  
 www.ambienceconsultant.com



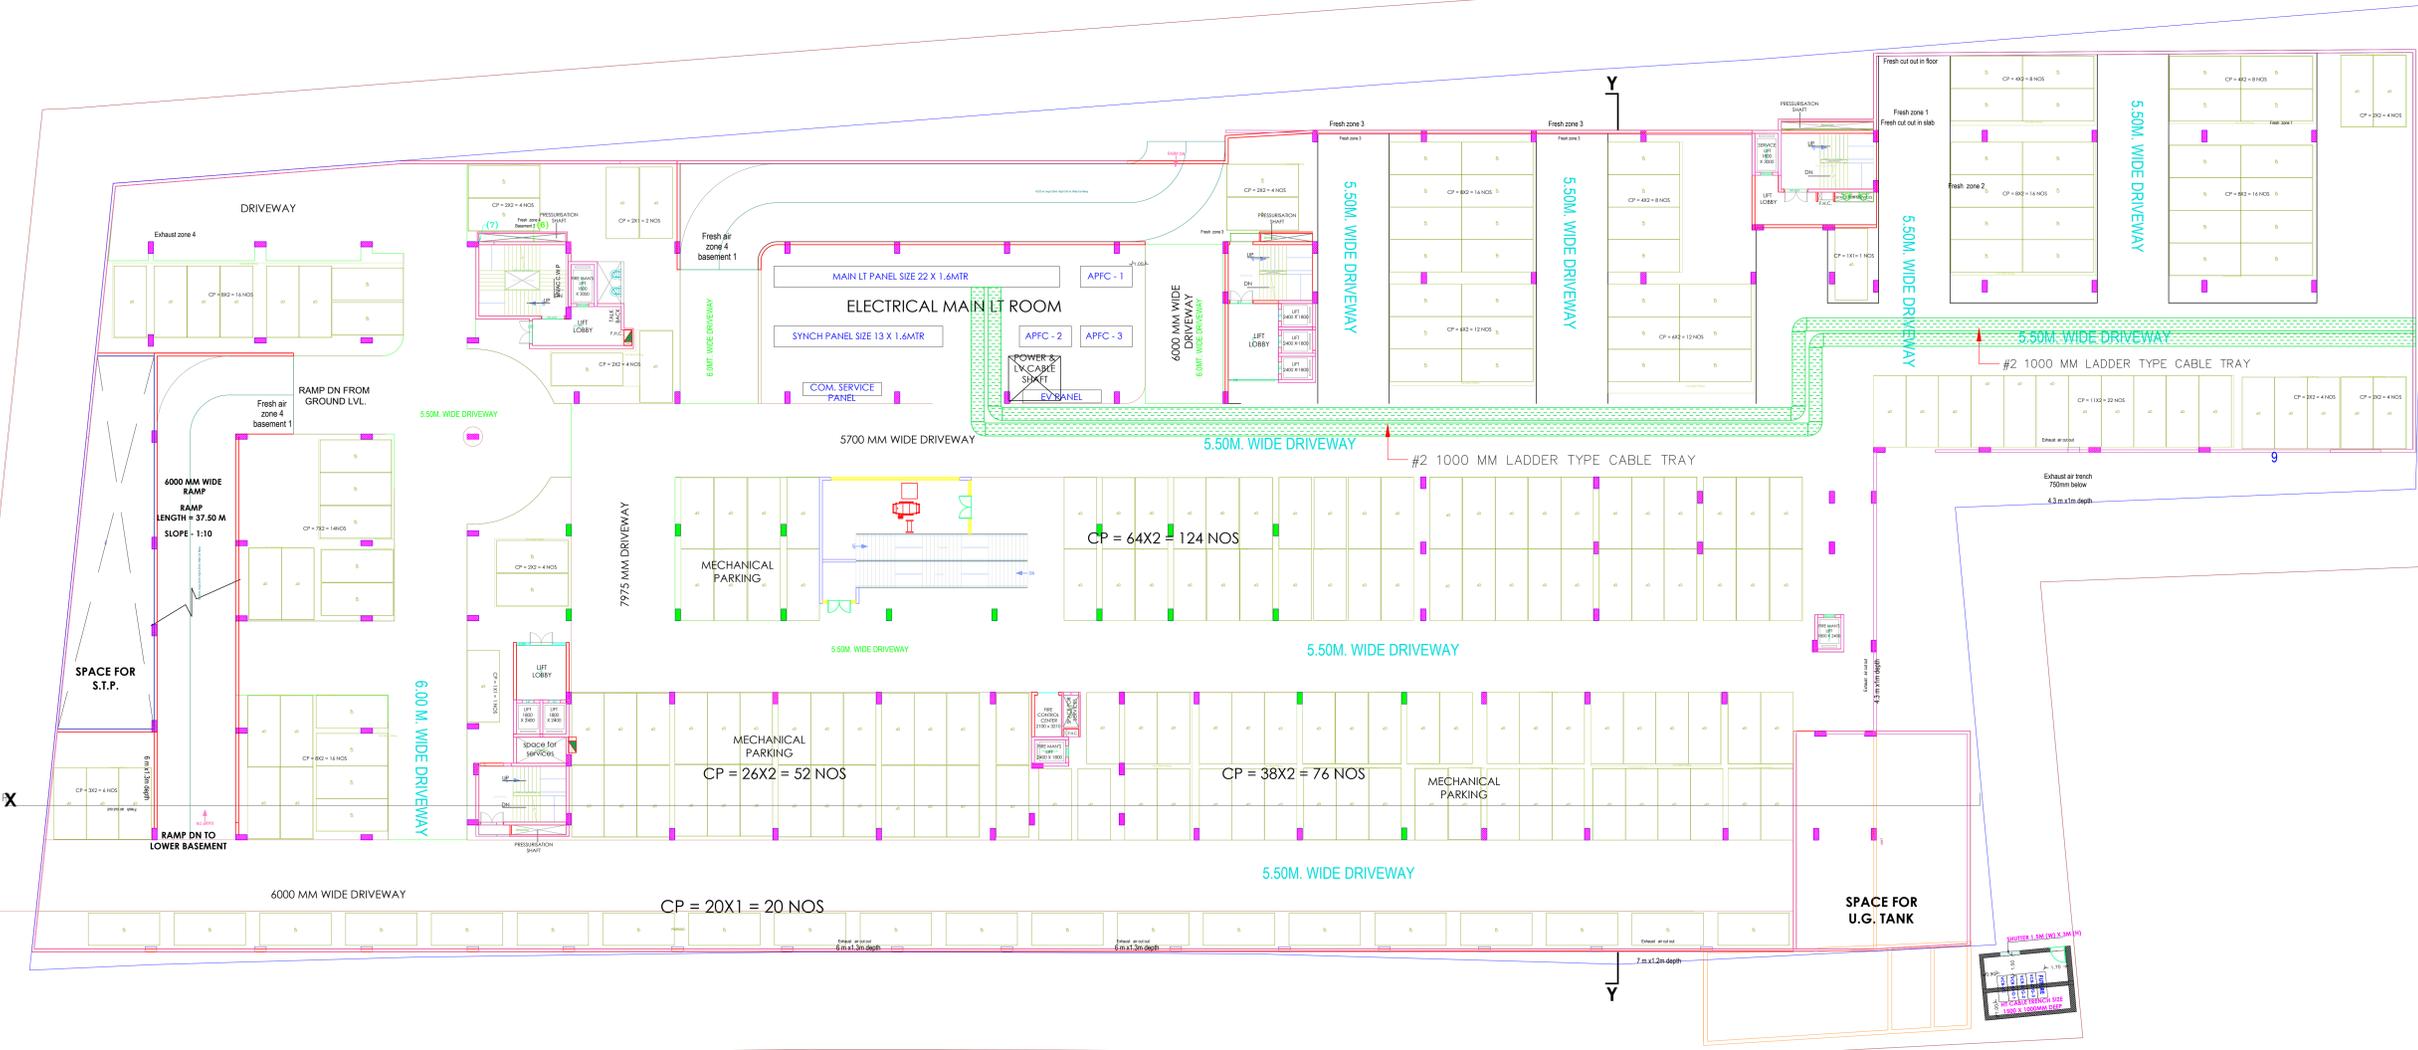

TOTAL PARKING IN BASEMENT 1 = 466 NOS.

**LEGEND SHEET**

SYMBOL	TYPE
(E)	NEUTRAL EARTH Cu
(B)	BODY EARTH Cu
(G)	BODY EARTH G
(E.M.H.)	ELECTRICAL M.H. SIZE 1200X900MM
(E.M.H.)	ELECTRICAL M.H. SIZE 1500X900MM
(E.M.H.)	ELECTRICAL M.H. SIZE 1500X1500MM
(E.M.H.)	E.M.H. SIZE 1800X1800MM
(E.M.H.)	ELEC HOME PIPE 300 MM DIA
(E.M.H.)	DWC HOME PIPE 100MM DIA
(E.M.H.)	6 MTR. 1/2" Y - STREET LIGHT POLE SINGLE BRACKET
(E.M.H.)	6MTR. Y - STREET LIGHT POLE DOUBLE BRACKET

**EARTHING CHART**

NO.	TYPE OF EARTHING	LOCATION	SIZE	DEPTH	REMARKS
1	NEUTRAL EARTH	CP = 20X1	300	1.0	NEUTRAL EARTH
2	BODY EARTH	CP = 26X2	300	1.0	BODY EARTH
3	BODY EARTH	CP = 38X2	300	1.0	BODY EARTH
4	BODY EARTH	CP = 64X2	300	1.0	BODY EARTH
5	NEUTRAL EARTH	CP = 114X1	300	1.0	NEUTRAL EARTH
6	BODY EARTH	CP = 182X1	300	1.0	BODY EARTH
7	BODY EARTH	CP = 182X2	300	1.0	BODY EARTH
8	BODY EARTH	CP = 182X3	300	1.0	BODY EARTH
9	BODY EARTH	CP = 182X4	300	1.0	BODY EARTH
10	BODY EARTH	CP = 182X5	300	1.0	BODY EARTH
11	BODY EARTH	CP = 182X6	300	1.0	BODY EARTH
12	BODY EARTH	CP = 182X7	300	1.0	BODY EARTH
13	BODY EARTH	CP = 182X8	300	1.0	BODY EARTH
14	BODY EARTH	CP = 182X9	300	1.0	BODY EARTH
15	BODY EARTH	CP = 182X10	300	1.0	BODY EARTH
16	BODY EARTH	CP = 182X11	300	1.0	BODY EARTH
17	BODY EARTH	CP = 182X12	300	1.0	BODY EARTH
18	BODY EARTH	CP = 182X13	300	1.0	BODY EARTH
19	BODY EARTH	CP = 182X14	300	1.0	BODY EARTH
20	BODY EARTH	CP = 182X15	300	1.0	BODY EARTH
21	BODY EARTH	CP = 182X16	300	1.0	BODY EARTH
22	BODY EARTH	CP = 182X17	300	1.0	BODY EARTH
23	BODY EARTH	CP = 182X18	300	1.0	BODY EARTH
24	BODY EARTH	CP = 182X19	300	1.0	BODY EARTH
25	BODY EARTH	CP = 182X20	300	1.0	BODY EARTH
26	BODY EARTH	CP = 182X21	300	1.0	BODY EARTH
27	BODY EARTH	CP = 182X22	300	1.0	BODY EARTH
28	BODY EARTH	CP = 182X23	300	1.0	BODY EARTH
29	BODY EARTH	CP = 182X24	300	1.0	BODY EARTH
30	BODY EARTH	CP = 182X25	300	1.0	BODY EARTH

**SIGNATURE**



DATE	07-03-2025 (BASE DRAWING)
DRAWN BY	BALDEEP SINGH
SHEET - A1	SCALE - NTS
CHECKED BY	ANUJ
REVISION	RO
DWG NO	AMB/642/EL-02


NAME OF THE WORK  
**PROPOSED SHOPPING MALL AT BABATPUR**

PURPOSE OF DRAWING  
**BASEMENT 1  
 ELECTRICAL LAYOUT PLAN**

PLUM/FIRE CONSULTANT:  
**PDS CONSULTANTS**  
 NEW DELHI-110017  
 PLUM/FIRE - D.P.S.Royal 9810228084, 9116028084

ARCHITECT  
  
 DHIRAJ KAPOOR & ASSOCIATES  
 MOB # 9935687000 & 9935528000  
 OFFICE PH NO. 0542-2220498

HVAC & ELECTRICAL CONSULTANT  
  
 #204, 2ND FLOOR, S.C.O. 7, SECTOR-7C  
 MADHYA MARC, CHANDIGARH - 160019  
 CONTACT: 0172-4811238, 9915154443  
 www.ambienceconsultant.com

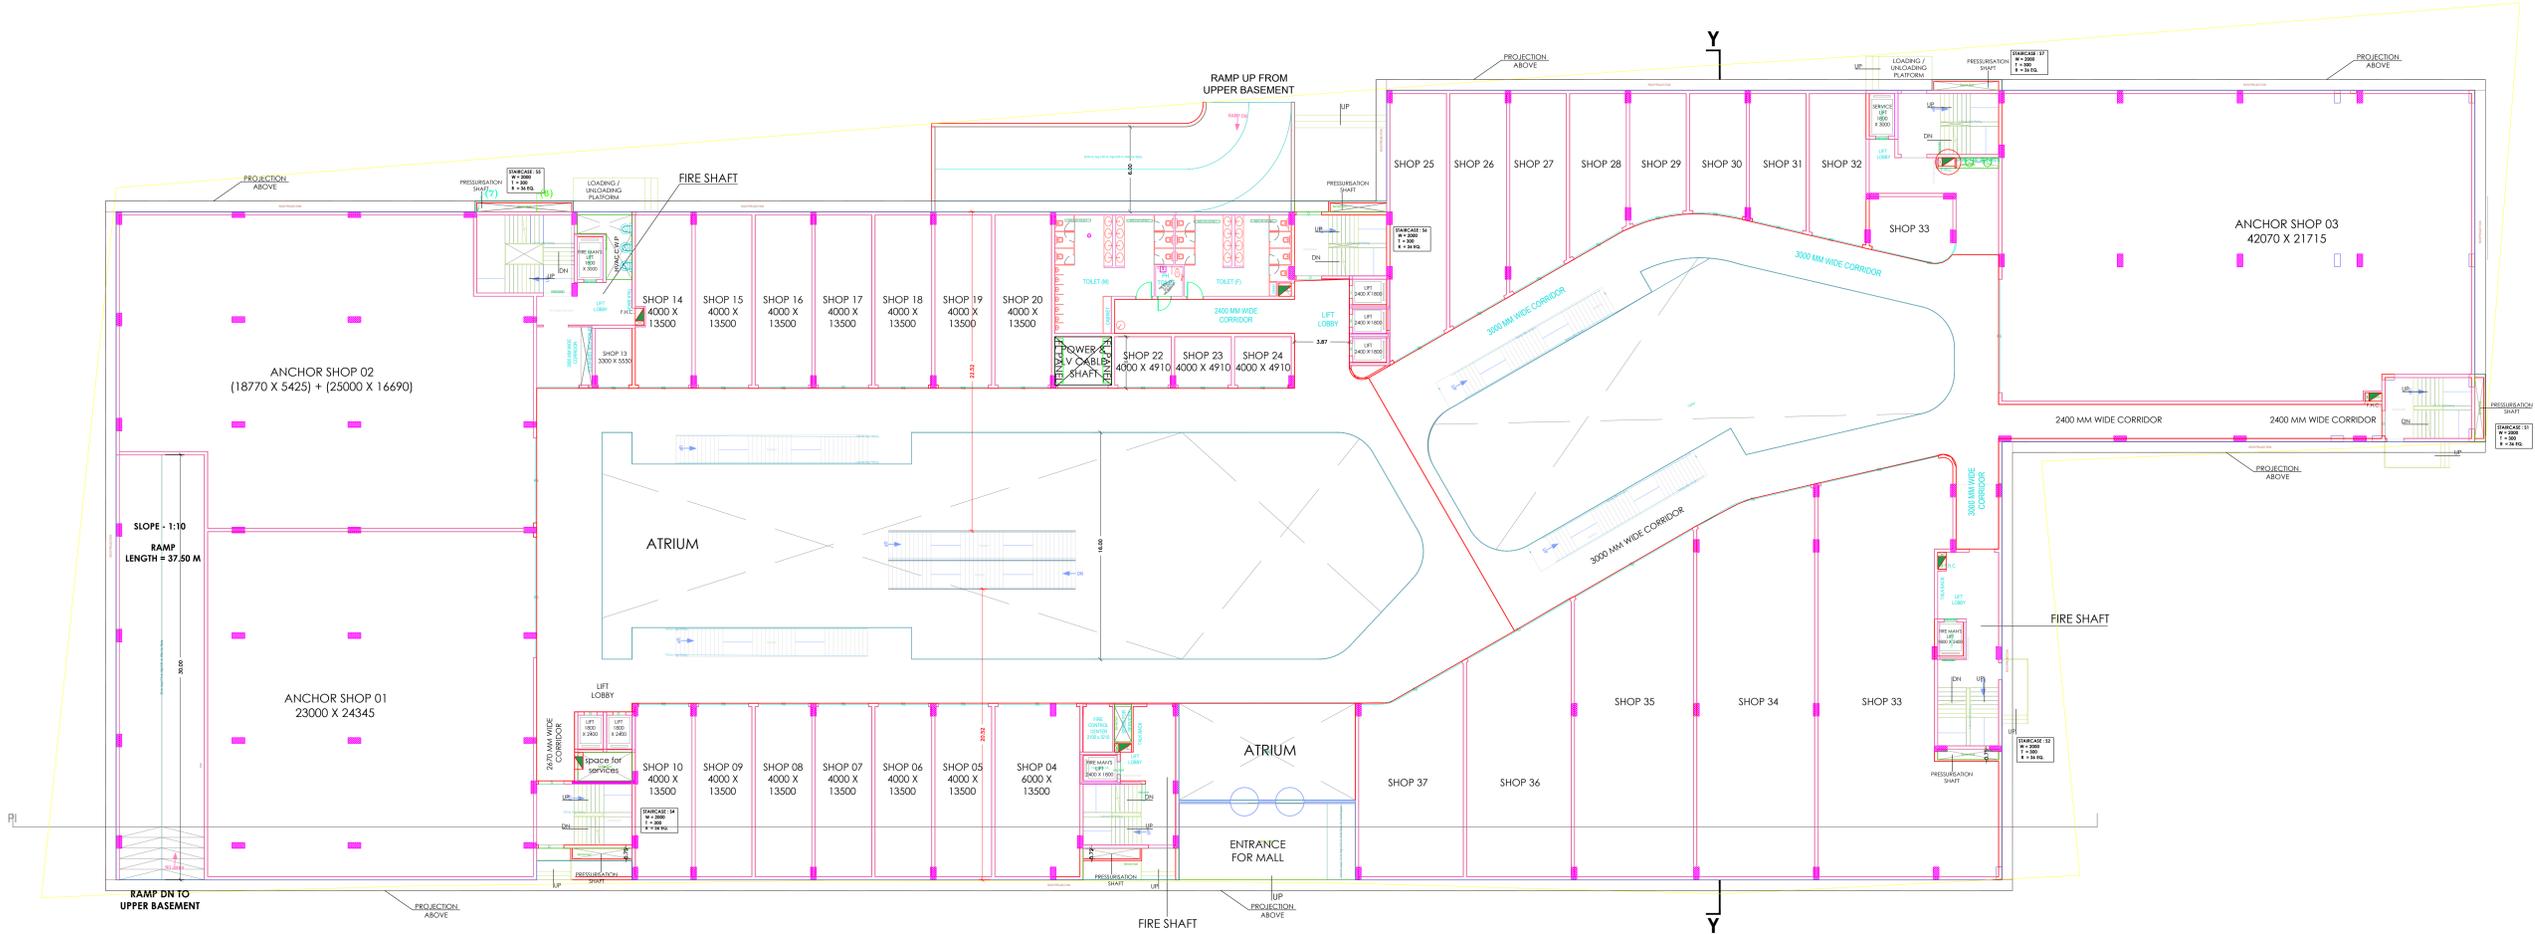

GROUND FLOOR PLAN

**LEGEND SHEET**

SYMBOL	TYPE
	NEUTRAL EARTH Cu
	BODY EARTH Cu
	BODY EARTH Gi
	ELECTRICAL M.H. SIZE 1200x900MM
	ELECTRICAL M.H. SIZE 1500x900MM
	ELECTRICAL M.H. SIZE 1500x1500MM
	E.M.H. SIZE 1800x1800MM
	ELEC HUME PIPE 300 MM DIA
	DWC HDPE PIPE 100MM DIA
	6 MTR 1/2 Y - STREET LIGHT POLE SINGLE BRACKET
	6MTR Y - STREET LIGHT POLE DOUBLE BRACKET

**EARTHING CHART**

NO.	TYPE	SIZE	DEPTH	LOCATION
01	PLATE	400 X 400	100	SHOP 01
02	PLATE	400 X 400	100	SHOP 02
03	PLATE	400 X 400	100	SHOP 03
04	PLATE	400 X 400	100	SHOP 04
05	PLATE	400 X 400	100	SHOP 05
06	PLATE	400 X 400	100	SHOP 06
07	PLATE	400 X 400	100	SHOP 07
08	PLATE	400 X 400	100	SHOP 08
09	PLATE	400 X 400	100	SHOP 09
10	PLATE	400 X 400	100	SHOP 10
11	PLATE	400 X 400	100	SHOP 11
12	PLATE	400 X 400	100	SHOP 12
13	PLATE	400 X 400	100	SHOP 13
14	PLATE	400 X 400	100	SHOP 14
15	PLATE	400 X 400	100	SHOP 15
16	PLATE	400 X 400	100	SHOP 16
17	PLATE	400 X 400	100	SHOP 17
18	PLATE	400 X 400	100	SHOP 18
19	PLATE	400 X 400	100	SHOP 19
20	PLATE	400 X 400	100	SHOP 20
21	PLATE	400 X 400	100	SHOP 21
22	PLATE	400 X 400	100	SHOP 22
23	PLATE	400 X 400	100	SHOP 23
24	PLATE	400 X 400	100	SHOP 24
25	PLATE	400 X 400	100	SHOP 25
26	PLATE	400 X 400	100	SHOP 26
27	PLATE	400 X 400	100	SHOP 27
28	PLATE	400 X 400	100	SHOP 28
29	PLATE	400 X 400	100	SHOP 29
30	PLATE	400 X 400	100	SHOP 30
31	PLATE	400 X 400	100	SHOP 31
32	PLATE	400 X 400	100	SHOP 32
33	PLATE	400 X 400	100	SHOP 33
34	PLATE	400 X 400	100	SHOP 34
35	PLATE	400 X 400	100	SHOP 35
36	PLATE	400 X 400	100	SHOP 36
37	PLATE	400 X 400	100	SHOP 37
38	PLATE	400 X 400	100	ANCHOR SHOP 01
39	PLATE	400 X 400	100	ANCHOR SHOP 02
40	PLATE	400 X 400	100	ANCHOR SHOP 03



DATE	07-03-2025 (BASE DRAWING)
DRAWN BY	BALDEEP SINGH
SHEET - A1	SCALE - NTS
CHECKED BY	ANUJ
REVISION	RO
DWG NO	AMB/642/EL-04


NAME OF THE WORK  
**PROPOSED SHOPPING MALL AT BABATPUR**

PURPOSE OF DRAWING  
**GROUND FLOOR ELECTRICAL LAYOUT PLAN**

PLUM/FIRE CONSULTANT:  
**PDS CONSULTANTS**  
 NEW DELHI-110017  
 PLUM/FIRE - D.P.S.Royal/9810228084/911628084

ARCHITECT  
  
 DHIRAJ KAPOOR & ASSOCIATES  
 MOB. # 9935687000 & 9935532800  
 OFFICE PH. NO. 0542-2220498

HVAC & ELECTRICAL CONSULTANT  
  
 #204, 2ND FLOOR, S.C.O. 7, SECTOR-7C  
 MADHYA MARG, CHANDIGARH - 160019  
 CONTACT: 0172-4811238, 9915154443  
 www.ambienceconsultant.com

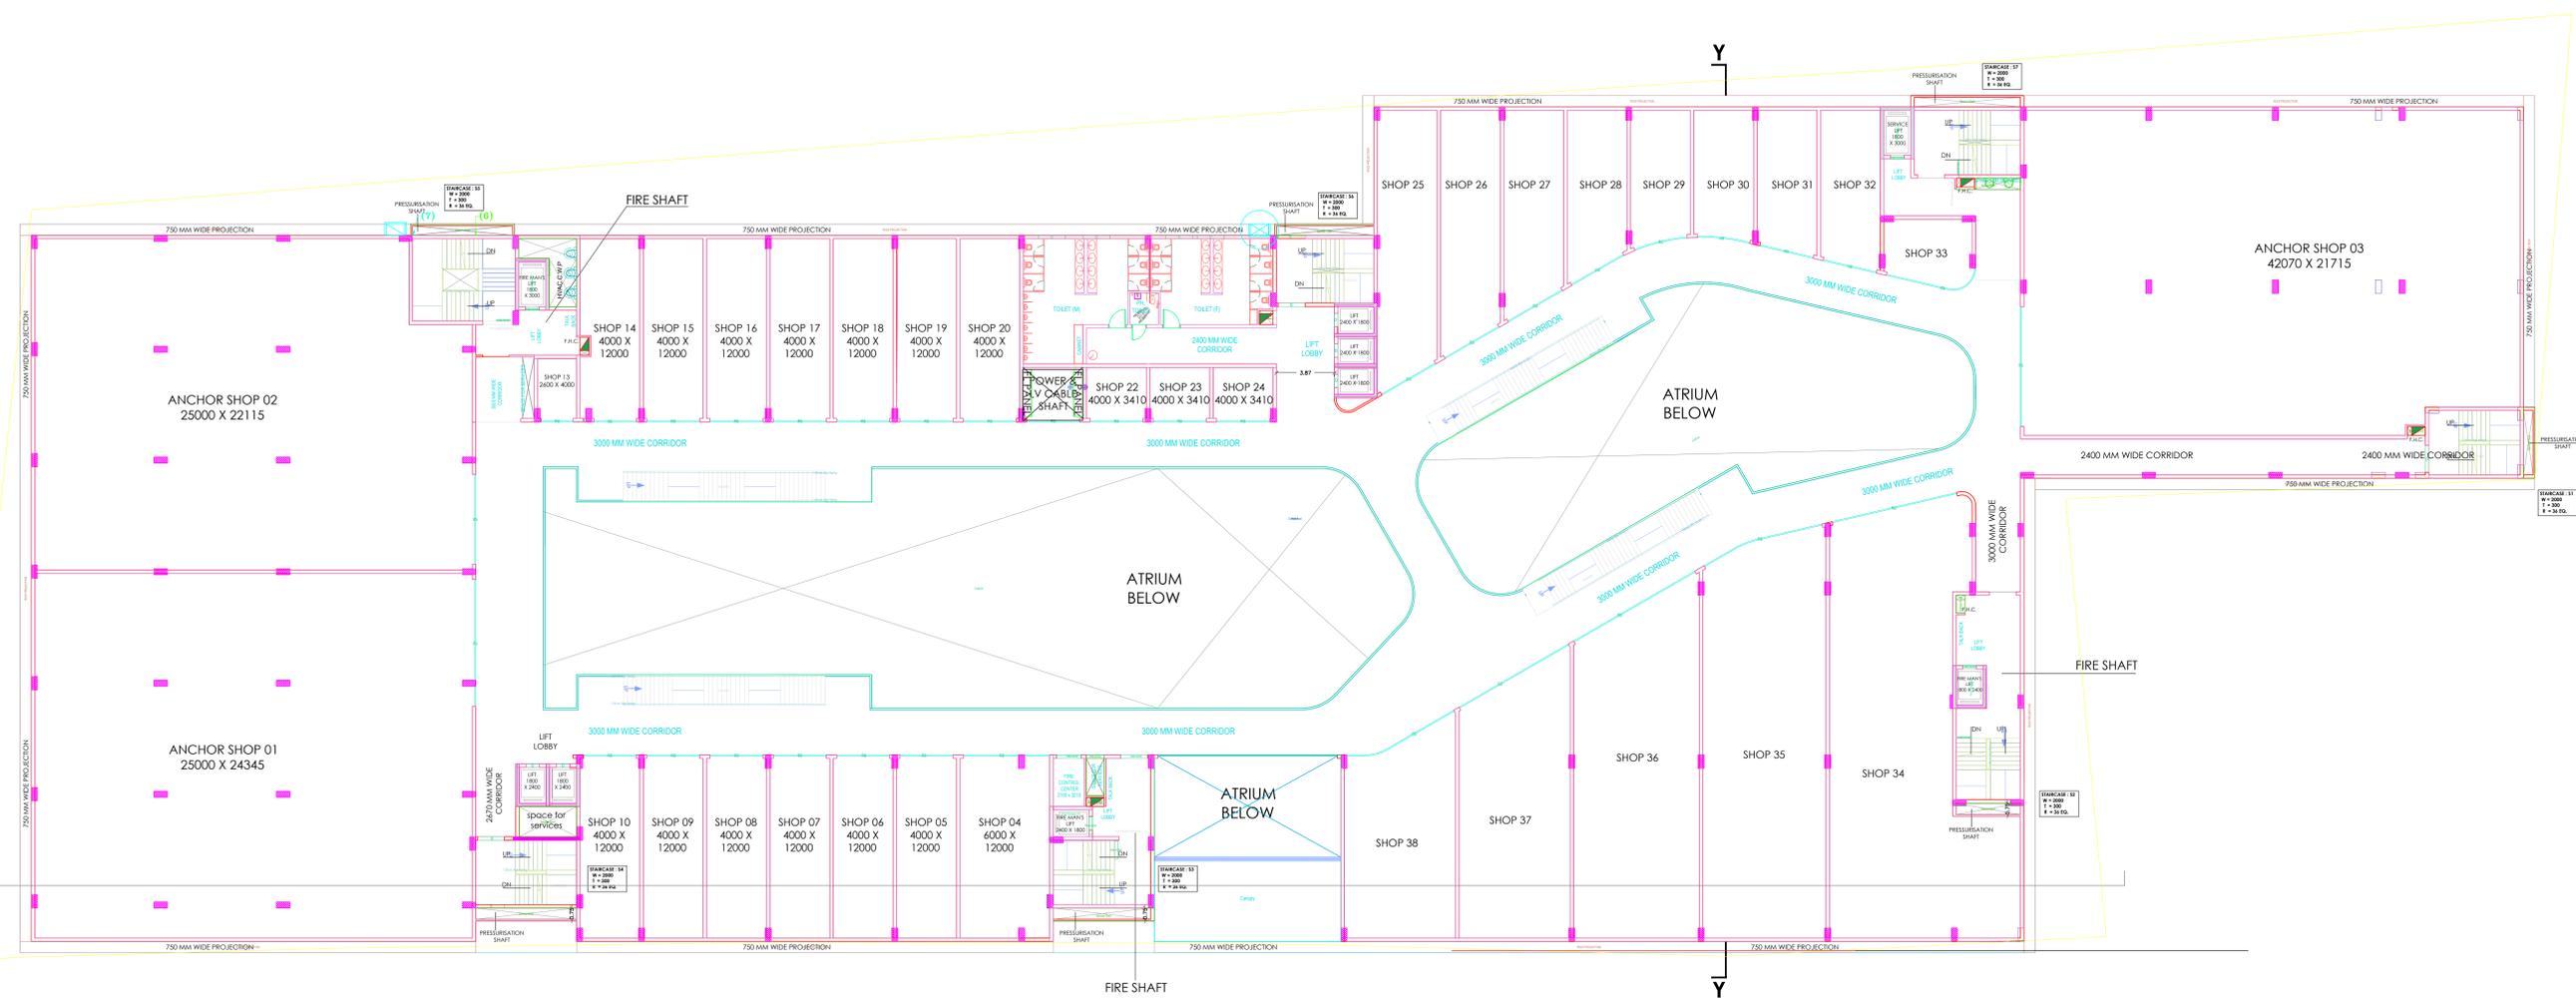

1ST FLOOR PLAN

TOTAL FAR AREA= 5850 SQ. M.

SYMBOL	TYPE
(N)	NEUTRAL EARTH Cu
(B)	BODY EARTH Cu
(E)	BODY EARTH GI
(M.H.)	ELECTRICAL M.H. SIZE 1200X900MM
(M.H.)	ELECTRICAL M.H. SIZE 1500X900MM
(M.H.)	ELECTRICAL M.H. SIZE 1500X1500MM
(E.M.H.)	E.M.H. SIZE 1800X1800MM
(—)	ELEC HUME PIPE 300 MM DIA
(—)	DWC HOPE PIPE 100MM DIA
(—)	6 MTR. 1/2" Y - STREET LIGHT POLE SINGLE BRACKET
(—)	6MTR Y - STREET LIGHT POLE DOUBLE BRACKET

EARTHING CHART			
NO.	DESCRIPTION	TYPE	STATUS
1	PLATE EARTHING	PLATE	PROVIDED
2	PLATE EARTHING	PLATE	PROVIDED
3	PLATE EARTHING	PLATE	PROVIDED
4	PLATE EARTHING	PLATE	PROVIDED
5	PLATE EARTHING	PLATE	PROVIDED
6	PLATE EARTHING	PLATE	PROVIDED
7	PLATE EARTHING	PLATE	PROVIDED
8	PLATE EARTHING	PLATE	PROVIDED
9	PLATE EARTHING	PLATE	PROVIDED
10	PLATE EARTHING	PLATE	PROVIDED
11	PLATE EARTHING	PLATE	PROVIDED
12	PLATE EARTHING	PLATE	PROVIDED
13	PLATE EARTHING	PLATE	PROVIDED
14	PLATE EARTHING	PLATE	PROVIDED
15	PLATE EARTHING	PLATE	PROVIDED
16	PLATE EARTHING	PLATE	PROVIDED
17	PLATE EARTHING	PLATE	PROVIDED
18	PLATE EARTHING	PLATE	PROVIDED
19	PLATE EARTHING	PLATE	PROVIDED
20	PLATE EARTHING	PLATE	PROVIDED
21	PLATE EARTHING	PLATE	PROVIDED
22	PLATE EARTHING	PLATE	PROVIDED
23	PLATE EARTHING	PLATE	PROVIDED
24	PLATE EARTHING	PLATE	PROVIDED
25	PLATE EARTHING	PLATE	PROVIDED
26	PLATE EARTHING	PLATE	PROVIDED
27	PLATE EARTHING	PLATE	PROVIDED
28	PLATE EARTHING	PLATE	PROVIDED
29	PLATE EARTHING	PLATE	PROVIDED
30	PLATE EARTHING	PLATE	PROVIDED
31	PLATE EARTHING	PLATE	PROVIDED
32	PLATE EARTHING	PLATE	PROVIDED
33	PLATE EARTHING	PLATE	PROVIDED
34	PLATE EARTHING	PLATE	PROVIDED
35	PLATE EARTHING	PLATE	PROVIDED
36	PLATE EARTHING	PLATE	PROVIDED
37	PLATE EARTHING	PLATE	PROVIDED
38	PLATE EARTHING	PLATE	PROVIDED



DATE	07-03-2025 (BASE DRAWING)
DRAWN BY	BALDEP SINGH
SHEET-NO	SCALE - NTS
CHECKED BY	ANUJ
REVISION	RO
DWG NO	AMB/642/EL-05
NAME OF THE WORK	


PROPOSED SHOPPING MALL AT BABATPUR

PURPOSE OF DRAWING  
FIRST FLOOR  
ELECTRICAL LAYOUT PLAN

PLUM/FIRE CONSULTANT:  
**PDS CONSULTANTS**  
NEW DELHI-110017  
PLUM/FIRE - D.P.S.Rawal/9810328084/916028084

ARCHITECT  
**DCA**  
DHIRAJ KAPOOR & ASSOCIATES  
MOB # 9935687000 & 9935532800  
OFFICE PH NO. 0542-2220498

HVAC & ELECTRICAL CONSULTANT  
**ambience**  
#204, 2ND FLOOR, S.C.O. 7, SECTOR-7C  
RAJYGA MARG, CHANDIGARH - 160019  
CONTACT : 0172-4611238, 9915144443  
www.ambienceconsultant.com

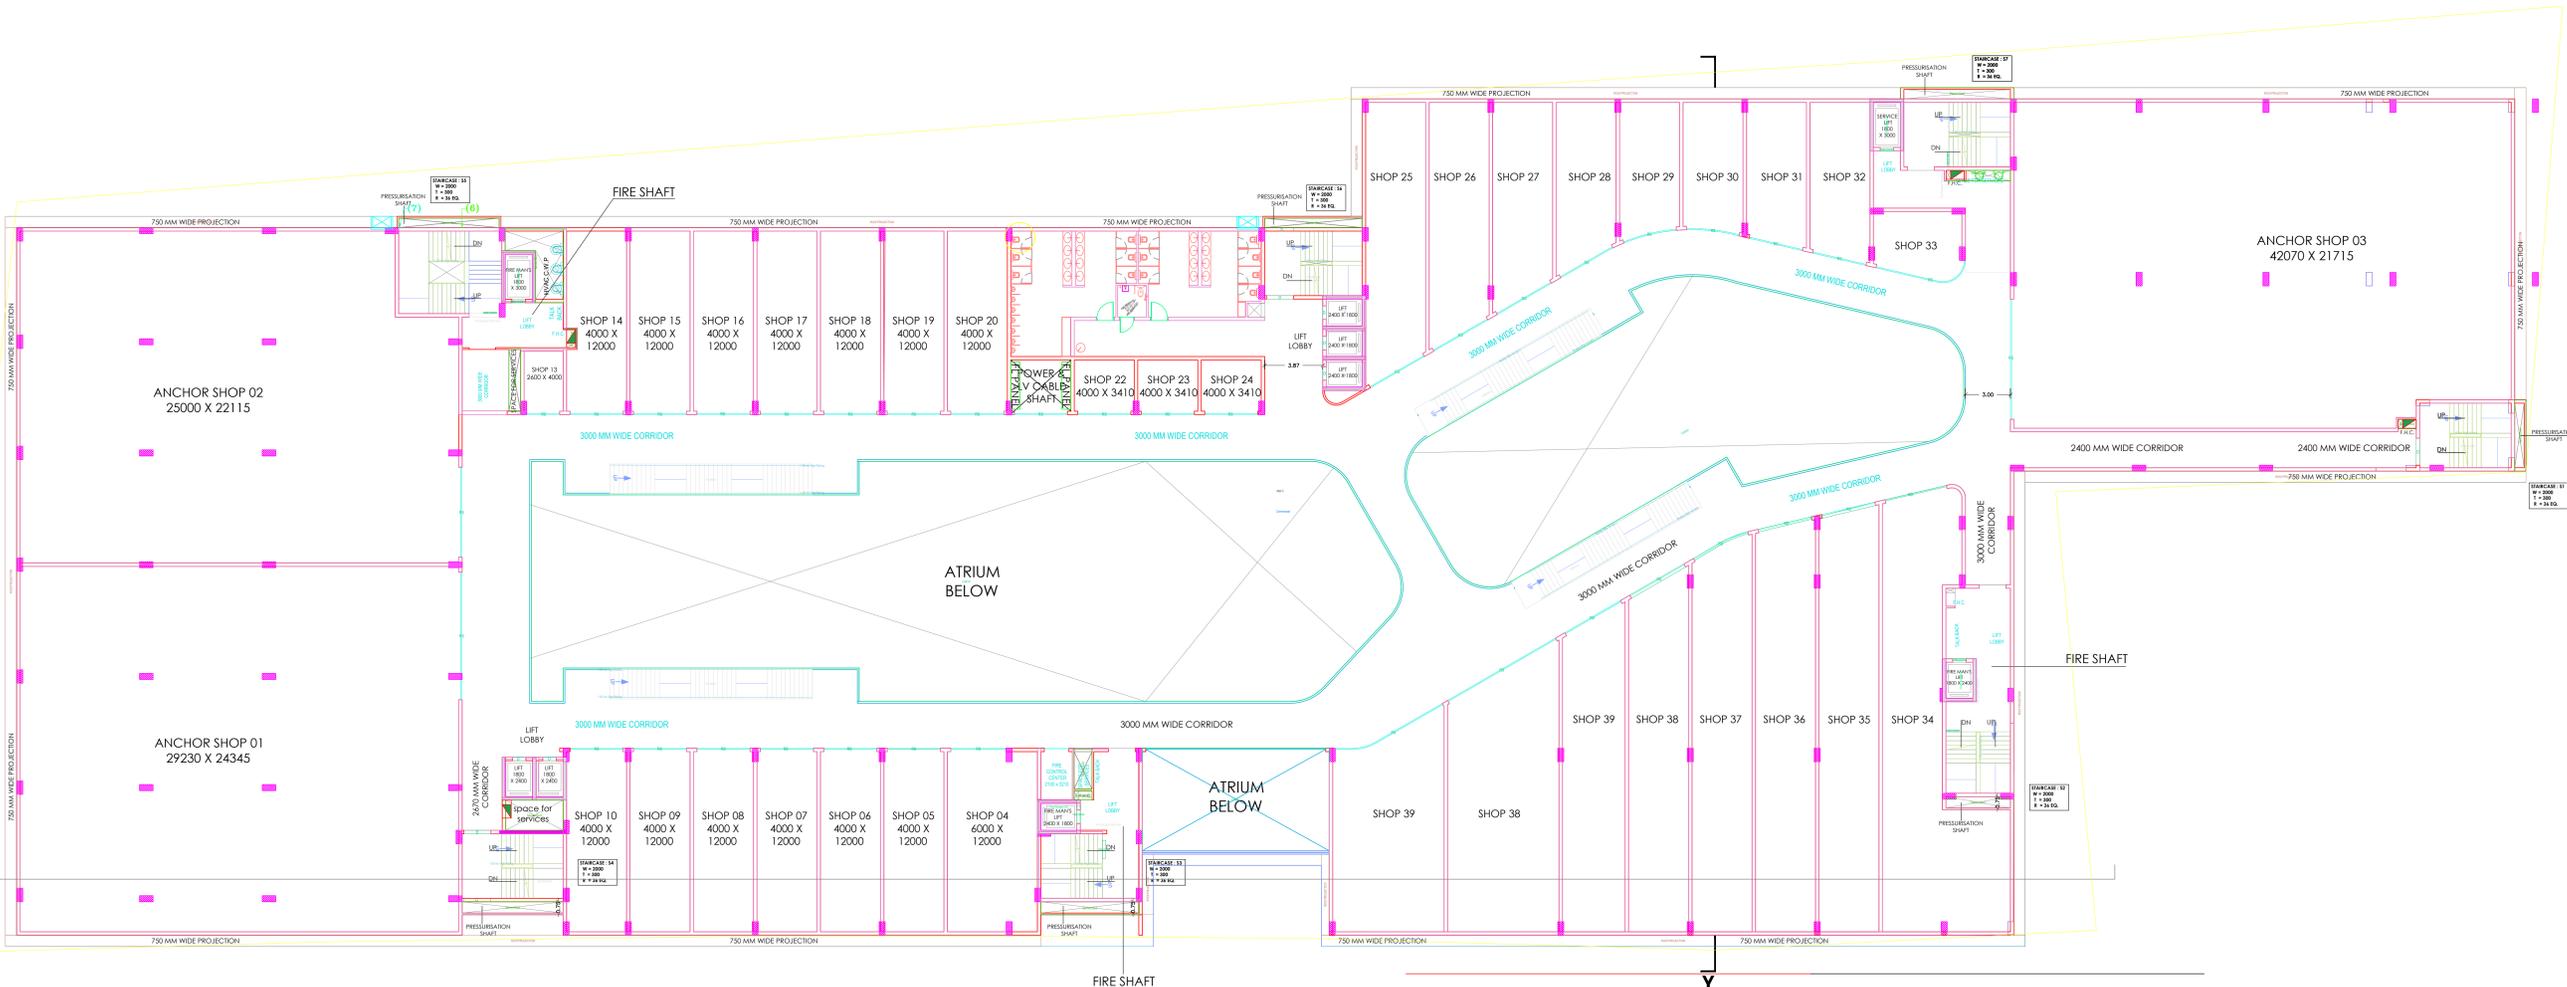

2ND FLOOR PLAN

TOTAL FAR AREA= 5850 SQ. M.

LEGEND SHEET	
SYMBOL	TYPE
(N)	NEUTRAL EARTH Cu
(B)	BODY EARTH Cu
(G)	BODY EARTH GI
[E.M.H.]	ELECTRICAL M.H. SIZE 1200X900MM
[E.M.H.]	ELECTRICAL M.H. SIZE 1500X900MM
[E.M.H.]	ELECTRICAL M.H. SIZE 1500X1500MM
[E.M.H.]	E.M.H. SIZE 1800X1800MM
—	ELEC HUME PIPE 300 MM DIA
—	DWC HOPE PIPE 100MM DIA
↔	6 MTR. 1/2" Y - STREET LIGHT POLE SINGLE BRACKET
↔↔	6MTR Y - STREET LIGHT POLE DOUBLE BRACKET

EARTHING CHART			
NO.	DESCRIPTION	TYPE	STATUS
01	PLATE EARTHING	PLATE	PROVIDED
02	PLATE EARTHING	PLATE	PROVIDED
03	PLATE EARTHING	PLATE	PROVIDED
04	PLATE EARTHING	PLATE	PROVIDED
05	PLATE EARTHING	PLATE	PROVIDED
06	PLATE EARTHING	PLATE	PROVIDED
07	PLATE EARTHING	PLATE	PROVIDED
08	PLATE EARTHING	PLATE	PROVIDED
09	PLATE EARTHING	PLATE	PROVIDED
10	PLATE EARTHING	PLATE	PROVIDED
11	PLATE EARTHING	PLATE	PROVIDED
12	PLATE EARTHING	PLATE	PROVIDED
13	PLATE EARTHING	PLATE	PROVIDED
14	PLATE EARTHING	PLATE	PROVIDED
15	PLATE EARTHING	PLATE	PROVIDED
16	PLATE EARTHING	PLATE	PROVIDED
17	PLATE EARTHING	PLATE	PROVIDED
18	PLATE EARTHING	PLATE	PROVIDED
19	PLATE EARTHING	PLATE	PROVIDED
20	PLATE EARTHING	PLATE	PROVIDED
21	PLATE EARTHING	PLATE	PROVIDED
22	PLATE EARTHING	PLATE	PROVIDED
23	PLATE EARTHING	PLATE	PROVIDED
24	PLATE EARTHING	PLATE	PROVIDED
25	PLATE EARTHING	PLATE	PROVIDED
26	PLATE EARTHING	PLATE	PROVIDED
27	PLATE EARTHING	PLATE	PROVIDED
28	PLATE EARTHING	PLATE	PROVIDED
29	PLATE EARTHING	PLATE	PROVIDED
30	PLATE EARTHING	PLATE	PROVIDED
31	PLATE EARTHING	PLATE	PROVIDED
32	PLATE EARTHING	PLATE	PROVIDED
33	PLATE EARTHING	PLATE	PROVIDED
34	PLATE EARTHING	PLATE	PROVIDED
35	PLATE EARTHING	PLATE	PROVIDED
36	PLATE EARTHING	PLATE	PROVIDED
37	PLATE EARTHING	PLATE	PROVIDED
38	PLATE EARTHING	PLATE	PROVIDED
39	PLATE EARTHING	PLATE	PROVIDED



DATE	07-03-2025 (BASE DRAWING)
DRAWN BY	BALDEEP SINGH
SHEET-A1	SCALE - NTS
CHECKED BY	ANUJ
REVISION	RO
DWG NO	AMB/642/EL-06
NAME OF THE WORK	

PROPOSED SHOPPING MALL AT BABATPUR

PURPOSE OF DRAWING  
SECOND FLOOR  
ELECTRICAL LAYOUT PLAN


PLUM/FIRE CONSULTANT:  
**PDS CONSULTANTS**  
NEW DELHI-110017  
PLUM/FIRE - D.P.S.Royal 9810328084, 9116028084

ARCHITECT  
**DCA**  
DHIRAJ KAPOOR & ASSOCIATES  
MOB # 9935687000 & 9935532800  
OFFICE PH NO. 0542-2220498

HVAC & ELECTRICAL CONSULTANT  
**ambience**  
#04, 2ND FLOOR, S.C.O. 7, SECTOR-7C  
MADHYA MARG, CHANDIGARH - 160019  
CONTACT : 0172-4611228, 991514443  
www.ambienceconsultant.com

**TOTAL CAPACITY OF AUDIS = 1175 SEATS**

AUDI 01 CAPACITY = 281 SEATS  
 AUDI 02 CAPACITY = 281 SEATS  
 AUDI 03 CAPACITY = 281 SEATS  
 AUDI 04 CAPACITY = 332 SEATS

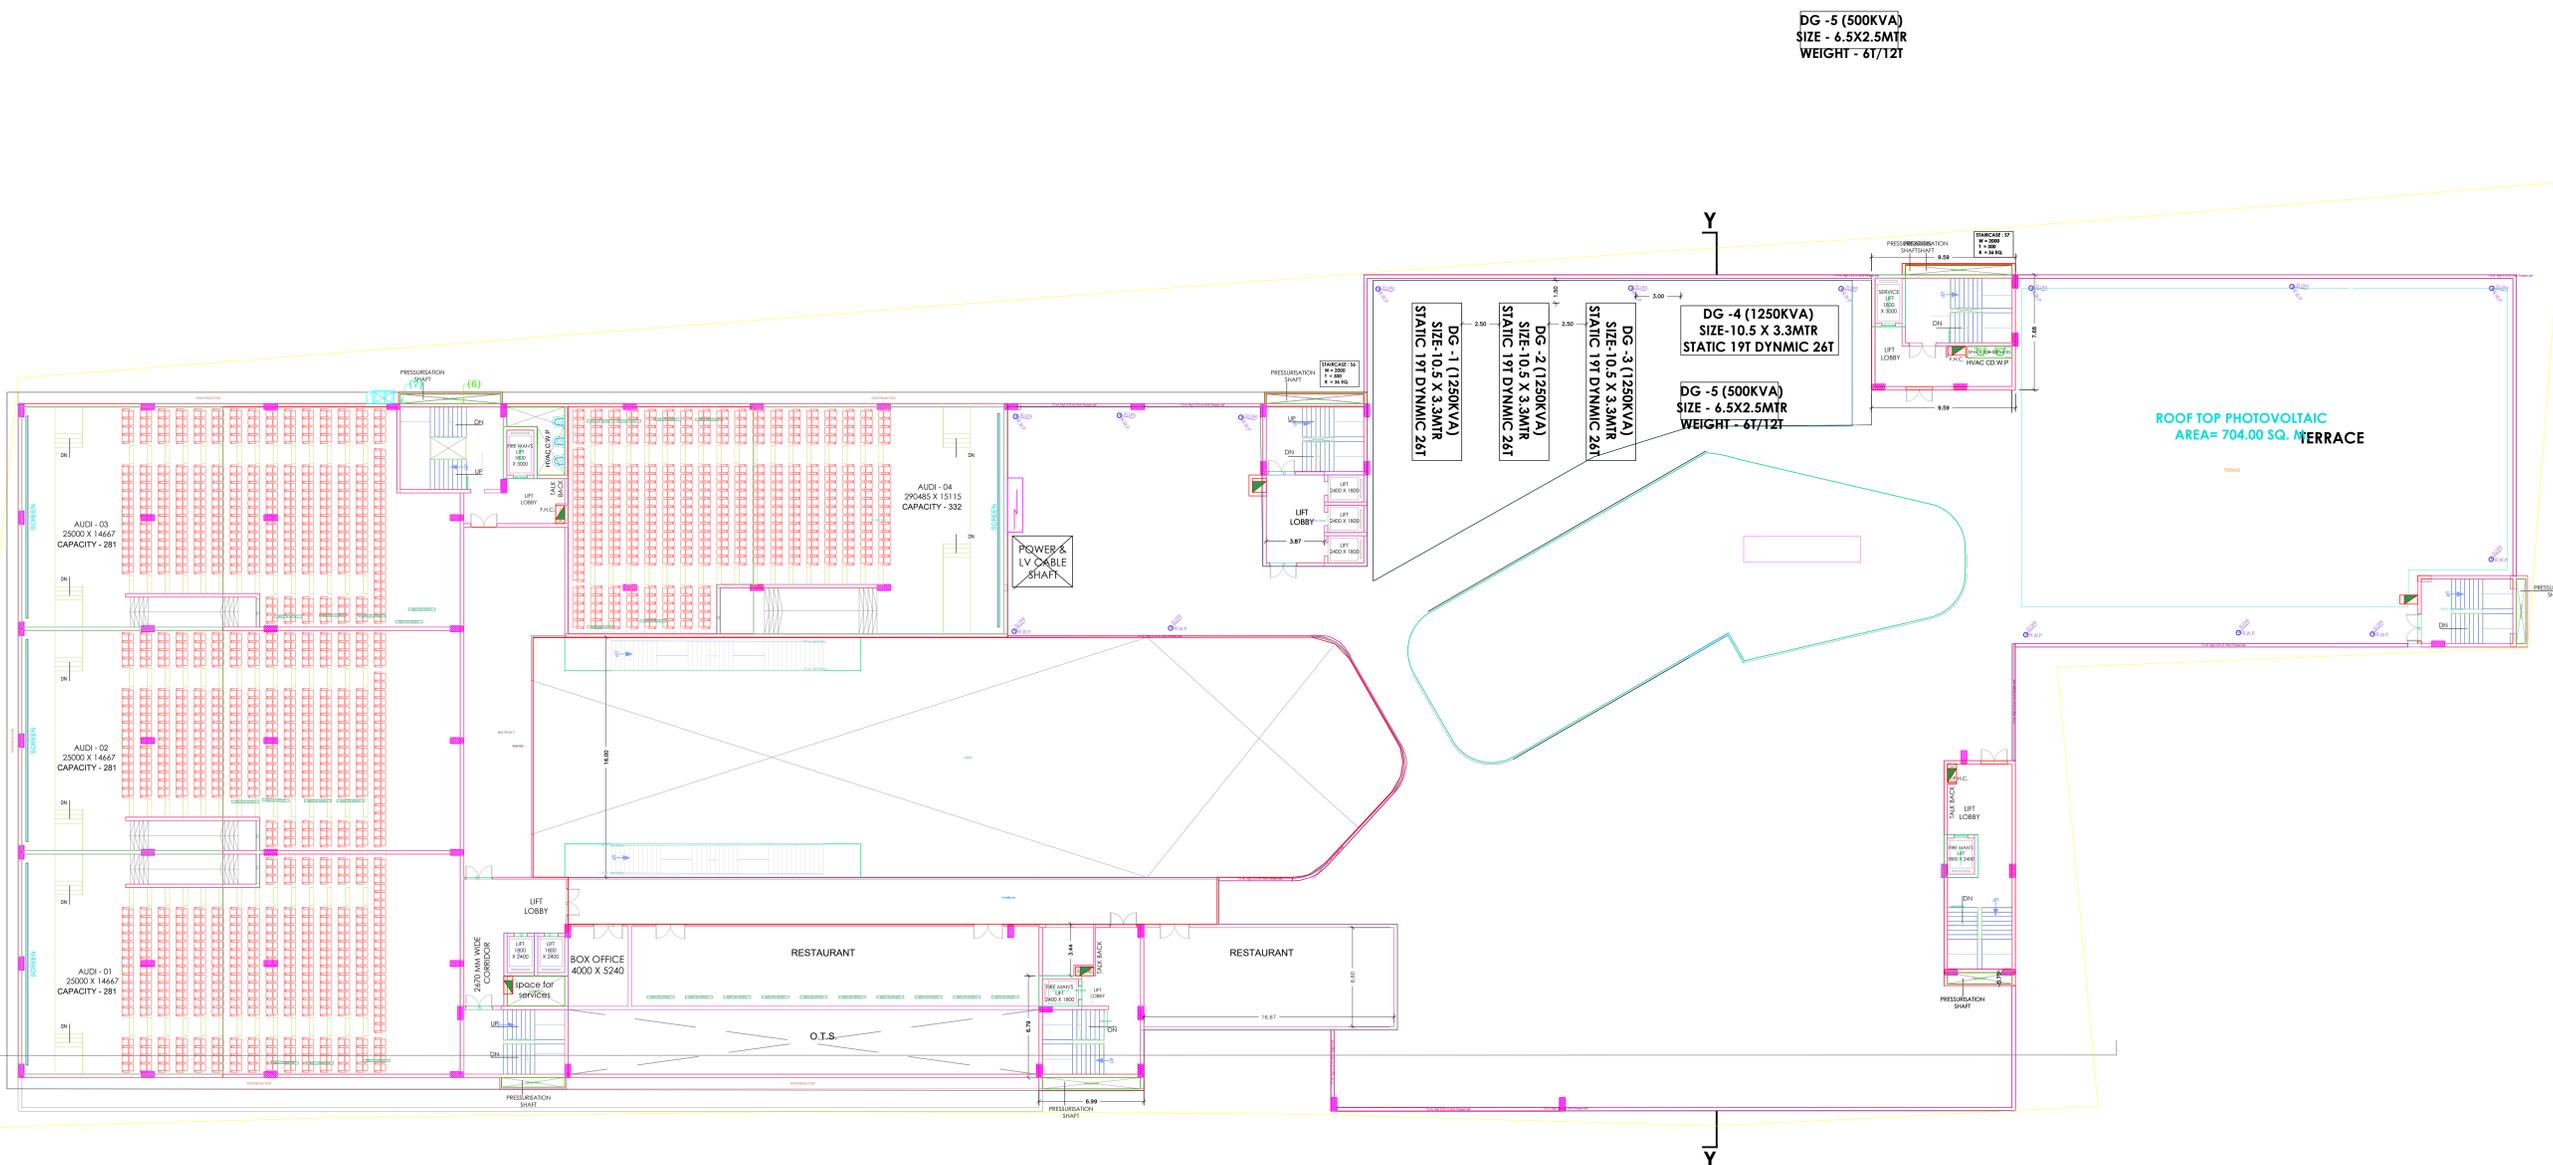

**MULTIPLEX LVL. PLAN**

**TOTAL FAR AREA = 2395.00 SQ. M.**

**LEGEND SHEET**

SYMBOL	TYPE
(E)	NEUTRAL EARTH Cu
(B)	BODY EARTH Cu
(G)	BODY EARTH GI
(E.M.H.)	ELECTRICAL M.H. SIZE 1200X900MM
(E.M.H.)	ELECTRICAL M.H. SIZE 1500X900MM
(E.M.H.)	ELECTRICAL M.H. SIZE 1500X1500MM
(E.M.H.)	E.M.H. SIZE 1800X1800MM
(ELEC PIPE)	ELEC HUME PIPE 300 MM DIA
(DWV PIPE)	DWC HDPE PIPE 100MM DIA
(S.L.B.)	6 MTR. 1/2" Y - STREET LIGHT POLE SINGLE BRACKET
(D.S.L.B.)	6MTR Y - STREET LIGHT POLE DOUBLE BRACKET

**EARTHING CHART**

NO.	DESCRIPTION	QUANTITY	UNIT	REMARKS
1	FLUOROPOLYMER SHEET	1	SQ. M	FOR EARTHING
2	FLUOROPOLYMER SHEET	1	SQ. M	FOR EARTHING
3	FLUOROPOLYMER SHEET	1	SQ. M	FOR EARTHING
4	FLUOROPOLYMER SHEET	1	SQ. M	FOR EARTHING
5	FLUOROPOLYMER SHEET	1	SQ. M	FOR EARTHING
6	FLUOROPOLYMER SHEET	1	SQ. M	FOR EARTHING
7	FLUOROPOLYMER SHEET	1	SQ. M	FOR EARTHING
8	FLUOROPOLYMER SHEET	1	SQ. M	FOR EARTHING
9	FLUOROPOLYMER SHEET	1	SQ. M	FOR EARTHING
10	FLUOROPOLYMER SHEET	1	SQ. M	FOR EARTHING
11	FLUOROPOLYMER SHEET	1	SQ. M	FOR EARTHING
12	FLUOROPOLYMER SHEET	1	SQ. M	FOR EARTHING
13	FLUOROPOLYMER SHEET	1	SQ. M	FOR EARTHING
14	FLUOROPOLYMER SHEET	1	SQ. M	FOR EARTHING
15	FLUOROPOLYMER SHEET	1	SQ. M	FOR EARTHING
16	FLUOROPOLYMER SHEET	1	SQ. M	FOR EARTHING
17	FLUOROPOLYMER SHEET	1	SQ. M	FOR EARTHING
18	FLUOROPOLYMER SHEET	1	SQ. M	FOR EARTHING
19	FLUOROPOLYMER SHEET	1	SQ. M	FOR EARTHING
20	FLUOROPOLYMER SHEET	1	SQ. M	FOR EARTHING



DATE	07-03-2025 (BASE DRAWING)
DRAWN BY	BALDEEP SINGH
SHEET-A1	SCALE - NTS
CHECKED BY	ANUJ
REVISION	RO
DWG NO	AMB/642/EL-07


**NAME OF THE WORK**  
 PROPOSED SHOPPING MALL AT BABATPUR

**PURPOSE OF DRAWING**  
 THIRD FLOOR  
 ELECTRICAL LAYOUT PLAN

**PLUM/FIRE CONSULTANT:**  
**PDS CONSULTANTS**  
 NEW DELHI-110017  
 PLUM/FIRE - D.P.S Rawat-9810328084,9716028084

**ARCHITECT**  
  
 DHIRAJ KAPOOR & ASSOCIATES  
 MOB. # 9935687000 & 9935532800  
 OFFICE PH. NO. 0542-2220498

**HVAC & ELECTRICAL CONSULTANT**  
  
 #204, 2ND FLOOR, S.C.O. 7, SECTOR-7C  
 MADHYA MARC, CHANDIGARH - 160019  
 CONTACT: 0172-4811238, 9915154443  
 www.ambienceconsultant.com

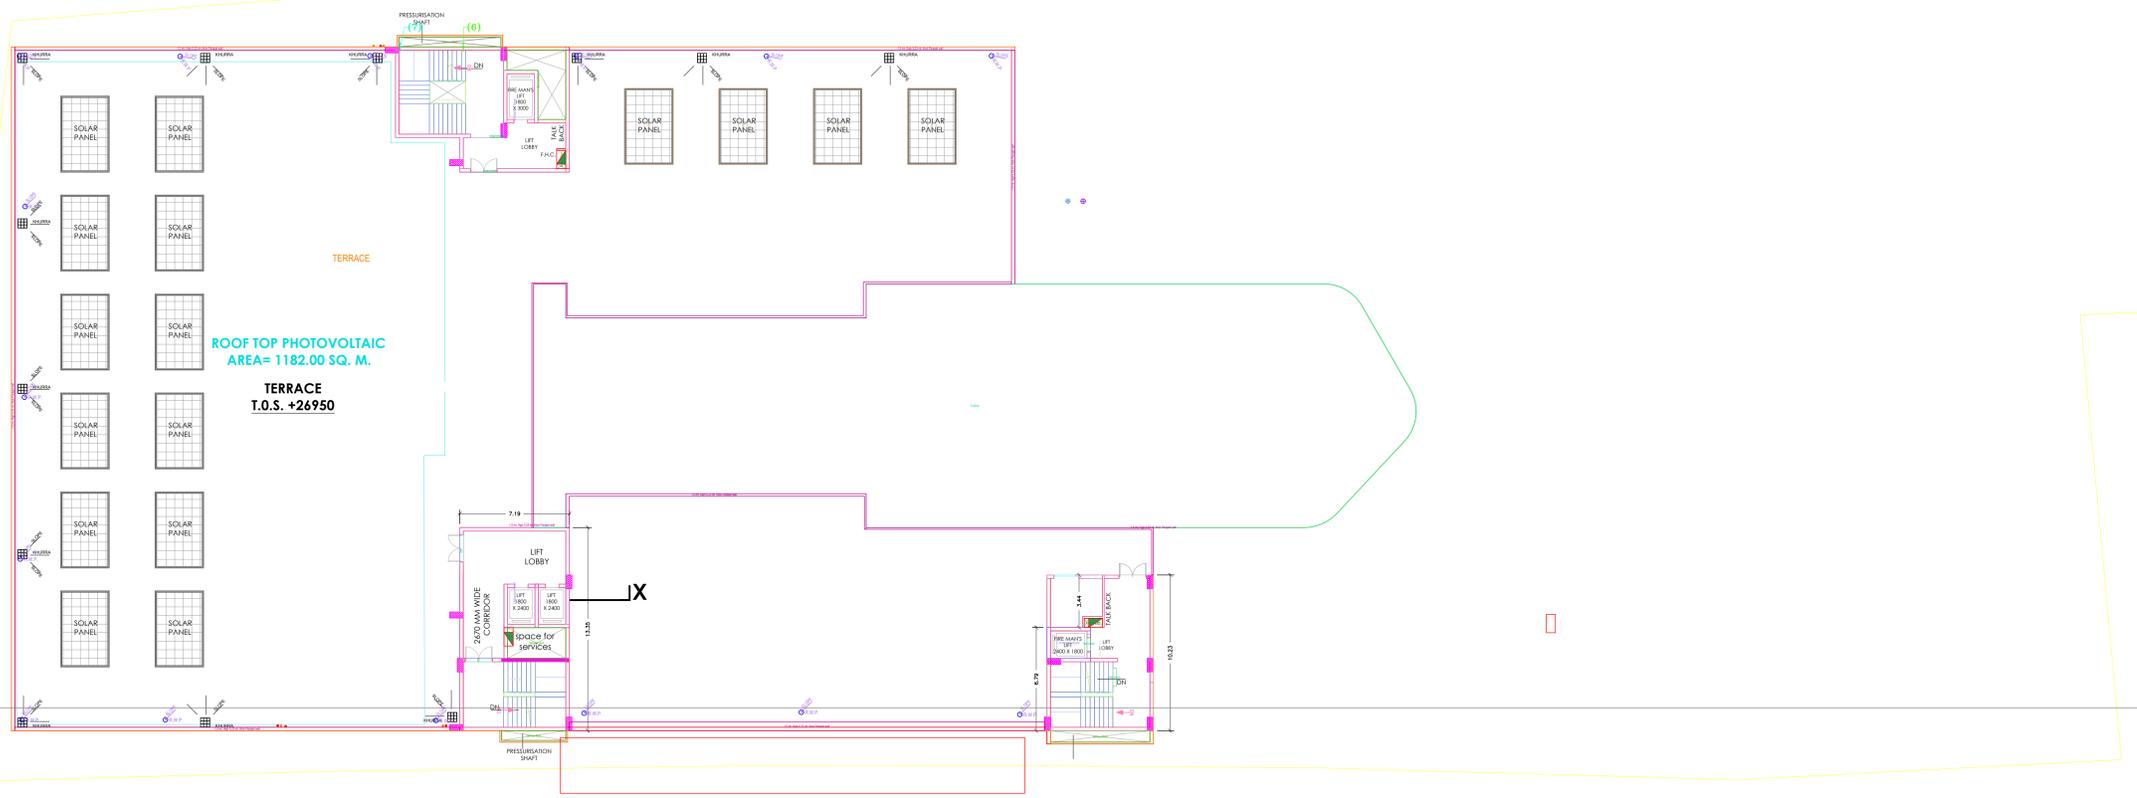

TERRACE LVL. PLAN

**LEGEND SHEET**

SYMBOL	TYPE
	NEUTRAL EARTH Cu
	BODY EARTH Cu
	BODY EARTH GI
	ELECTRICAL M.H. SIZE 1200X900MM
	ELECTRICAL M.H. SIZE 1500X900MM
	ELECTRICAL M.H. SIZE 1500X1500MM
	E.M.H. SIZE 1800X1800MM
	ELEC HUME PIPE 300 MM DIA
	DWC HUME PIPE 100MM DIA
	6 MTR. 1/2 Y - STREET LIGHT POLE SINGLE BRACKET
	6MTR Y - STREET LIGHT POLE DOUBLE BRACKET

**EARTHING CHART**

NO.	TYPE OF EARTHING	SIZE	DEPTH	LOCATION
01	PLATE EARTHING	100x100	1000	ROOF TOP
02	PLATE EARTHING	100x100	1000	ROOF TOP
03	PLATE EARTHING	100x100	1000	ROOF TOP
04	PLATE EARTHING	100x100	1000	ROOF TOP
05	PLATE EARTHING	100x100	1000	ROOF TOP
06	PLATE EARTHING	100x100	1000	ROOF TOP
07	PLATE EARTHING	100x100	1000	ROOF TOP
08	PLATE EARTHING	100x100	1000	ROOF TOP
09	PLATE EARTHING	100x100	1000	ROOF TOP
10	PLATE EARTHING	100x100	1000	ROOF TOP
11	PLATE EARTHING	100x100	1000	ROOF TOP
12	PLATE EARTHING	100x100	1000	ROOF TOP
13	PLATE EARTHING	100x100	1000	ROOF TOP
14	PLATE EARTHING	100x100	1000	ROOF TOP
15	PLATE EARTHING	100x100	1000	ROOF TOP
16	PLATE EARTHING	100x100	1000	ROOF TOP
17	PLATE EARTHING	100x100	1000	ROOF TOP
18	PLATE EARTHING	100x100	1000	ROOF TOP
19	PLATE EARTHING	100x100	1000	ROOF TOP
20	PLATE EARTHING	100x100	1000	ROOF TOP
21	PLATE EARTHING	100x100	1000	ROOF TOP
22	PLATE EARTHING	100x100	1000	ROOF TOP
23	PLATE EARTHING	100x100	1000	ROOF TOP
24	PLATE EARTHING	100x100	1000	ROOF TOP
25	PLATE EARTHING	100x100	1000	ROOF TOP
26	PLATE EARTHING	100x100	1000	ROOF TOP
27	PLATE EARTHING	100x100	1000	ROOF TOP
28	PLATE EARTHING	100x100	1000	ROOF TOP
29	PLATE EARTHING	100x100	1000	ROOF TOP
30	PLATE EARTHING	100x100	1000	ROOF TOP
31	PLATE EARTHING	100x100	1000	ROOF TOP
32	PLATE EARTHING	100x100	1000	ROOF TOP
33	PLATE EARTHING	100x100	1000	ROOF TOP
34	PLATE EARTHING	100x100	1000	ROOF TOP
35	PLATE EARTHING	100x100	1000	ROOF TOP
36	PLATE EARTHING	100x100	1000	ROOF TOP
37	PLATE EARTHING	100x100	1000	ROOF TOP
38	PLATE EARTHING	100x100	1000	ROOF TOP
39	PLATE EARTHING	100x100	1000	ROOF TOP
40	PLATE EARTHING	100x100	1000	ROOF TOP
41	PLATE EARTHING	100x100	1000	ROOF TOP
42	PLATE EARTHING	100x100	1000	ROOF TOP
43	PLATE EARTHING	100x100	1000	ROOF TOP
44	PLATE EARTHING	100x100	1000	ROOF TOP
45	PLATE EARTHING	100x100	1000	ROOF TOP
46	PLATE EARTHING	100x100	1000	ROOF TOP
47	PLATE EARTHING	100x100	1000	ROOF TOP
48	PLATE EARTHING	100x100	1000	ROOF TOP
49	PLATE EARTHING	100x100	1000	ROOF TOP
50	PLATE EARTHING	100x100	1000	ROOF TOP



DATE	07-03-2025 (BASE DRAWING)
DRAWN BY	BALDEEP SINGH
SHEET-A1	SCALE - NTS
CHECKED BY	ANUJ
REVISION	RO
DWG NO	AMB/642/EL-08

NAME OF THE WORK  
**PROPOSED SHOPPING MALL AT BABATPUR**

PURPOSE OF DRAWING  
**FOURTH FLOOR ELECTRICAL LAYOUT PLAN**

PLUM/FIRE CONSULTANT:  
**PDS CONSULTANTS**  
 NEW DELHI-110017  
 PLUM/FIRE - D.P.S.Royal/9810228084/9116028084

ARCHITECT  
  
 DHIRAJ KAPOOR & ASSOCIATES  
 MOB # 9935687000 & 9935532800  
 OFFICE PH NO. 0542-2220498

HVAC & ELECTRICAL CONSULTANT  
  
 #204, 2ND FLOOR, S.C.O. 7, SECTOR-7C  
 MADHYA MARG, CHANDIGARH - 160019  
 CONTACT : 0172-4611238, 9915144443  
 www.ambienceconsultant.com