

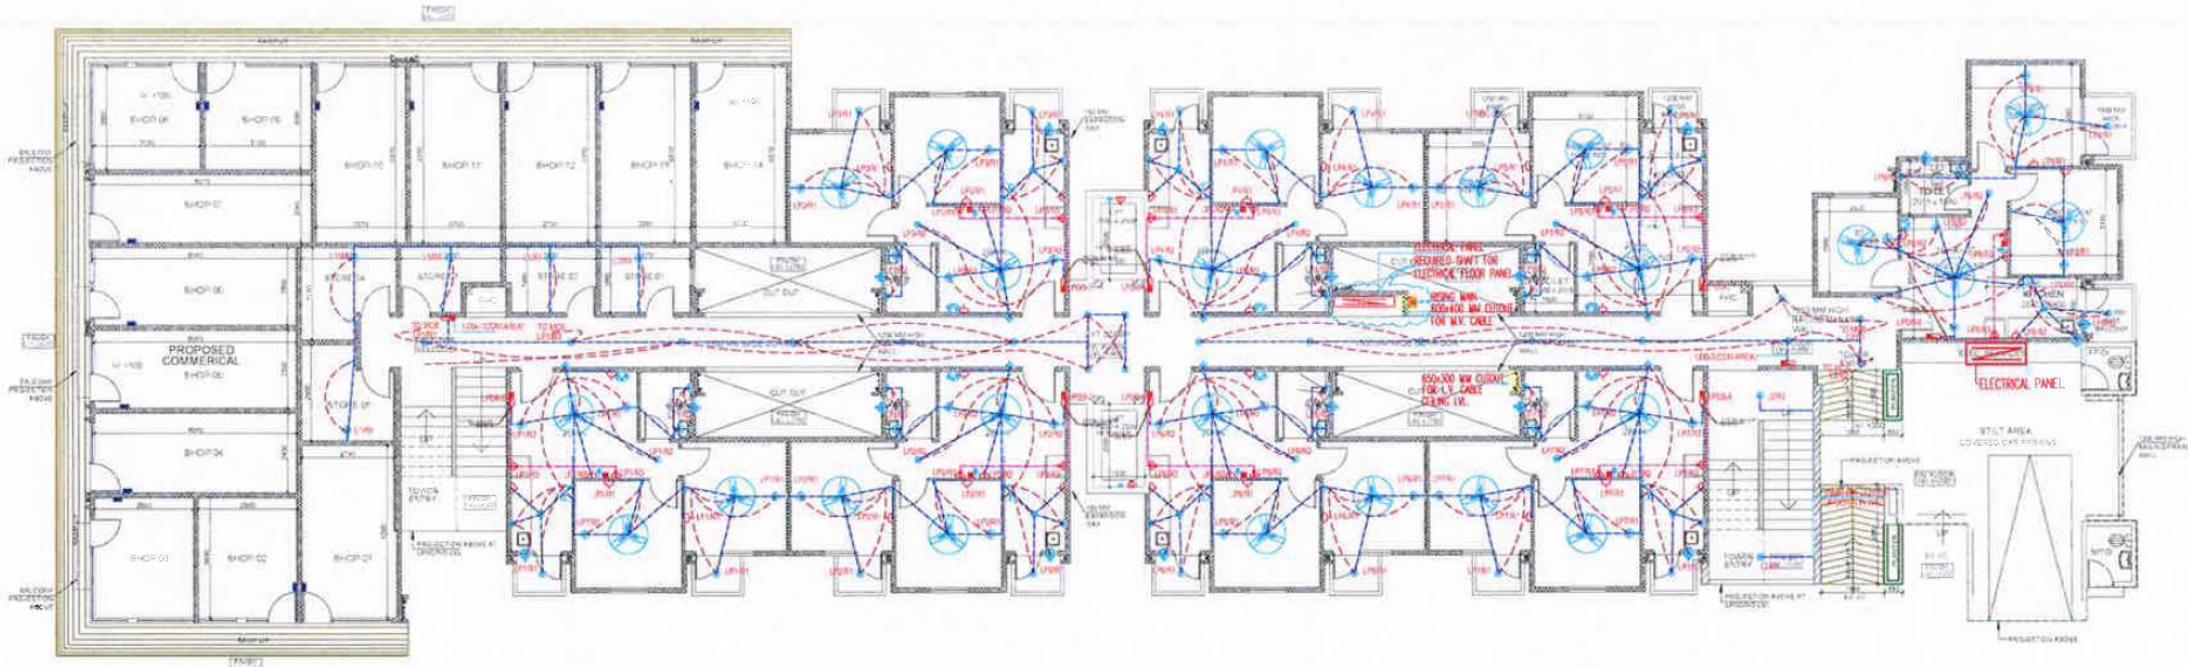
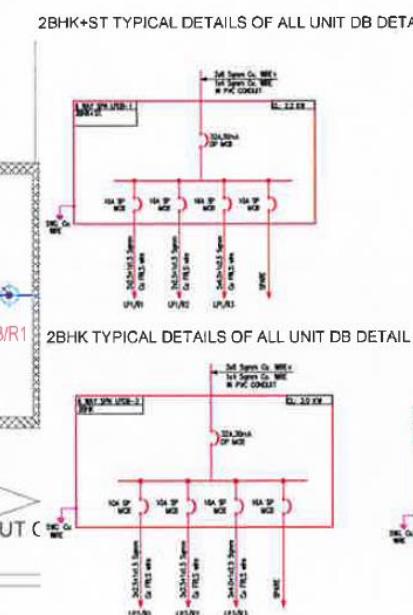


Swamanorath – Electrical Plan

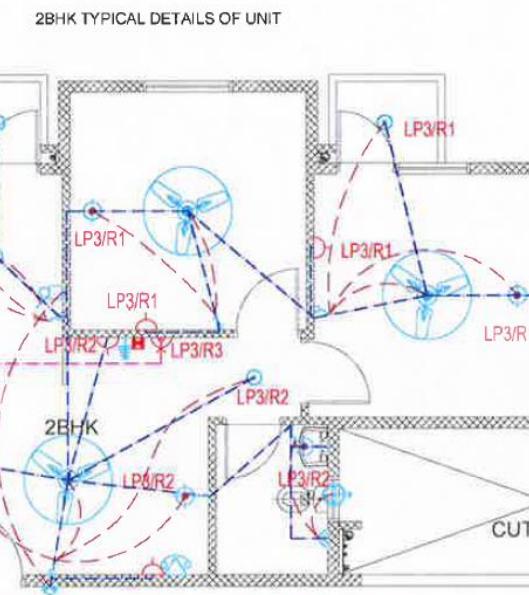


GROUND FLOOR PLAN

SCALE 1:100

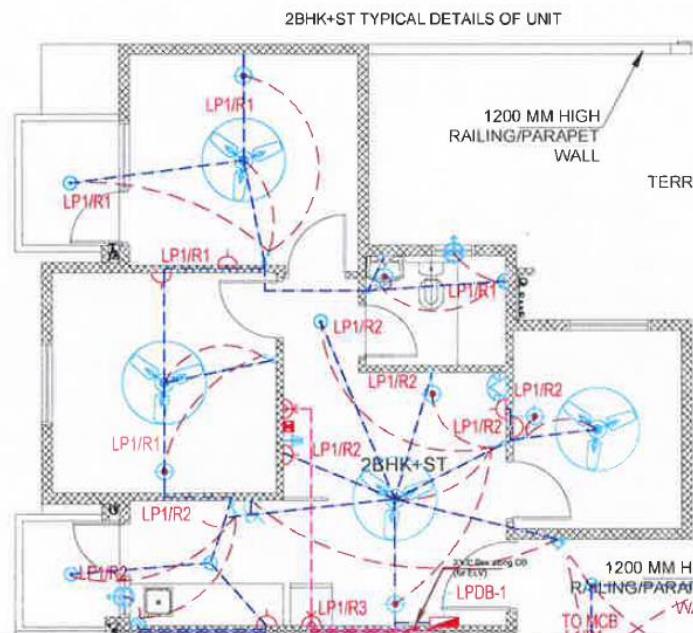

SWAMANORATH – TOWER A1 ELECTRICITY SUPPLY PLAN

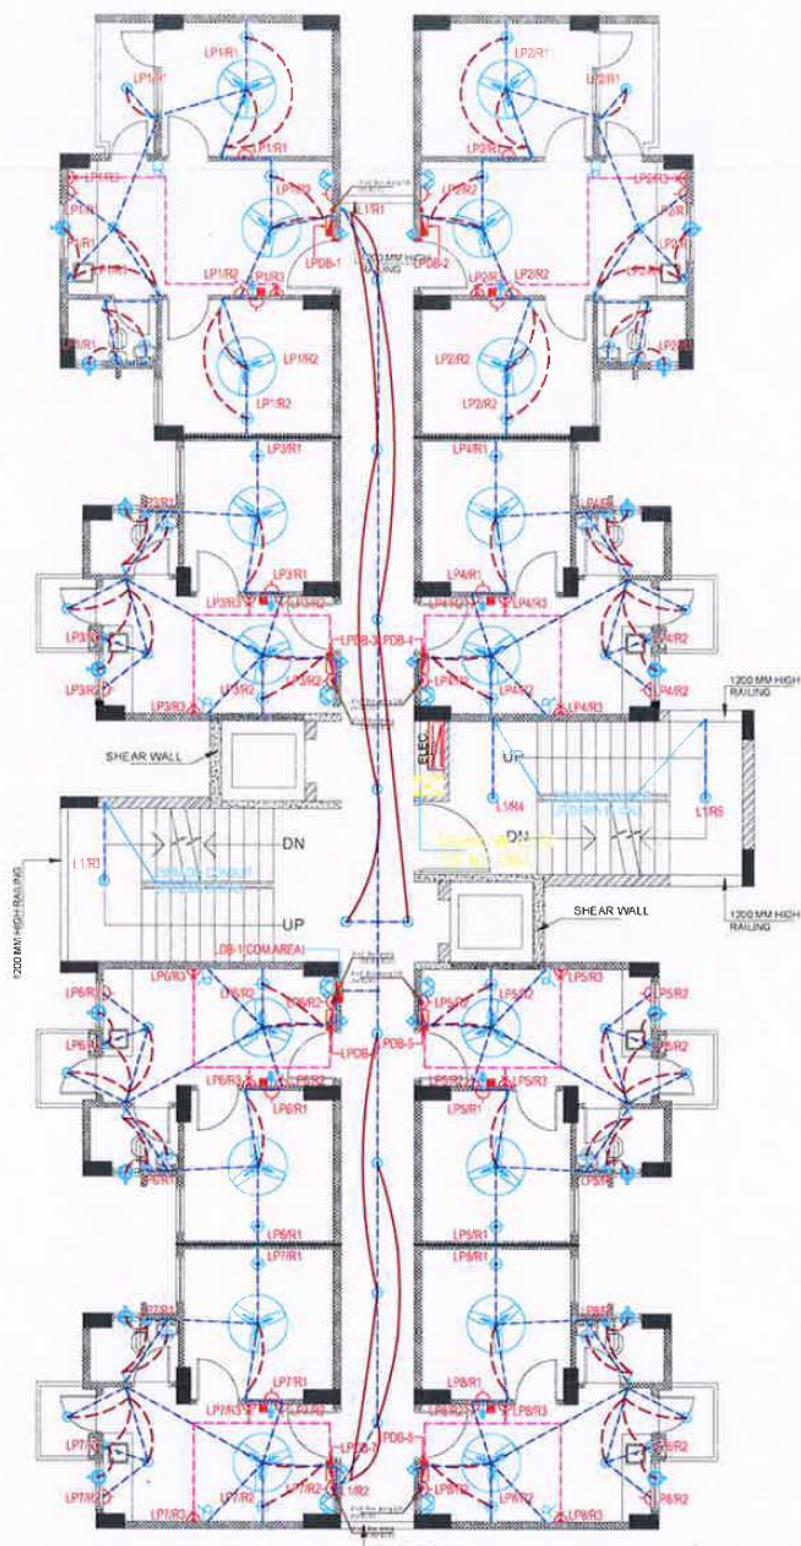


GROUND FLOOR PLAN

SCALE: 1:100


- 01
- 02
- 03
- 04
- 05
- 06
- 07
- 08
- 09
- 10
- 11
- 12
- 13
- 14
- 15
- 16




TYPICAL DETAILS OF 2 BHK UNIT

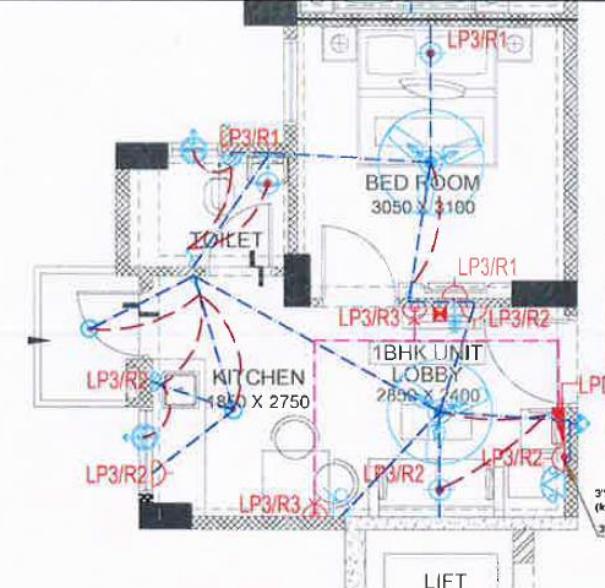

TYPICAL DETAILS OF 1 BHK UNIT

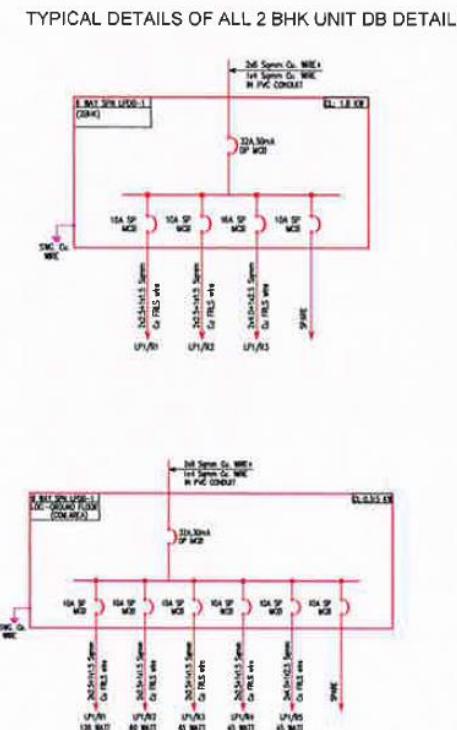

TYPICAL DETAILS OF ALL 2 BHK UNIT DB DETAIL

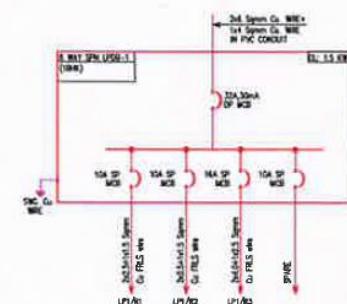

TYPICAL DETAILS OF ALL 1 BHK UNIT DB DETAIL