
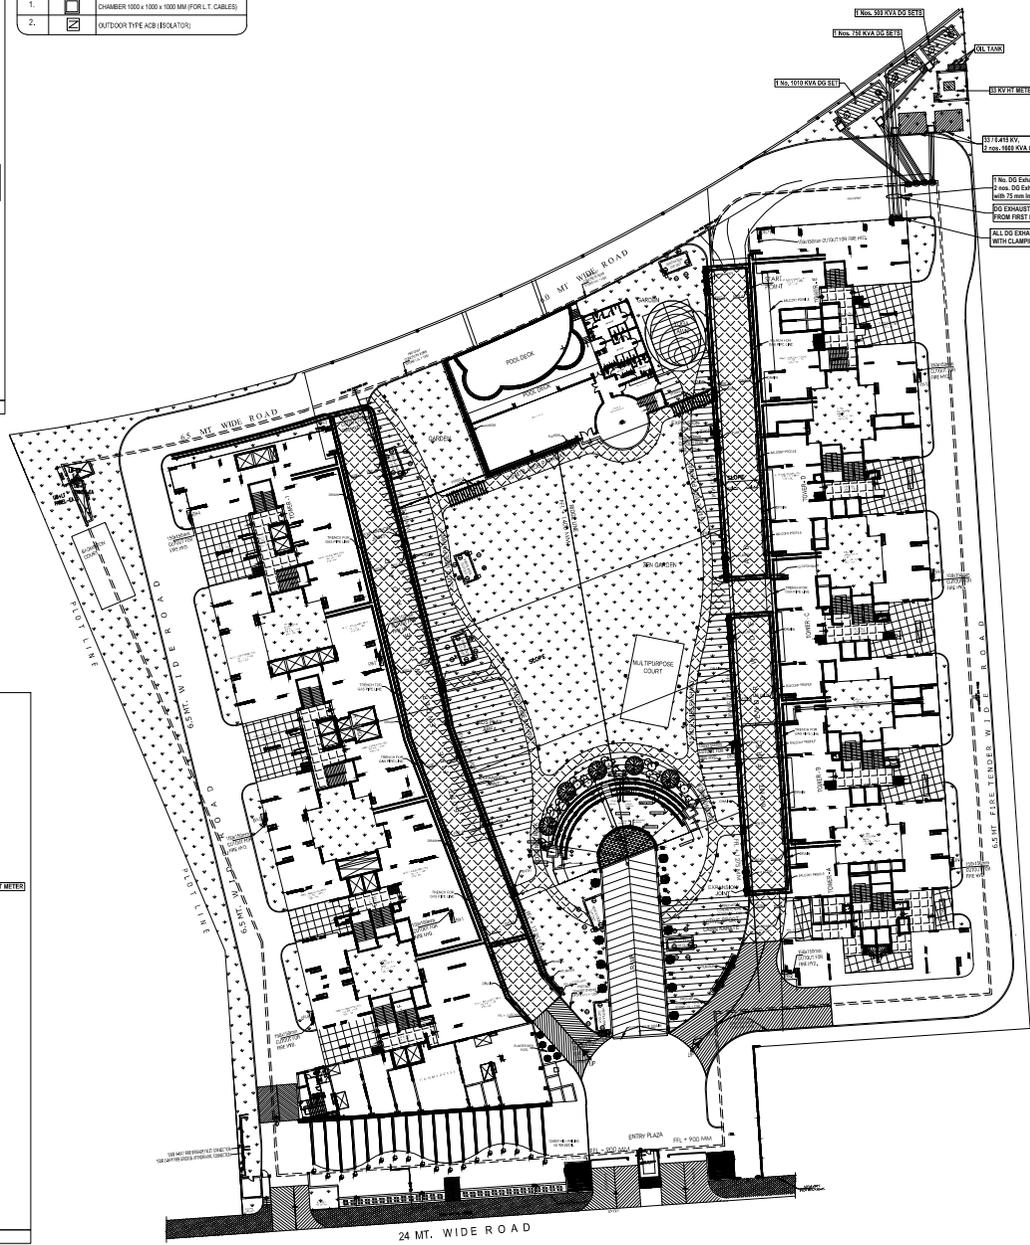
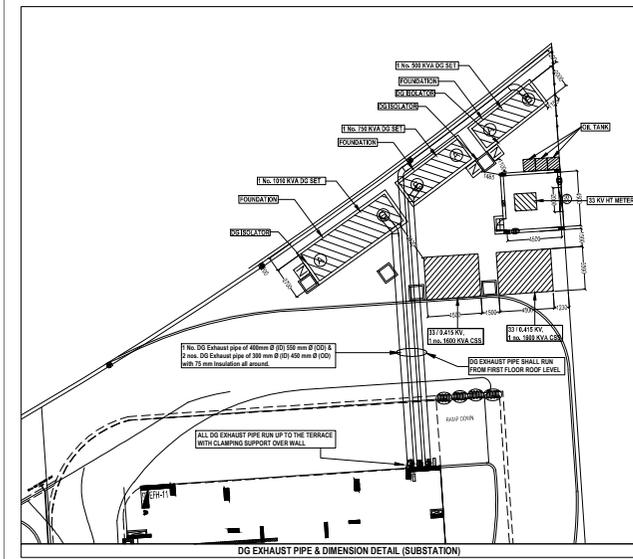
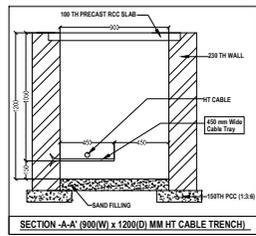


LEGEND :

S. NO.	SYMBOL	DESCRIPTIONS
1.	[Symbol]	CHAMBER 1000 x 1000 x 1000 MM FOR L.T. CABLES
2.	[Symbol]	OUTDOOR TYPE ACB (ISOLATOR)

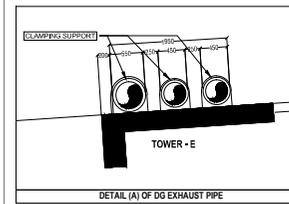

- NOTES :**
- 1) Clear height of 33 KV Motor room shall be minimum 3.6 mtr. Below clear height.
 - 2) Finish Level of Motor room & VCB room shall be 450 mm above final finished ground level. *
 - 3) Trench detail shall be finalized after receiving foundation detail of HT Motor Panel.

project
SAYA ZION
AT GREATER NOIDA

title
ELECTRICAL DRAWING

subtitle
SETTING-OUT LAYOUT
(SITE PLAN)

drawing released for
 APPROVAL SUBMISSION
 ADVANCE COPY CONSTRUCTION

dig. no. S2/ELEC/EXT.-01 drawn by Najmul

scale 1:400 @ A1 designed by Atiq-Us-Rehman

date December, 2016 checked by Anand Havella

architects
SAYA BUILDCON CONSORTIUM PVT. LTD.
GHAZIABAD

services consultant
Consummate Engineering Services (P) Ltd.
Noida Office : B-47, Sector-47, Noida - 201 301
Tel: (0120) 494200 (24 Lines)
Lucknow Office : 8/68, Bahadur Puri, Lucknow
e-mail : mail@cespl.in, website : www.cespl.in