


PLUMBING LEGEND- EXTERNAL	
SEWER MANHOLE	
STORM MANHOLE	
CATCH BASIN SIZE 450X500 MM	
SEWER LINE	
STORM LINE	
IRREGION LINE	
VALVE WITH CHAMBER 500X500MM	
HARVESTING PIT- 4M DIA.,2M W.D	
DESELTING CHAMBER- 1.5 X1 M	
NON RETURN VALVE	
VALVE	
GARDEN HYDRANT.	

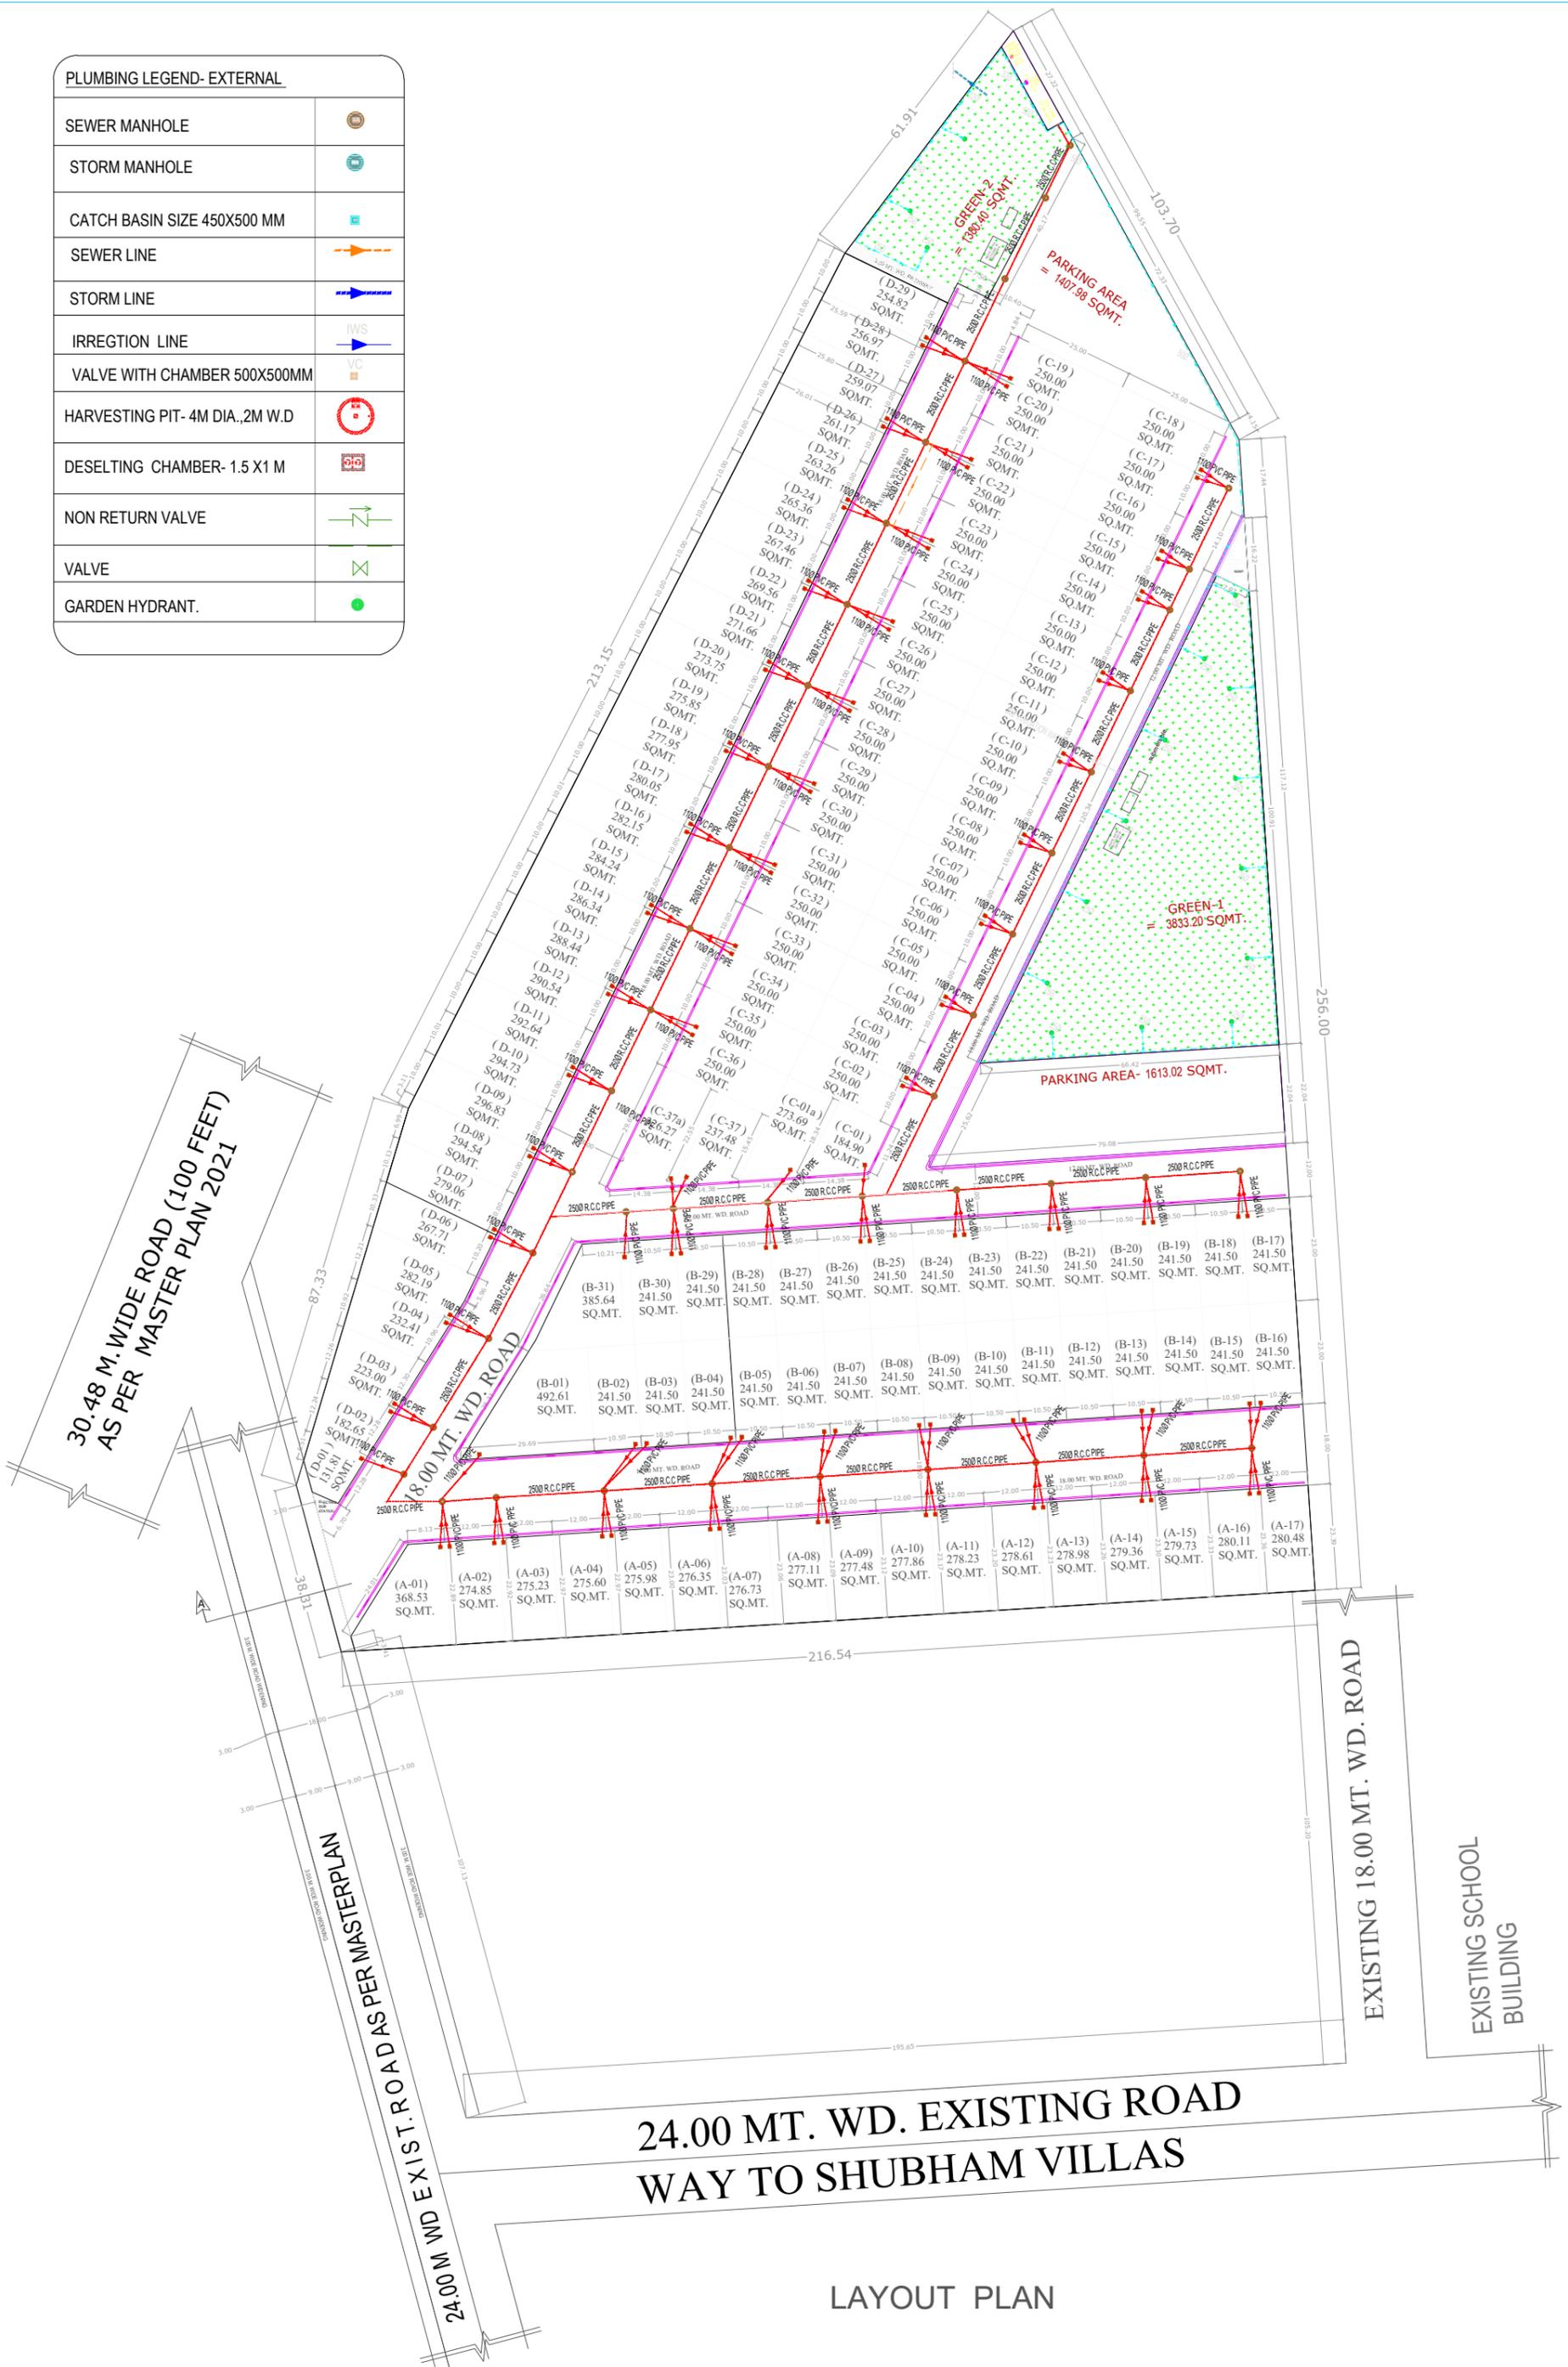

CLIENT:	ANANDAM HIGHSTREET
SHEET TITLE:	WASTE DISPOSAL PLAN

PROJECT:	AT MORADABAD
----------	--------------

DATE OF ISSUE:	28-08-23
DRG NO:	

DEALT BY:	AMIT
-----------	------

ARCHITECT:	VINAYAK GUPTA B.ARCH.MARCH(LONDON)
------------	---------------------------------------

**ARCHANA RAJ PLANNERS AND CONSULTANTS**  
 PLOT SHANKAR DUTT SHARMA MARG OPP. CIVIL LINES POLICE STATION, MORADABAD  
 MOB: +91 9359439900, E-MAIL: arpj@outlook.com, vinayak\_gupta2002@yahoo.com