



THIS DRAWING IS THE PROPERTY AND COPY  
RIGHT OF BUILDWELL CONSULTING ENGINEERS  
AND THE SAME SHALL NOT BE  
COPIED OR USED IN ANY WAY WITHOUT THEIR  
WRITTEN PERMISSION.

PROJECT: SUN SHINE GROUP HOUSING

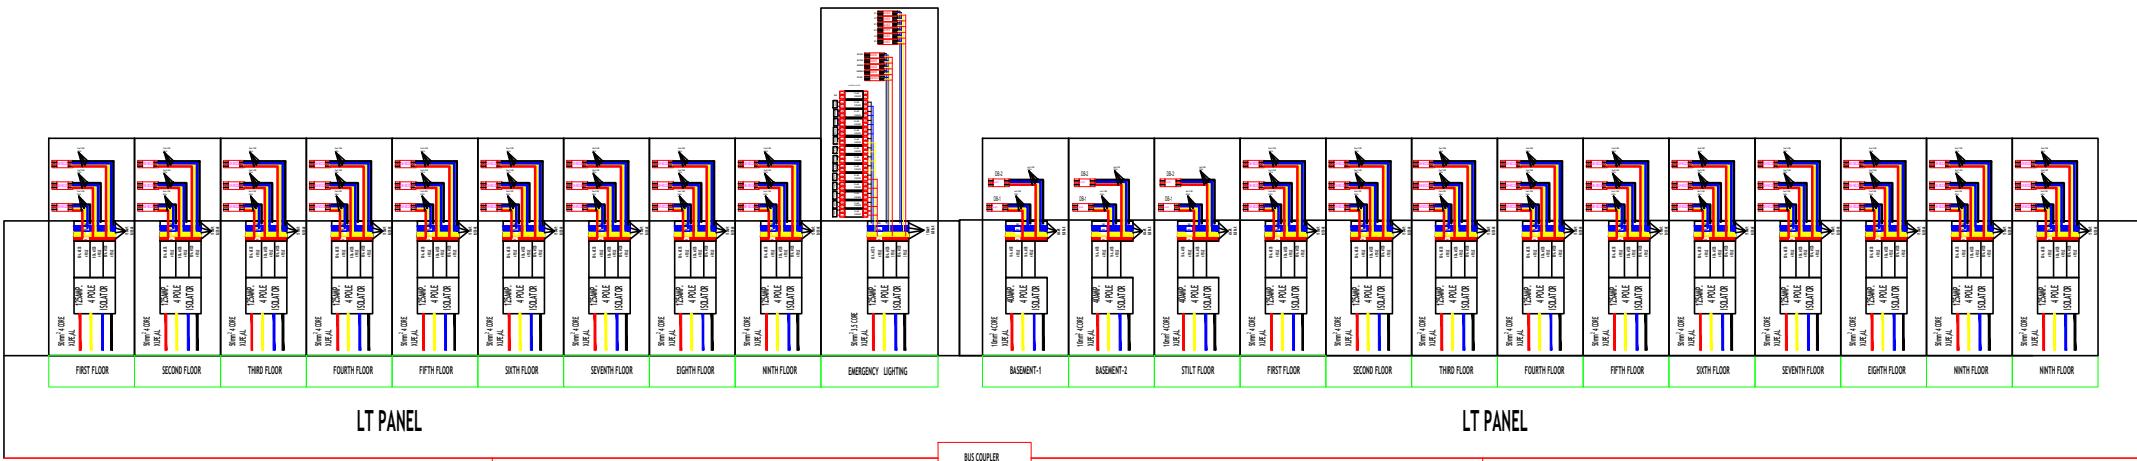

LT PANEL

LT PANEL

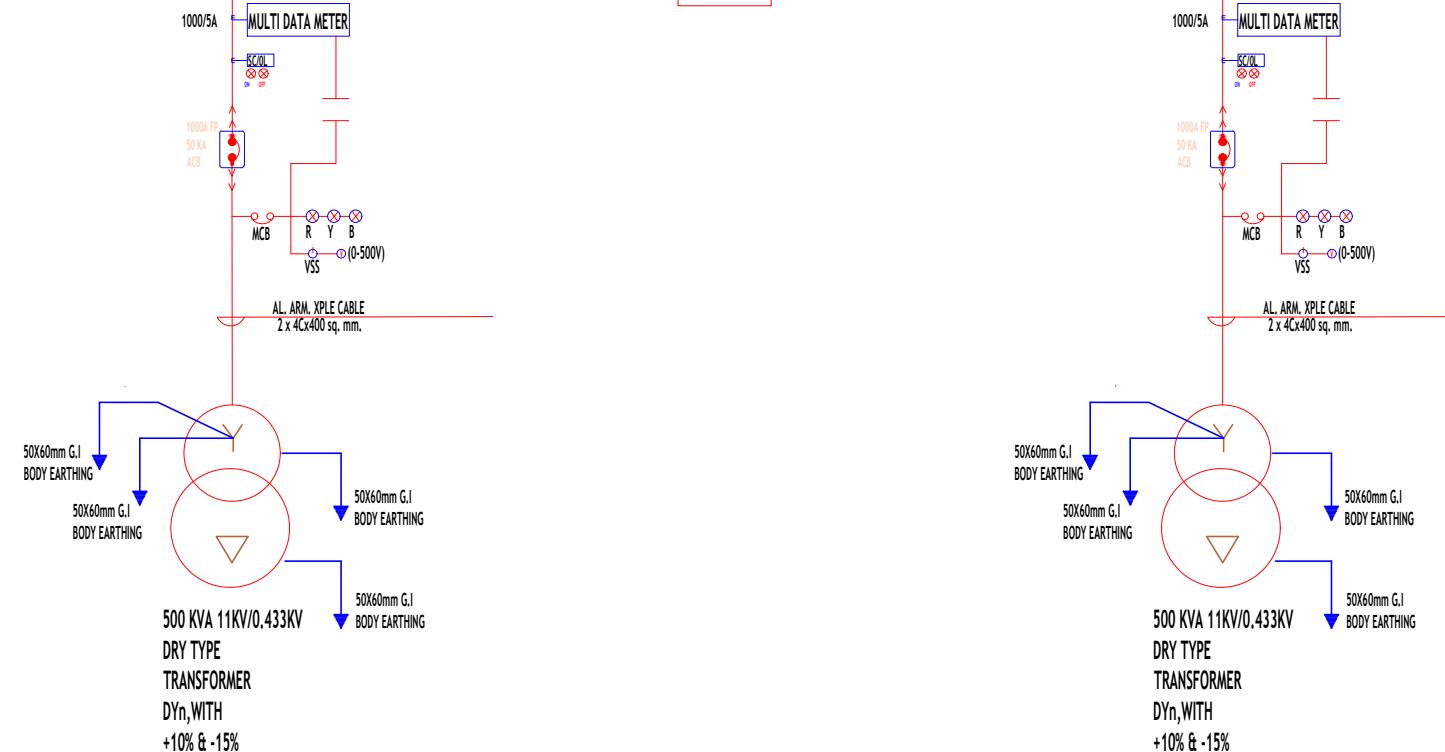

**TOWER-1**

**TOWER-2**

**ELECTRICAL SINGLE LINE DIAGRAM**

**DESCRIPTION**

**ARCHITECT:**



**BUILDWELL**  
CONSULTING ENGINEERS

Regd. Office: A-49,Abul Fazal Enclave-II,Near  
Jamia, Okhla, New Delhi-110025  
E-mail : bwce8282@gmail.com  
Phone. :+91-9458511015

**DRAWING TITLE:**  
**ELECTRICAL SINGLE LINE DIAGRAM**

**DEALT BY** FAIZAN **DATE** 16-02-2024

**SCALE** NTS

**DESIGNED BY**  
**ER.NOOR MOHD**

**DRAWING NO.** 01 **REVISION** 00