
 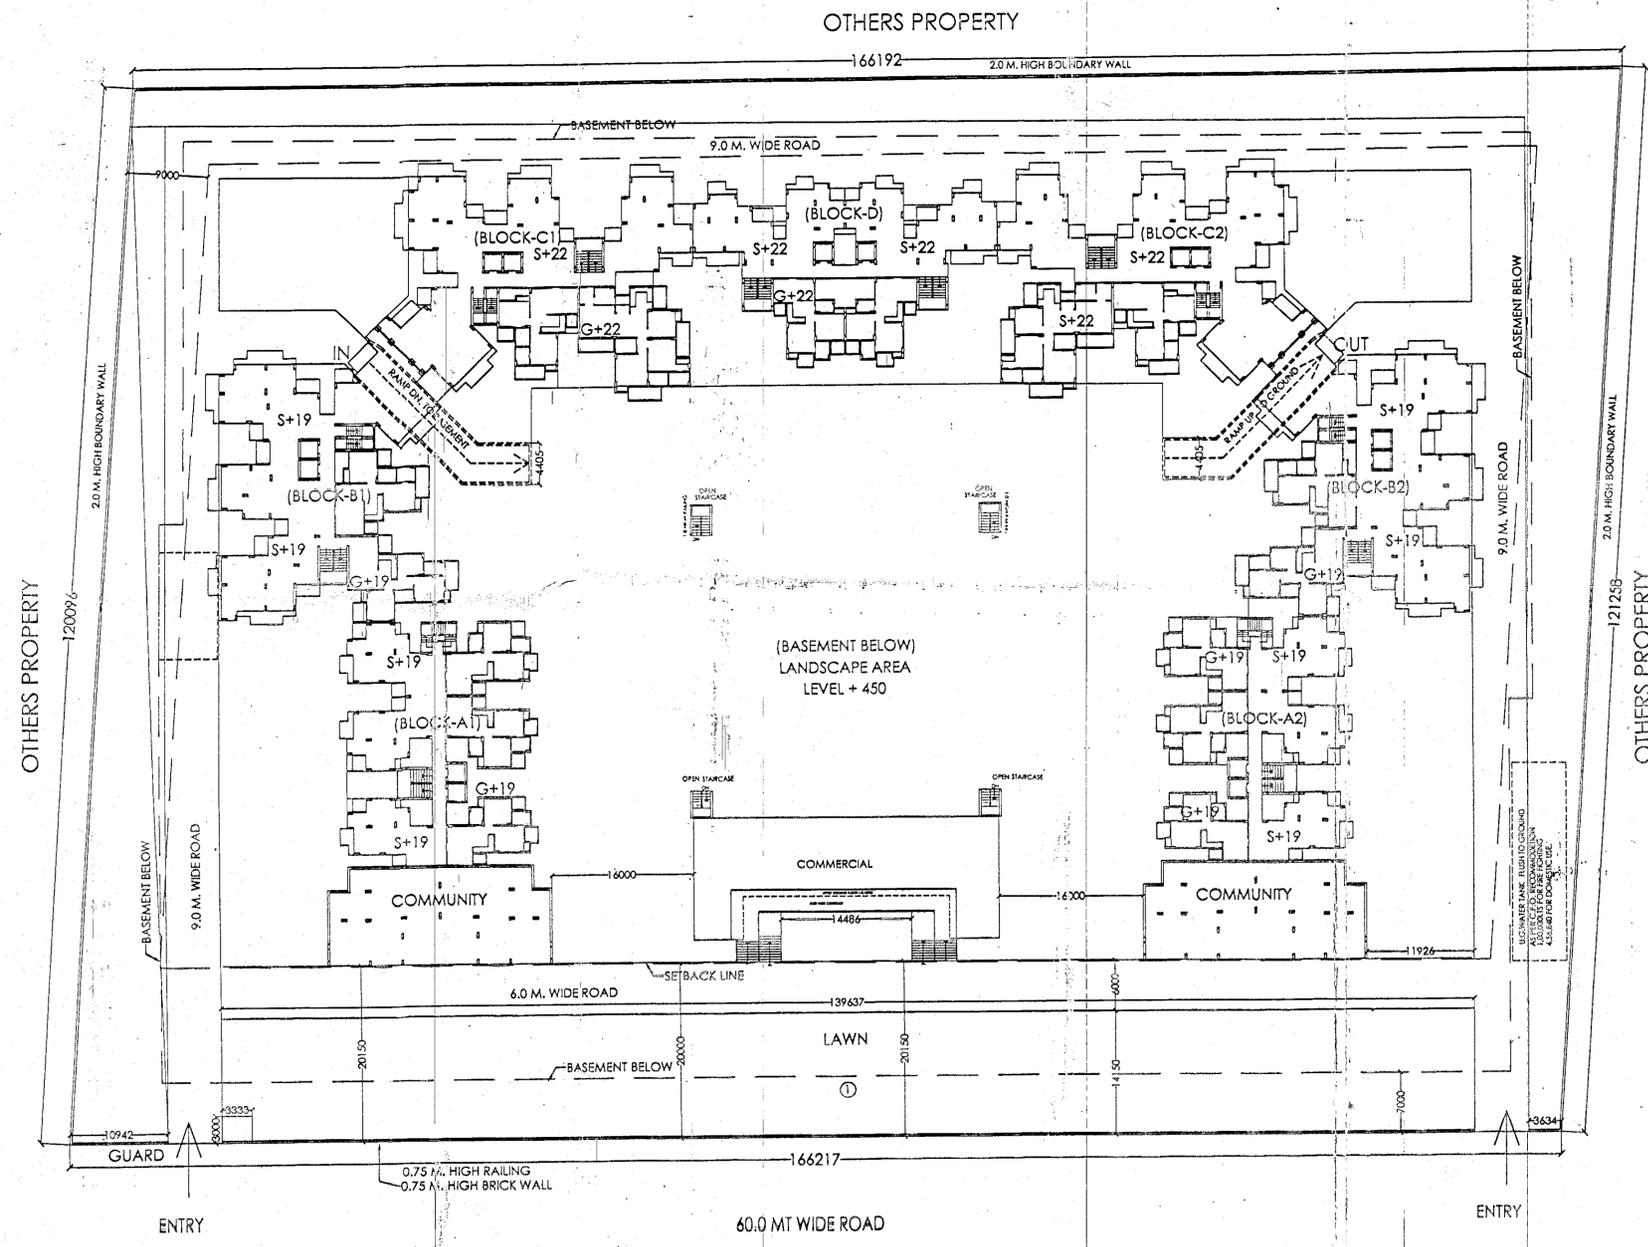
 


Approved  
 18/06/2014  
 Gen. Manager  
 (Plan. & Arch.)  
 Drawing Checked & Verified By  
 18/06/2014



PROJECT:-  
 GROUP HOUSING FOR  
**M/S JNC CONSTRUCTION PVT. LTD.**  
 PLOT NO.-1C, SECTOR-16 C AT GREATER NOIDA. (U.P.)

SIGNING AUTHORITY  


ARCHITECT'S SIGN:  
  
 M. N. ANDLEY  
 B. ARCH. F.I.I.A., F.I.V.  
 ARCHITECT CAP#75/1841

SUBMISSION DRAWING  
 DRG. TITLE: **ELECTRICAL PLAN**  
 SCALE:-1:400  
 DLT.BY:-  
 DRG. NO.:22  
 DATE:-18/05/2014

NORTH  
 ARCHITECTS:-  
 M. N. ANDLEY B. ARCH. F.I.I.A. F.I.V.  
**ANDLEYS ASSOCIATES PVT. LTD.**  
 ARCHITECTS ENGINEERS PLANNERS  
 39 HOUSING SOCIETY N.D.S.E.-I NEW DELHI - 110049