



PROJECT  
**PROPOSED LAYOUT PLAN FOR COMMERCIAL, SECTOR-G AT SUSHANT GOLF CITY, HI-TECH TOWNSHIP, SULTANPUR ROAD, LUCKNOW**

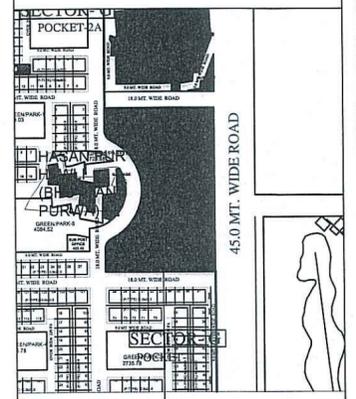

KEY PLAN. (NTS) SITE LOCATION

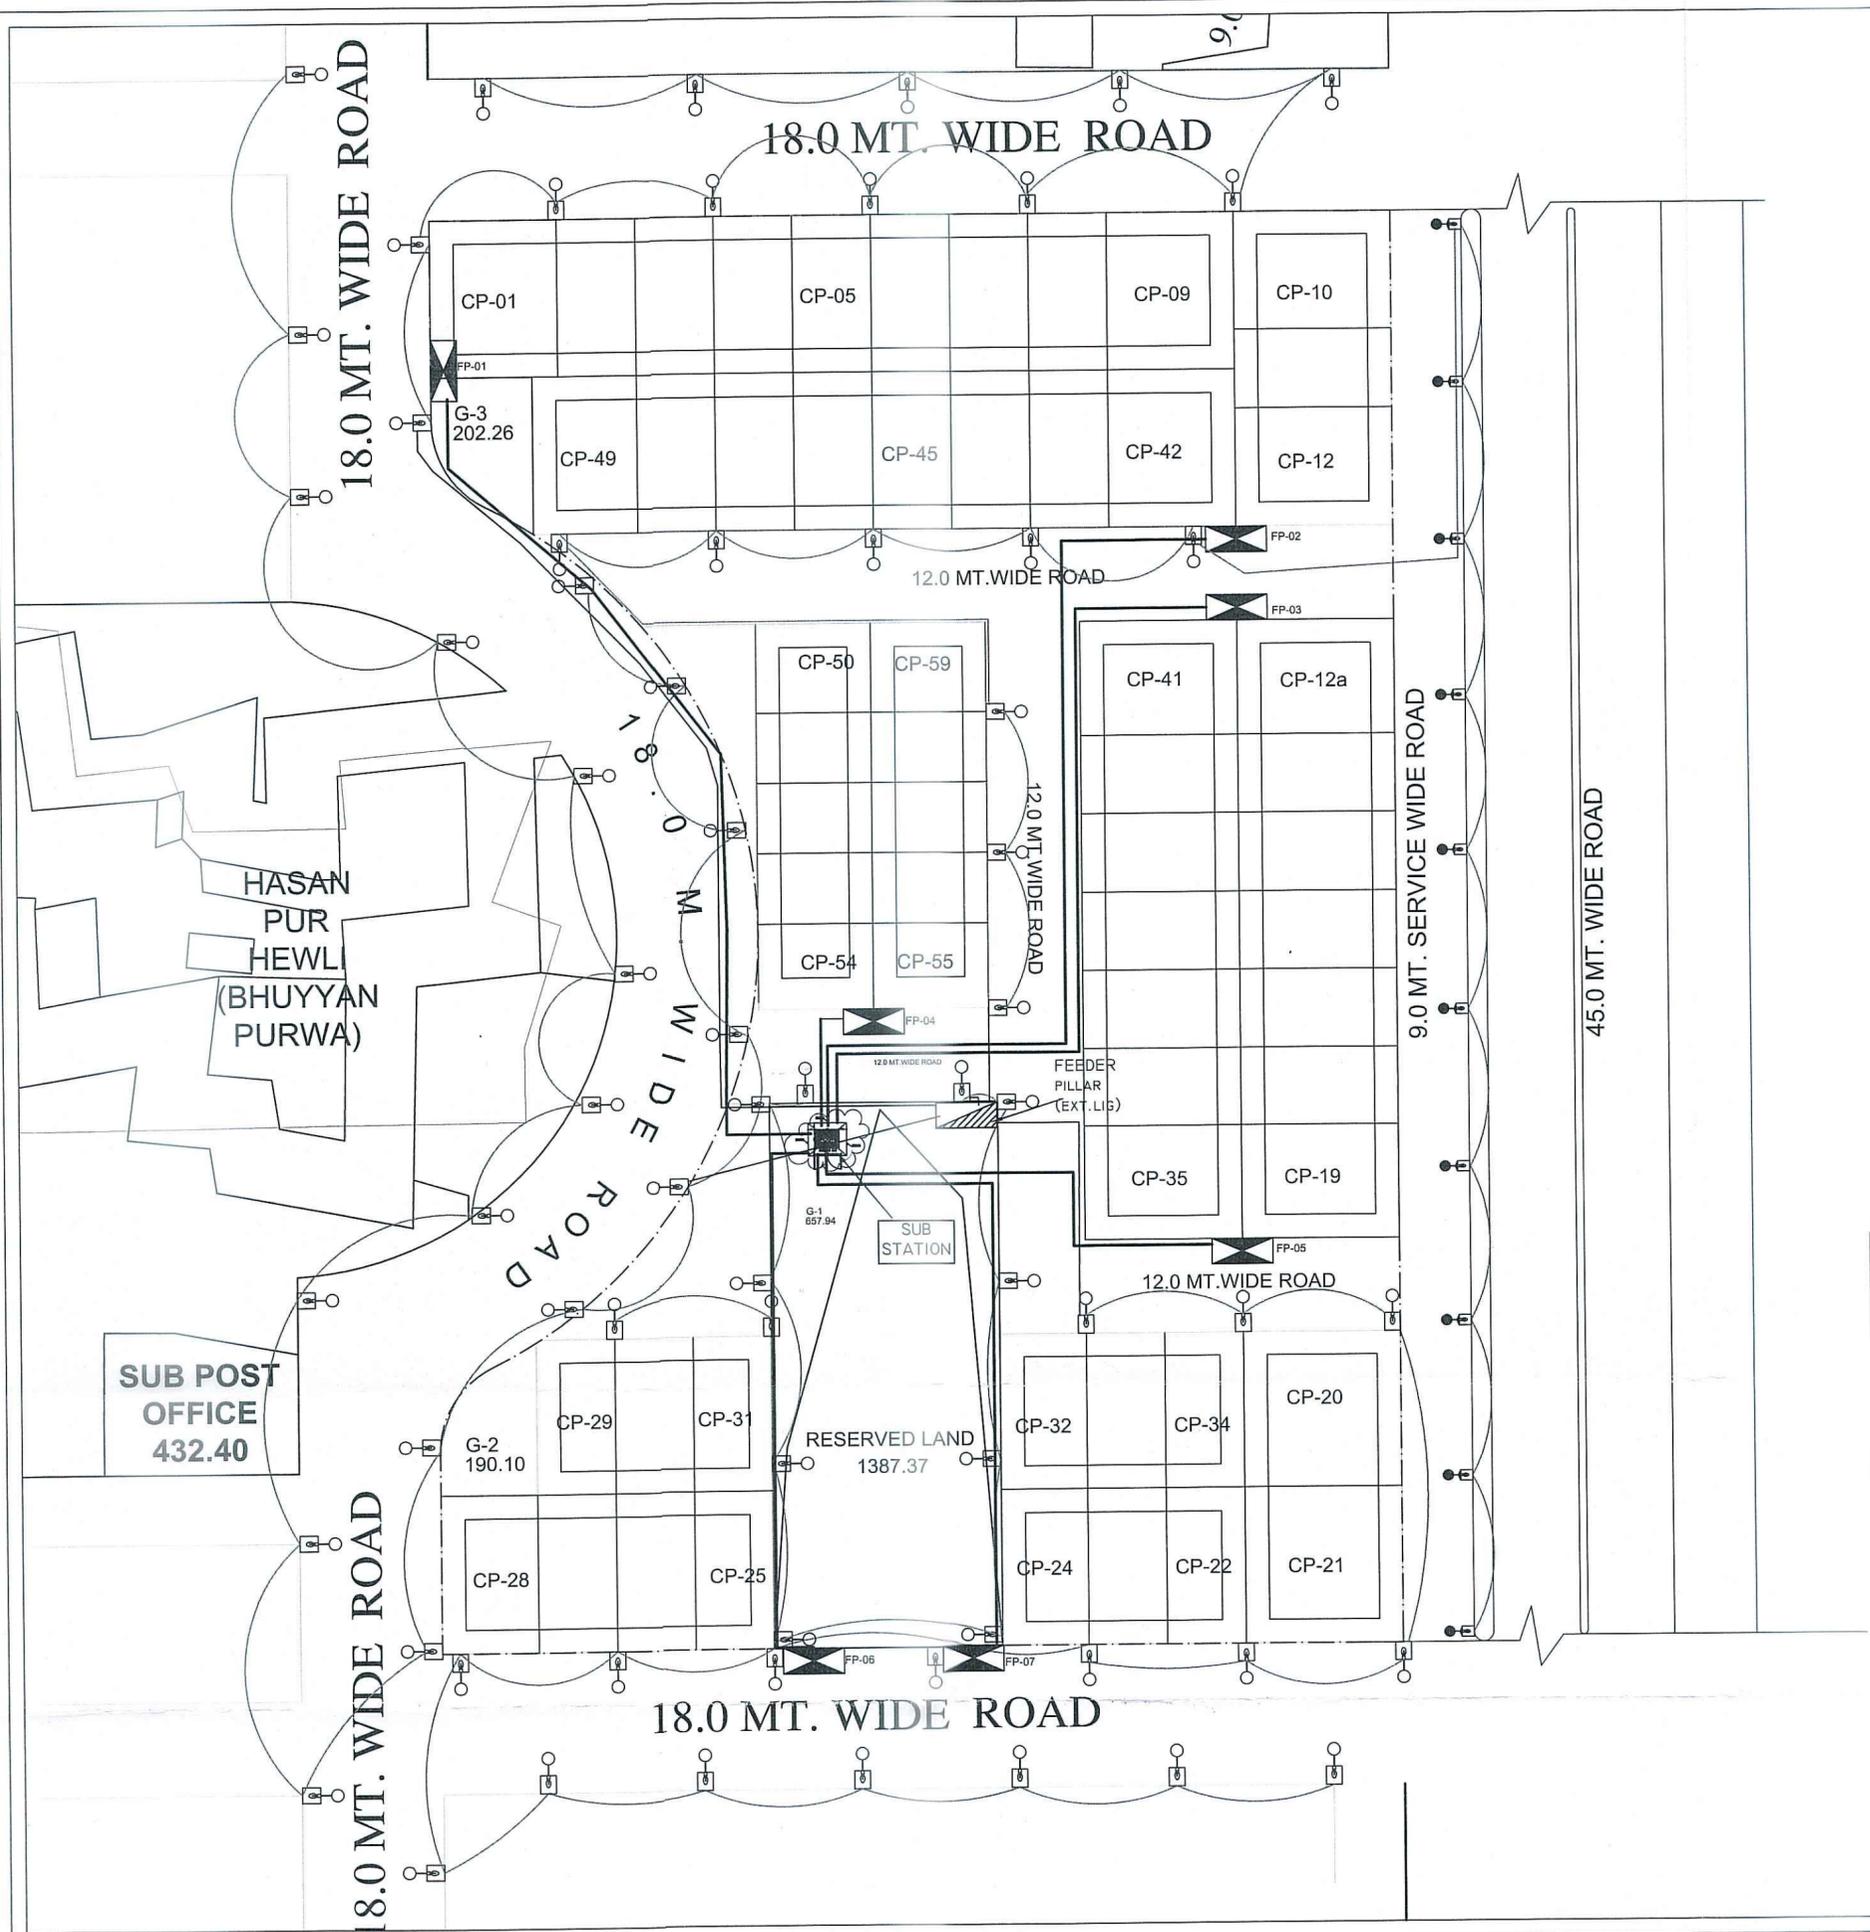

**LEGEND**

S.NO	DESCRIPTION	SYMBOL	DISTANCE
1.	9 M HIGH POLE SINGLE ARM (45W)	○-□	25 - 30 M.
2.	7.5 M HIGH POLE SINGLE ARM (45W)	●-□	20 - 25 M.
3.	FEEDER PILLAR (EXTERNAL LIGHTING)	▨	As/ Site
4.	FEEDER PILLAR	▩	As/ Site
5.	4cX10 Sqmm Cable	—	POLE TO POLE
6.	4cX25 Sqmm Cable	—	PANEL TO POLE
7.	2X3.5cX300 Sqmm Cable	—	S/S TO FP

DRAWING TITLE:  
**ELECTRICAL LAYOUT PLAN- SEC- G (COMMERCIAL)**

DEALT BY RAJ KAPOOR	CHECKED BY
SCALE 1:100	DATE JAN -2019

ARCHITECT	CLIENT/ OWNERS
	ANSAL PROPERTIES & INFRASTRUCTURE LTD. 115, ANSAL BHAWAN, 16, K.C. MARG, NEW DELHI - 110001.

AVP. ELE. SIGNATURE: *[Signature]*  
 OWNER'S SIGNATURE: *[Signature]*

DRG.NO.: HI-TECH/SGC,LKO/COM/SEC-G/SUB-01

*[Handwritten Signature]*  
 16/02/2019