



PROJECT:

RAJDEEP INFRA AND SALES PVT. LTD. LUCKNOW
PLOT .- CP-5A

NOTE:

- This drawing is a property of De:Ca+Pe Studio and is not to be reproduced copied or handed over in any form except for the purpose for which it is intended.
- All dimension are in millimeter except where mentioned.
- All discrepancies to be brought to the notice of the Architect and resolved before commencement of any architectural design work.
- The designing and planning part of the project is done by "DE:CAPE STUDIO" except the structure of the building.
- The proposed structure is using for the educational building.

ELECTRICAL		LEGEND	
Sr. No.	EQUIPMENT	SYMBOL	
1.	RING MAIN UNIT		
2.	TRANSFORMER STEP DOWN		
3.	VACUUM CIRCUIT BREAKER		
4.	GENERATOR		
5.	GENERATOR PANEL		
6.	MAIN LT PANEL		

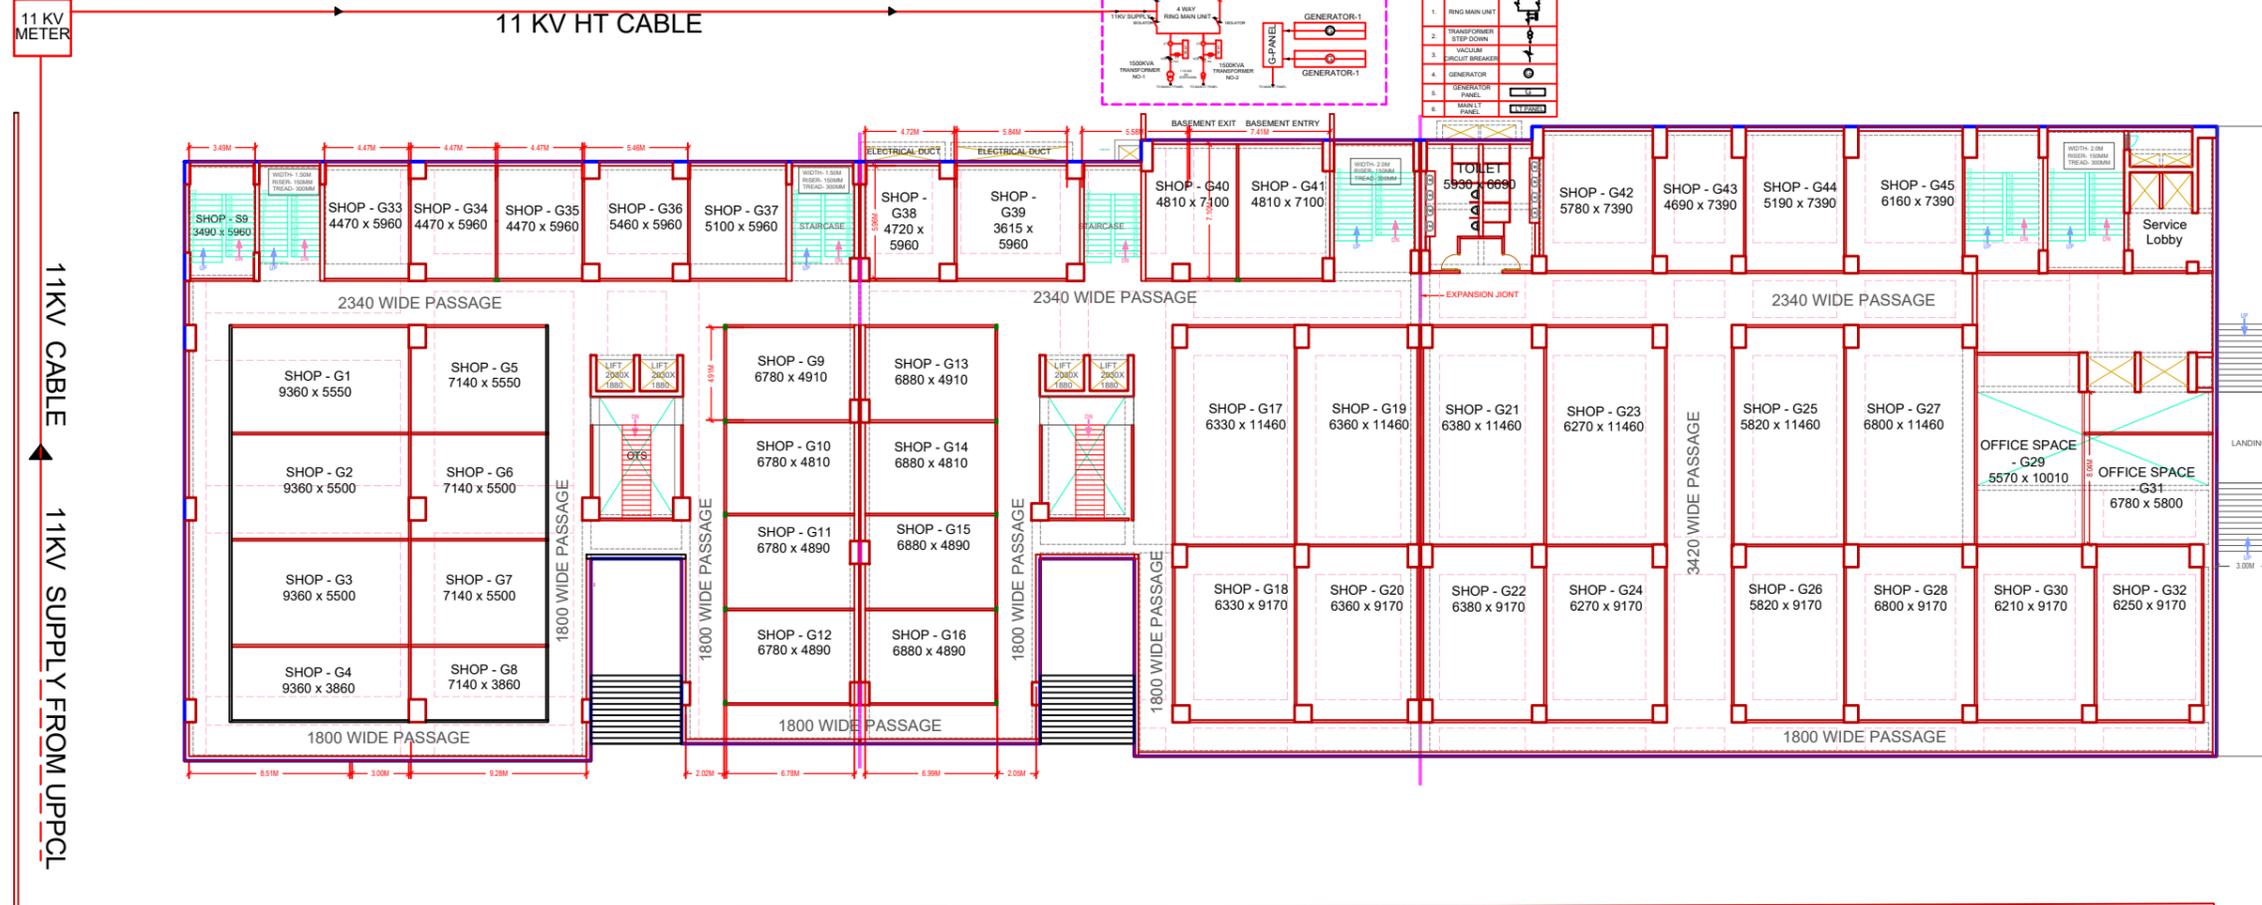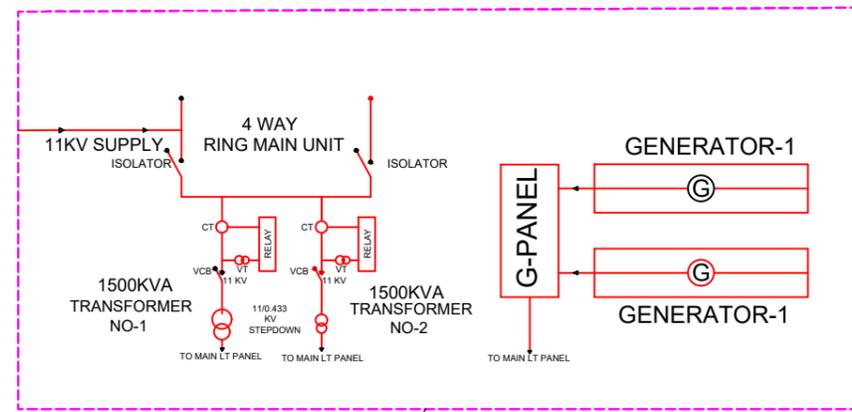

GROUND FLOOR PLAN

GF BUILT UP AREA :3,172.24 SQM.

OWNER / CLIENT:

RAJDEEP INFRA AND SALES PVT. LTD. LUCKNOW

ARCHITECTURAL CONSULTANT PLUMBING CONSULTANT

AR. GAURAV GUPTA

STRUCTURAL CONSULTANT: NORTH:

DRAWING TITLE:

DRAWING NO:-

DRAWN BY: AR. BHUPENDRA DEV

CHKD BY: AR. GAURAV GUPTA

DATE:

SCALE-

PAPER SIZE - A0

CLIENT SIGN:

(Self-Attested)

OFFICE STAMP:

Ar. Gaurav Gupta



DE: CA+PE STUDIO

COLLABORATIVE ARCHITECTURE & PLANNING ENVIRONMENT
L2 - 155 SECTOR-G, LDA COLONY,
ASHIYANA,
KANPUR ROAD, NEAR RJD HOSPITAL,
LUCKNOW - 226012
WEBSITE: decapestudio.com
Ph: +91-9935005439
Mail: decapestudio@gmail.com

PROJECT:

RAJDEEP INFRA AND SALES PVT. LTD. LUCKNOW PLOT .- CP-5A

NOTE:

1. This drawing is a property of De:Ca+Pe Studio and is not to be reproduced copied or handed over in any form except for the purpose for which it is intended.
2. All dimension are in millimeter except where mentioned.
3. All discrepancies to be brought to the notice of the Architect and resolved before commencement of any architectural design work.
4. The designing and planning part of the project is done by "DE+CAPE STUDIO" except the structure of the building.
5. The proposed structure is using for the educational building.

OWNER / CLIENT:

RAJDEEP INFRA AND SALES PVT. LTD. LUCKNOW

ARCHITECTURAL CONSULTANT PLUMBING CONSULTANT

AR. GAURAV GUPTA

STRUCTURAL CONSULTANT: NORTH:

DRAWING TITLE:

DRAWING NO:-

DRAWN BY: AR. BHUPENDRA DEV

CHKD BY: AR. GAURAV GUPTA

DATE:

SCALE-

PAPER SIZE - A0

CLIENT SIGN:

(Self-Attested)


OFFICE STAMP:

Ar. Gaurav Gupta



DE: CA+PE STUDIO

COLLABORATIVE ARCHITECTURE & PLANNING ENVIRONMENT
 L2 - 155 SECTOR-G, LDA COLONY,
 ASHIYANA,
 KANPUR ROAD, NEAR ROY HOSPITAL,
 LUCKNOW - 226012
 WEBSITE: decapestudio.com
 Ph: +91-9935005439
 Mail: decapestudio@gmail.com

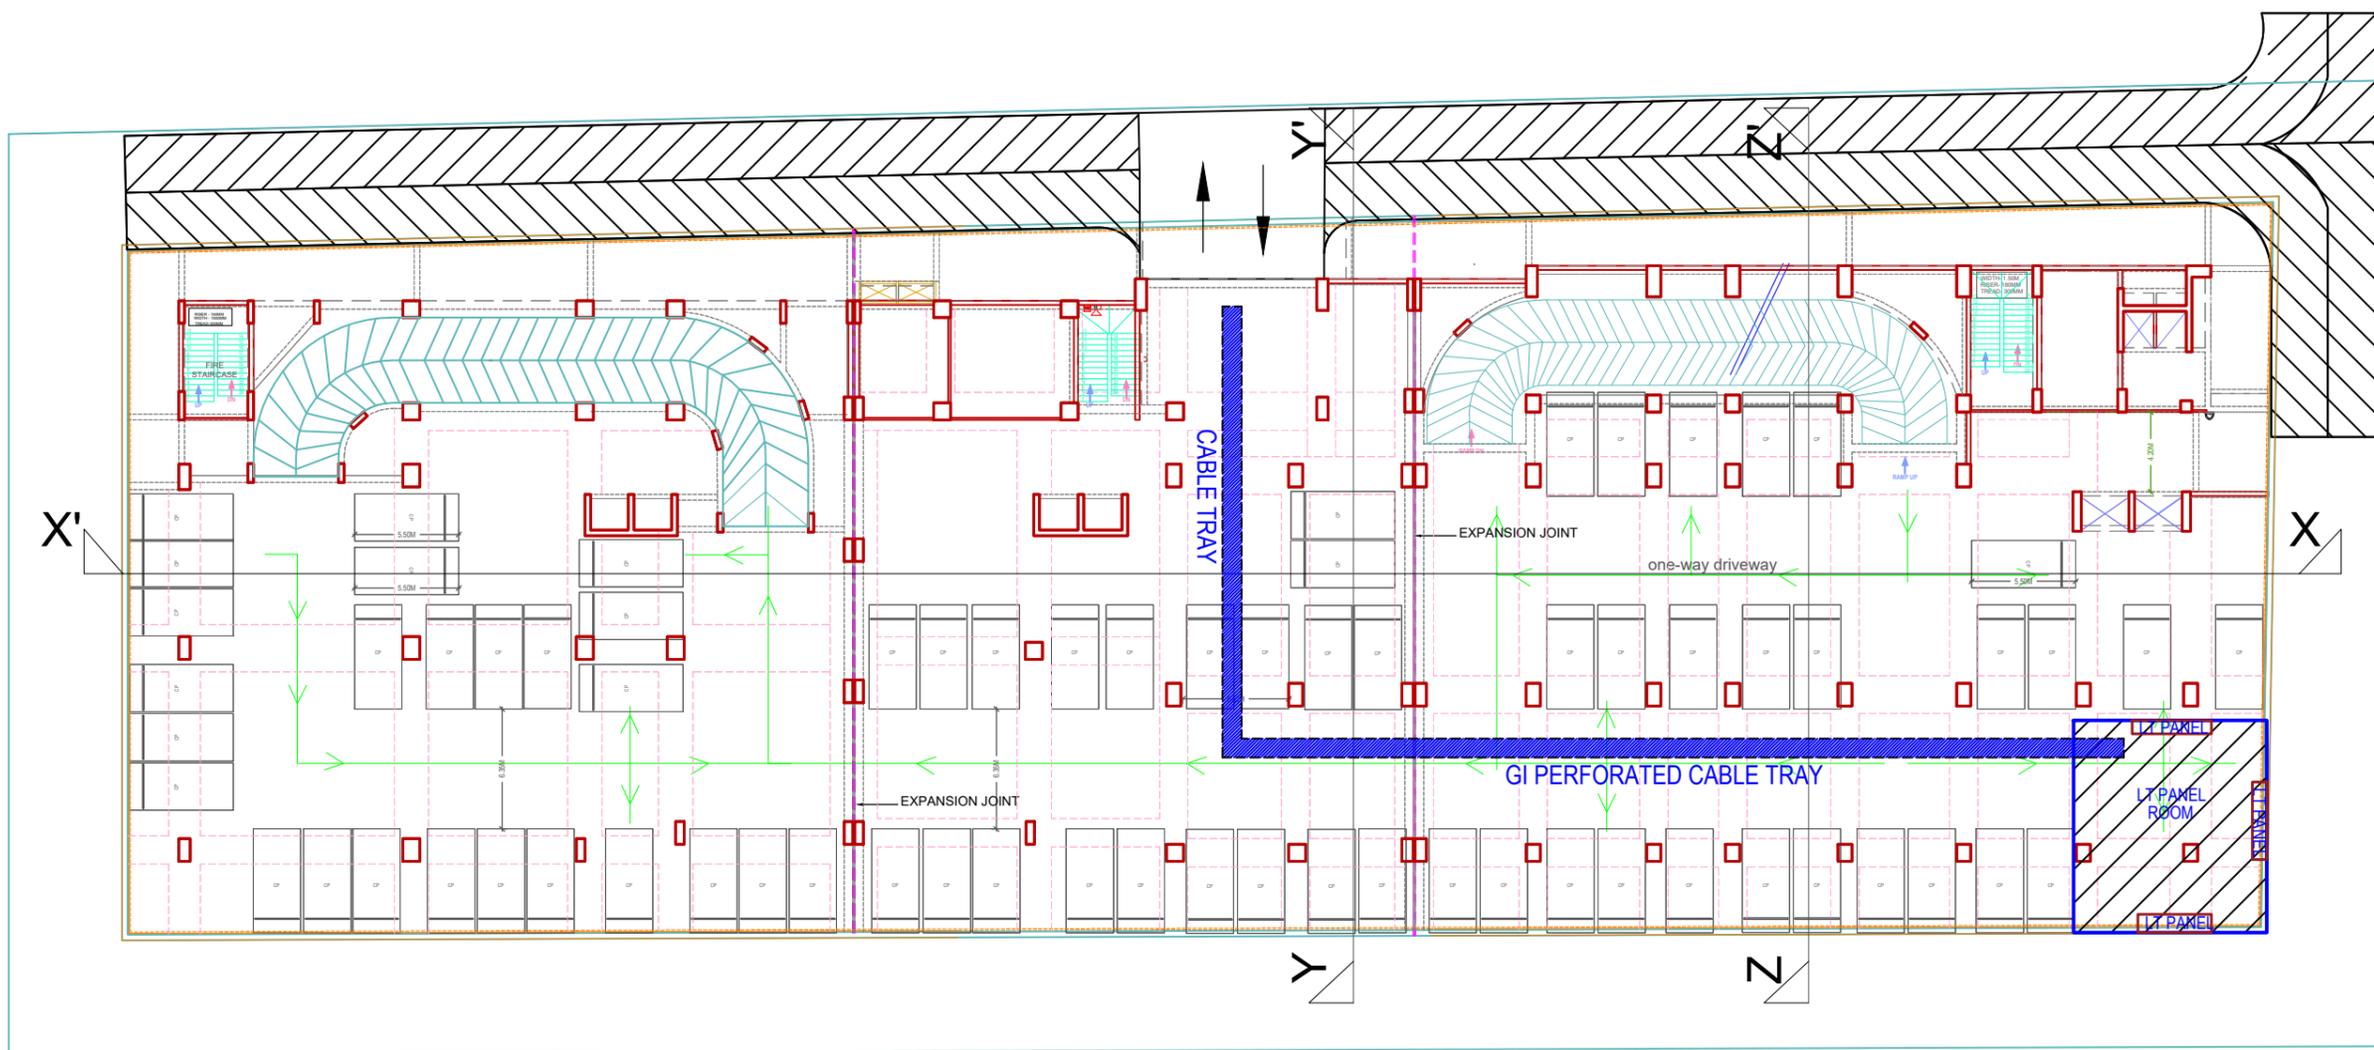

BASEMENT 1

B1 BUILT UP AREA : 4,761.09 SQM.
 CAR PARKING AVAILABLE : 72 CARS

PROJECT:

RAJDEEP INFRA AND SALES PVT. LTD. LUCKNOW PLOT .- CP-5A

NOTE:

1. This drawing is a property of De:Ca+Pe Studio and is not to be reproduced copied or handed over in any form except for the purpose for which it is intended.
2. All dimension are in millimeter except where mentioned.
3. All discrepancies to be brought to the notice of the Architect and resolved before commencement of any architectural design work.
4. The designing and planning part of the project is done by "DE+CAPE STUDIO" except the structure of the building.
5. The proposed structure is using for the educational building.

OWNER / CLIENT:

RAJDEEP INFRA AND SALES PVT. LTD. LUCKNOW

ARCHITECTURAL CONSULTANT AR. GAURAV GUPTA PLUMBING CONSULTANT

STRUCTURAL CONSULTANT: NORTH:

DRAWING TITLE:

DRAWING NO:-

DRAWN BY: AR. BHUPENDRA DEV

CHKD BY: AR. GAURAV GUPTA

DATE:

SCALE-

PAPER SIZE - A0

CLIENT SIGN:

(Self Attested) [Signature and Stamp]


OFFICE STAMP:

[Signature and Stamp]



DE: CA+PE STUDIO

COLLABORATIVE ARCHITECTURE & PLANNING ENVIRONMENT L2 - 155 SECTOR-G, LDA COLONY, ASHIYANA, KANPUR ROAD, NEAR ROY HOSPITAL, LUCKNOW - 226012 WEBSITE: decapestudio.com Ph: +91-9935005439 Mail: decapestudio@gmail.com

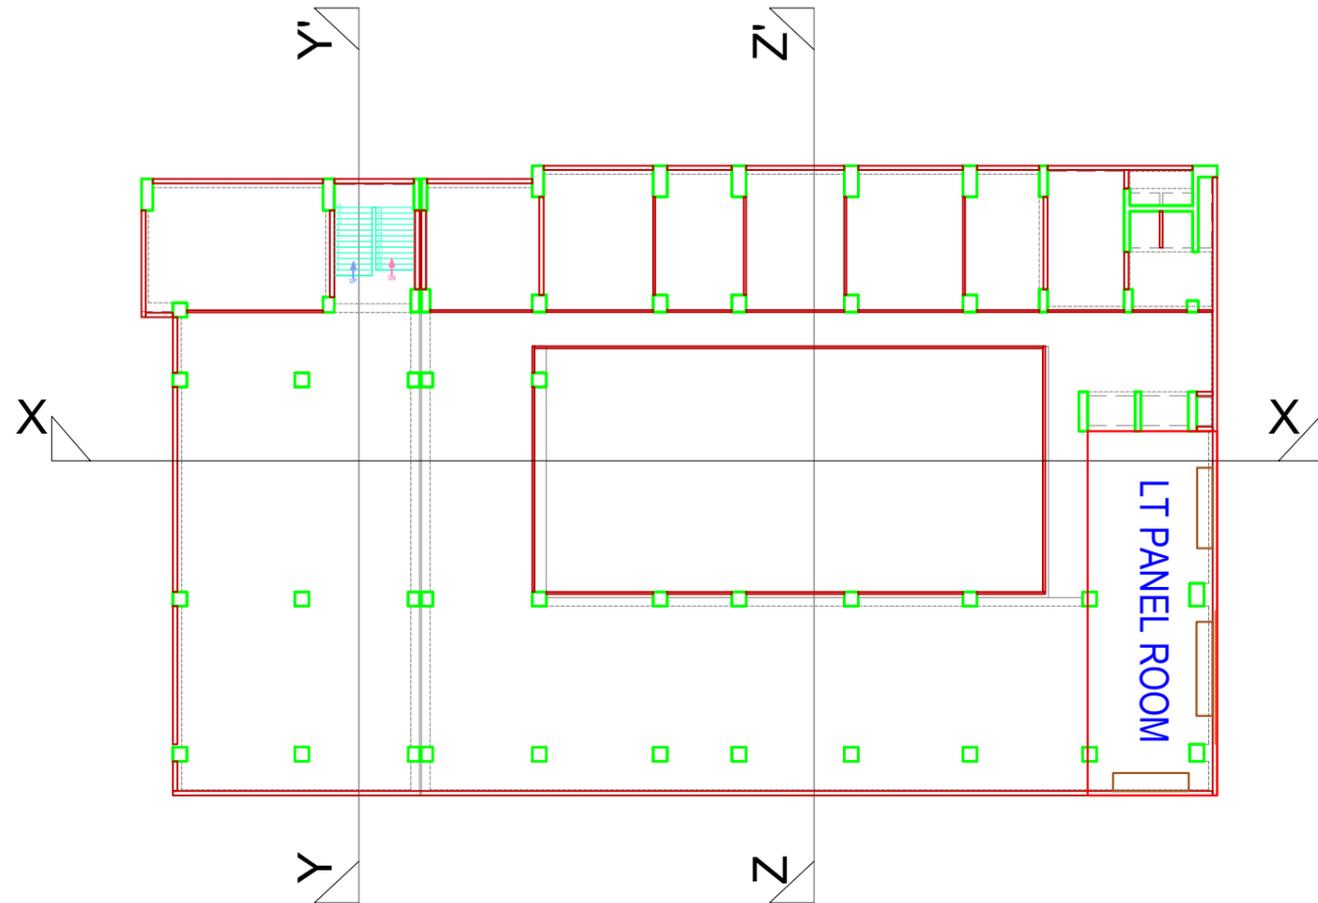

SERVICE FLOOR

SERVICE BUILT UP AREA : 1,383.44 SQM.